



Smith + Andersen

4211 Yonge Street Suite 500 Toronto Ontario M2P 2A9

416 487 8151 f 416 487 9104 smithandandersen.com

ADDENDUM

PROJECT NAME: Our Lady of Perpetual Help – Barrier Free Elevator Expansion

COMPANY: BNC Architects

ATTENTION: Elie Newman

PROJECT NO.: 14214-002-001

DATE: 2016-07-20

ADDENDUM NO.: PTA-E-01

ISSUED BY: Abraham Wong

1.0 REFERENCE

1.1 Drawings E001, E002, E003, E004, E100, ED100 (Attached)

2.0 DRAWINGS:

2.1 E001

2.1.1 Revise light fixture schedule as shown on drawing.

2.2 E002

2.2.1 Revise general intent of raceway routing through HSS as shown.

2.3 E003

2.3.1 Provide separate circuit for Pump P-2 and additional circuit for glycol makeup package as shown.

2.3.2 Information only: Clarify circuit requirements for EF-1 as shown.

2.4 E100

2.4.1 Revise lighting layout as shown. Ceiling of expansion has been revised to drywall ceiling aligned with structural HSS. Summary of revisions described as follows:

- .1 Delete bollard lighting and step lighting.
- .2 Replace bollard lighting and step lighting with ceiling mounted suspended or surface mounted linear led fixtures as shown.
- .3 Revise basement ceiling recessed lighting to match ground level manufacturer as shown.

The above amendments are hereby made as part of the Contract Documents. The above revisions and/or additions shall be made to contract documents and the cost shall be included in the Tender Price.

Vancouver Kelowna Victoria Calgary Edmonton Winnipeg London **Toronto** Ottawa

- .4 Revise occupancy sensor location and type as shown. Three occupancy sensors shall control circuit RPZ.2. Occupancy sensor shall be revised to dual tech with photocell as shown by Leviton O2CXX-MDW series or approved equivalent..
- .5 Revise battery unit locations.
- .6 Revise exit sign location from HSS to be ceiling mounted as shown.
- .7 Revise automatic door operator push buttons as shown.
- .8 Generally wiring shall be routed within ceiling of expansion, through HSS as required and down into basement level in storage room. Coordinate holes as required with structural steel contractor.
- .9 Provide Legrand 2000 series raceway in grey finish for all wiring exposed.
- .10 Add 7-day programmable timer light switch for architectural light box provisions.
- .11 Adjust basement storage lighting as shown.


3.0 CLARIFICATION

- 3.1.1 Revised based on architectural and structural revisions to expansion ceiling.
- 3.1.2 Coordination with mechanical.

END OF ELECTRICAL POST TENDER ADDENDUM NO. 01

LUMINAIRE SCHEDULE					
TYPE	LAMP QTY. TYPE	VOLTAGE	DIMENSION	DESCRIPTION	MANUFACTURER/CATALOGUE NO.
L1	1 41.03W LED (3500K)	120V	3"W X 3-7/8"H X 4'L	NARROW 4" LENSED LED STRIP LIGHT WITH ELECTRONIC DRIVER, AND FULL FROSTED LENS.	METALUX SNLED LIGHTING CAT# 43NLED-LD4-41SL-LW-UNV-L8XX-CD1-U
L2	1 34W LED (3500K)	120V	2-1/8"W X 4"H X 4'L	4" EXTRUDED ALUMINUM LINEAR LED LIGHT SURFACE MOUNT WITH THREE SIDED DIFFUSE LENS AND MACHINED ALUMINUM END CAPS. STANDARD FINISH TO BE CONFIRMED BY ARCHITECT AS PART OF SHOP DRAWING PROCESS.	BARTCO LIGHTING BSS210
L3	1 84W LED (3500K)	120V	2"W X 4.13"H X 12'L	12" EXTRUDED ALUMINUM LINEAR LED PENDANT LIGHT SUSPENDED 9' AFF. SATIN WHITE DIFFUSE LENS AND MACHINED ALUMINUM END CAPS. STANDARD FINISH TO BE CONFIRMED BY ARCHITECT AS PART OF SHOP DRAWING PROCESS.	COOPER LIGHTING S122-DP-1-35-SC48-144 SERIES.
L3A	1 28W LED (3500K)	120V	2-1/8"W X 4.13"H X 4'L	4" EXTRUDED ALUMINUM LINEAR LED PENDANT LIGHT SUSPENDED 9' AFF. SATIN WHITE DIFFUSE LENS AND MACHINED ALUMINUM END CAPS. STANDARD FINISH TO BE CONFIRMED BY ARCHITECT AS PART OF SHOP DRAWING PROCESS.	COOPER LIGHTING S122-DP-1-35-SC48-048 SERIES.
L4	1 56W LED (3500K)	120V	2"W X 4.13"H X 8'L	8" EXTRUDED ALUMINUM LINEAR LED SURFACE MOUNTED LIGHT. SATIN WHITE DIFFUSE LENS AND MACHINED ALUMINUM END CAPS. STANDARD FINISH TO BE CONFIRMED BY ARCHITECT AS PART OF SHOP DRAWING PROCESS.	COOPER LIGHTING S122-DS-1-35-096 SERIES.
L4A	1 28W LED (3500K)	120V	2"W X 4.13"H X 4'L	4" EXTRUDED ALUMINUM LINEAR LED SURFACE MOUNTED LIGHT. SATIN WHITE DIFFUSE LENS AND MACHINED ALUMINUM END CAPS. STANDARD FINISH TO BE CONFIRMED BY ARCHITECT AS PART OF SHOP DRAWING PROCESS.	COOPER LIGHTING S122-DS-1-35-048 SERIES.
L5	1 56W LED (3500K)	120V	2"W X 4.13"H X 8'L	8" EXTRUDED ALUMINUM LINEAR LED RECESSED LIGHT. SATIN WHITE DIFFUSE LENS. STANDARD TRIM FINISH TO BE CONFIRMED BY ARCHITECT AS PART OF SHOP DRAWING PROCESS.	COOPER LIGHTING S122-DR-1-35-0096 SERIES.
L6	1 16W LED (3500K)	120V	6" DIA. X 17-1/2" L	4" INTEGRATED LED RECESSED DOWNLIGHT WITH SPECIFICATION GRADE REMODEL HOUSING AND ELECTRONIC DRIVER. TRIM TO BE SPECIFICATION GRADE SPECULAR REFLECTOR WITH MEDIUM BEAM.	CONTECH LIGHTING CAT# RA4LRM-130K-12D2-CST4322LM-CLR
L7	1 26W LED (3500K)	120V	8-1/2"D X 11-5/8" H X 8"W	DIE CAST ALUMINUM VABOUR TIGHT LED SERVICE LIGHT WITH FROSTED GLASS GLOBE.	RAB LIGHTING CAT# VXBRLD26YDG
X1	1 LED	120VAC /12VDC	10-3/4"H X 4-1/4"W X 12-1/2"L	ALUMINUM SLIM EDGE-UT PICTOGRAM EXIT SIGN.	LUMACELL LAE SERIES
X2	1 LED	120VAC /12VDC	10-3/4"H X 4-1/4"W X 12-1/2"L	EXTRUDED ALUMINUM PICTOGRAM EXIT SIGN. FLAT TRIM FOR CEILING RECESSED MOUNT. ANGULAR TRIM FOR END MOUNT AND WALL MOUNT.	LUMACELL LDE SERIES
X3	1 6W LED	120VAC /12VDC	12"H X 14"W X 6-1/2"D	EXTRUDED ALUMINUM PICTOGRAM EXIT SIGN WITH BATTERY REMOTE HEADS AND BATTERY.	LUMACELL LAC SERIES

5 LIGHT FIXTURE SCHEDULE

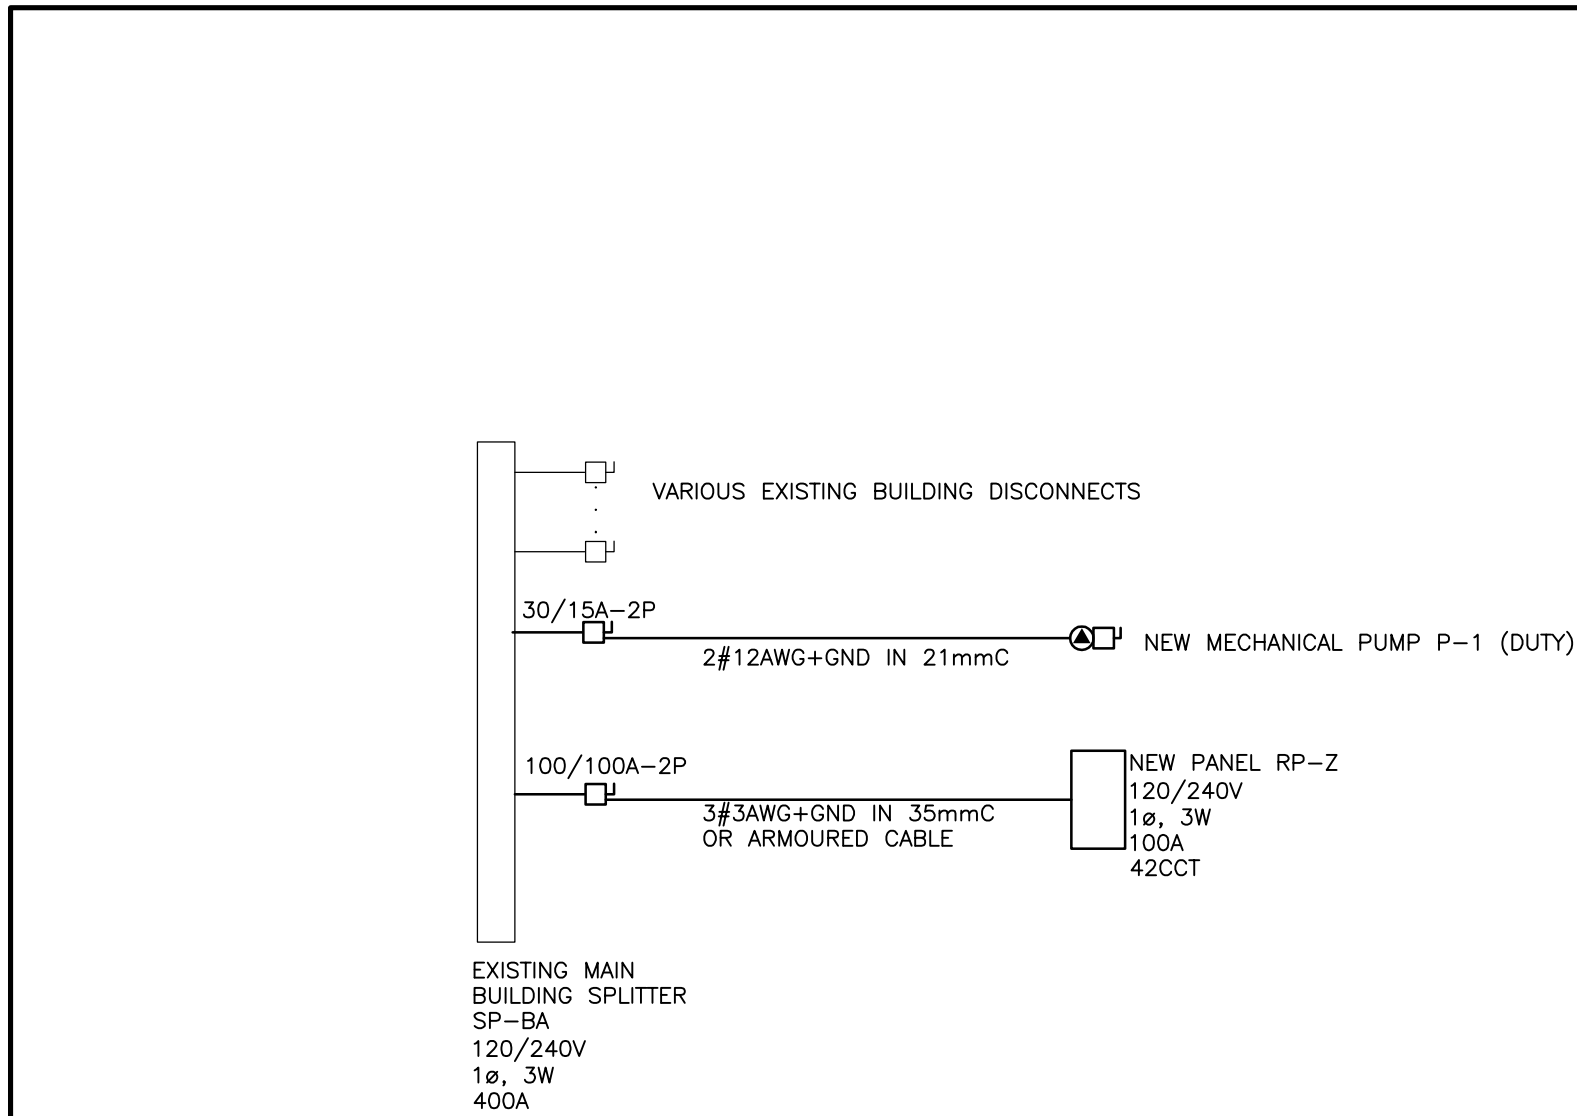


GENERAL NOTES FOR NEW PANEL:

1. FOR RECEPTACLE CIRCUITS INDICATED ON PLAN PROVIDE NEW 15A-1P BREAKERS
2. FOR RECEPTACLE CIRCUITS WITH GFCI INDICATED ON PLAN PROVIDE NEW 15A-1P GFCI BREAKERS
3. FOR ALL LIGHTING CIRCUITS PROVIDE NEW 20A-1P BREAKERS.
4. FOR MECHANICAL EQUIPMENT, PROVIDE NEW BREAKERS AS INDICATED ON PLAN.
5. FOR ELEVATOR MOTOR, PROVIDE NEW 20A-1P BREAKER.

4 ELECTRICAL SINGLE LINE DIAGRAM

ELECTRICAL DRAWING LIST	
Sheet Number	Sheet Title
GENERAL	
E001	LEGEND, DRAWING LIST, AND DETAILS
E002	ELECTRICAL DETAILS
E003	ELECTRICAL BASEMENT PLAN
E004	ELECTRICAL GROUND FLOOR PLAN
POWER AND LIGHTING	
E100	POWER, LIGHTING AND SYSTEMS PLAN
ED100	POWER, LIGHTING, AND SYSTEMS DEMOLITION PLAN

1 DRAWING LIST

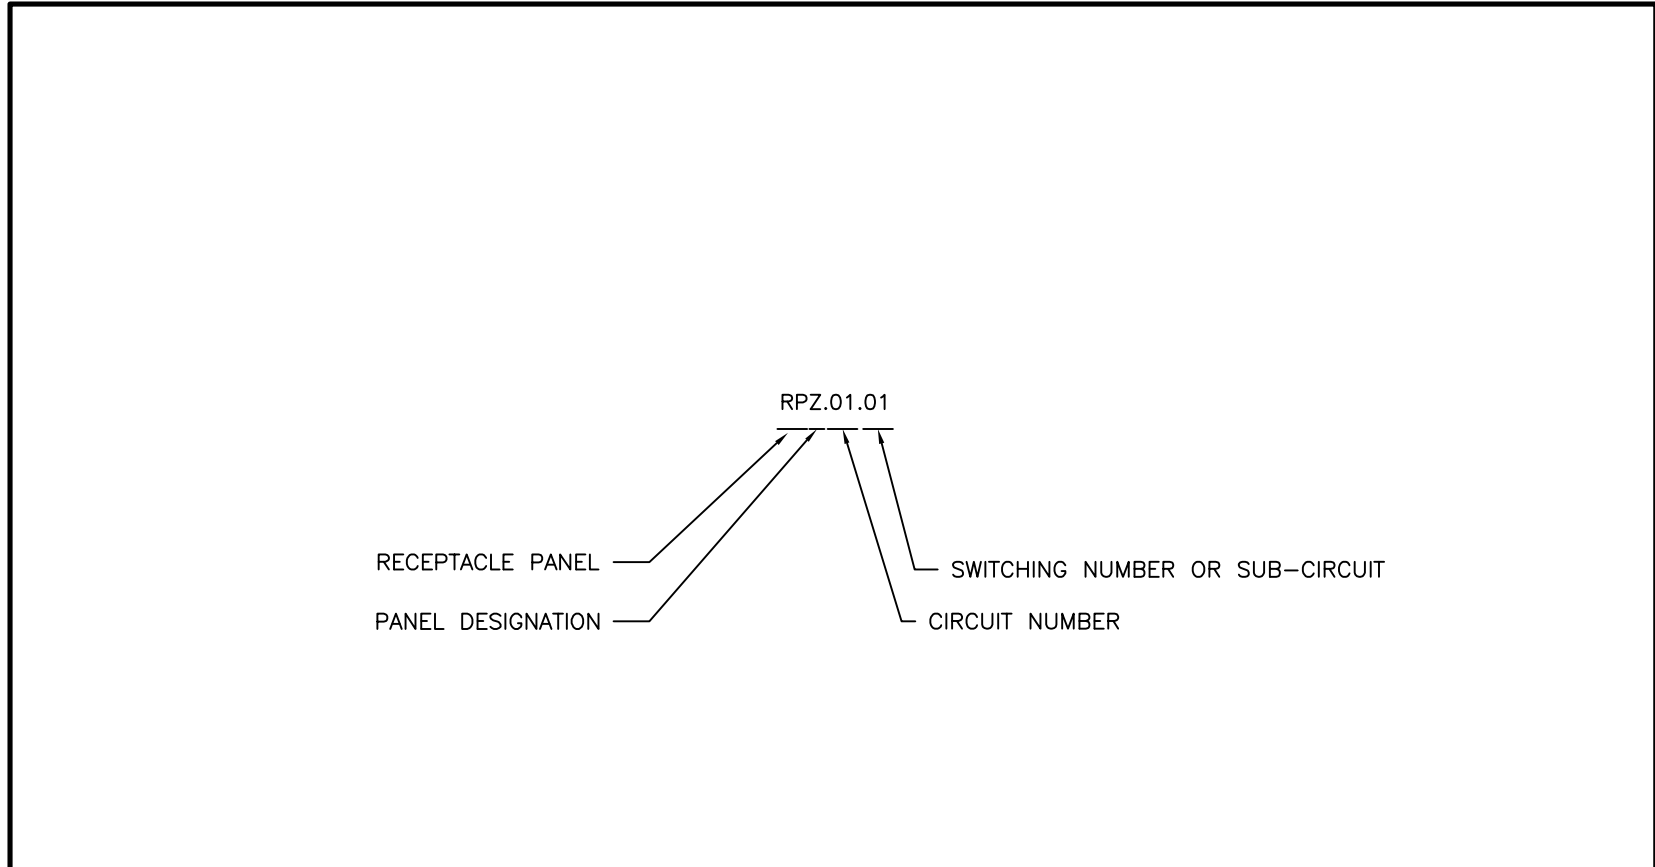


2 PANEL AND CIRCUIT DESIGNATION

SYMBOL	DESCRIPTION	SYMBOL	DESCRIPTION
	CEILING MOUNTED LINEAR LUMINAIRE. DIMENSIONS AS SHOWN. REFER TO SCHEDULE FOR TYPE.		SINGLE POLE LINE VOLTAGE LIGHT SWITCH
	DENOTES FIXTURE ON EMERGENCY/NIGHT LIGHT CIRCUIT.		3 WAY - LINE VOLTAGE LIGHT SWITCH
	WALL MOUNTED LINEAR LUMINAIRE. DIMENSIONS AS SHOWN. REFER TO SCHEDULE FOR TYPE.		4 WAY - LINE VOLTAGE LIGHT SWITCH
	BOLLARD LUMINAIRE		DIMMER TYPE TO SUIT LOAD
	EXISTING LUMINAIRE TO BE REMOVED		COMMUNICATION OUTLET. TYPICAL 1" CONDUIT BACK TO TELECOM SERVICE ENTRY
	EXISTING LUMINAIRE TO REMAIN		CEILING MOUNTED PHOTO-ELECTRIC SMOKE DETECTOR
	WALL MOUNTED LUMINAIRE		CEILING MOUNTED PHOTO-ELECTRIC SMOKE DETECTOR C/W RELAY BASE
	CEILING MOUNTED LUMINAIRE		FIRE ALARM BELL. 103mm(4") UNLESS OTHERWISE NOTED TO MATCH EXISTING.
	WALL MOUNTED EMERGENCY DOUBLE REMOTE HEAD		MANUAL PULL STATION
	CEILING MOUNTED EMERGENCY DOUBLE REMOTE HEAD		ELECTRIC STRIKE FOR ADO LATCH
	EMERGENCY LIGHTING BATTERY UNIT C/W NUMBER OF HEADS SHOWN		AUTOMATIC DOOR OPENER
	EXIT LIGHT CEILING MOUNTED C/W FACES AND ARROWS AS INDICATED		PUSH BUTTON
	EXIT LIGHT WALL MOUNTED C/W FACES AND ARROWS AS INDICATED		
	WALL MOUNTED DUPLEX RECEPTACLE 120 VOLT, 15 AMP, CSA 5-15R		
	WALL MOUNTED DUPLEX RECEPTACLE 120 VOLT, 20 AMP, CSA 5-20R (T-SLOT)		
	WALL MOUNTED DUPLEX GROUND FAULT RECEPTACLE 120 VOLT, 15 AMP, CSA 5-15R		
	WALL MOUNTED DUPLEX GROUND FAULT RECEPTACLE 120 VOLT, 20 AMP CSA 5-20R		
	SINGLE PHASE DIRECT CONNECTION	E	EXISTING TO REMAIN
	THREE PHASE DIRECT CONNECTION	R	REMOVE
	SINGLE PHASE DIRECT CONNECTION C/W DISCONNECT	ER	EXISTING DEVICE IN RELOCATED LOCATION
	THREE PHASE DIRECT CONNECTION C/W DISCONNECT	RR	REMOVE AND RELOCATE

NOTE: NOT ALL SYMBOLS APPLY, REFER TO FLOOR PLANS AND DRAWINGS

3 LEGEND

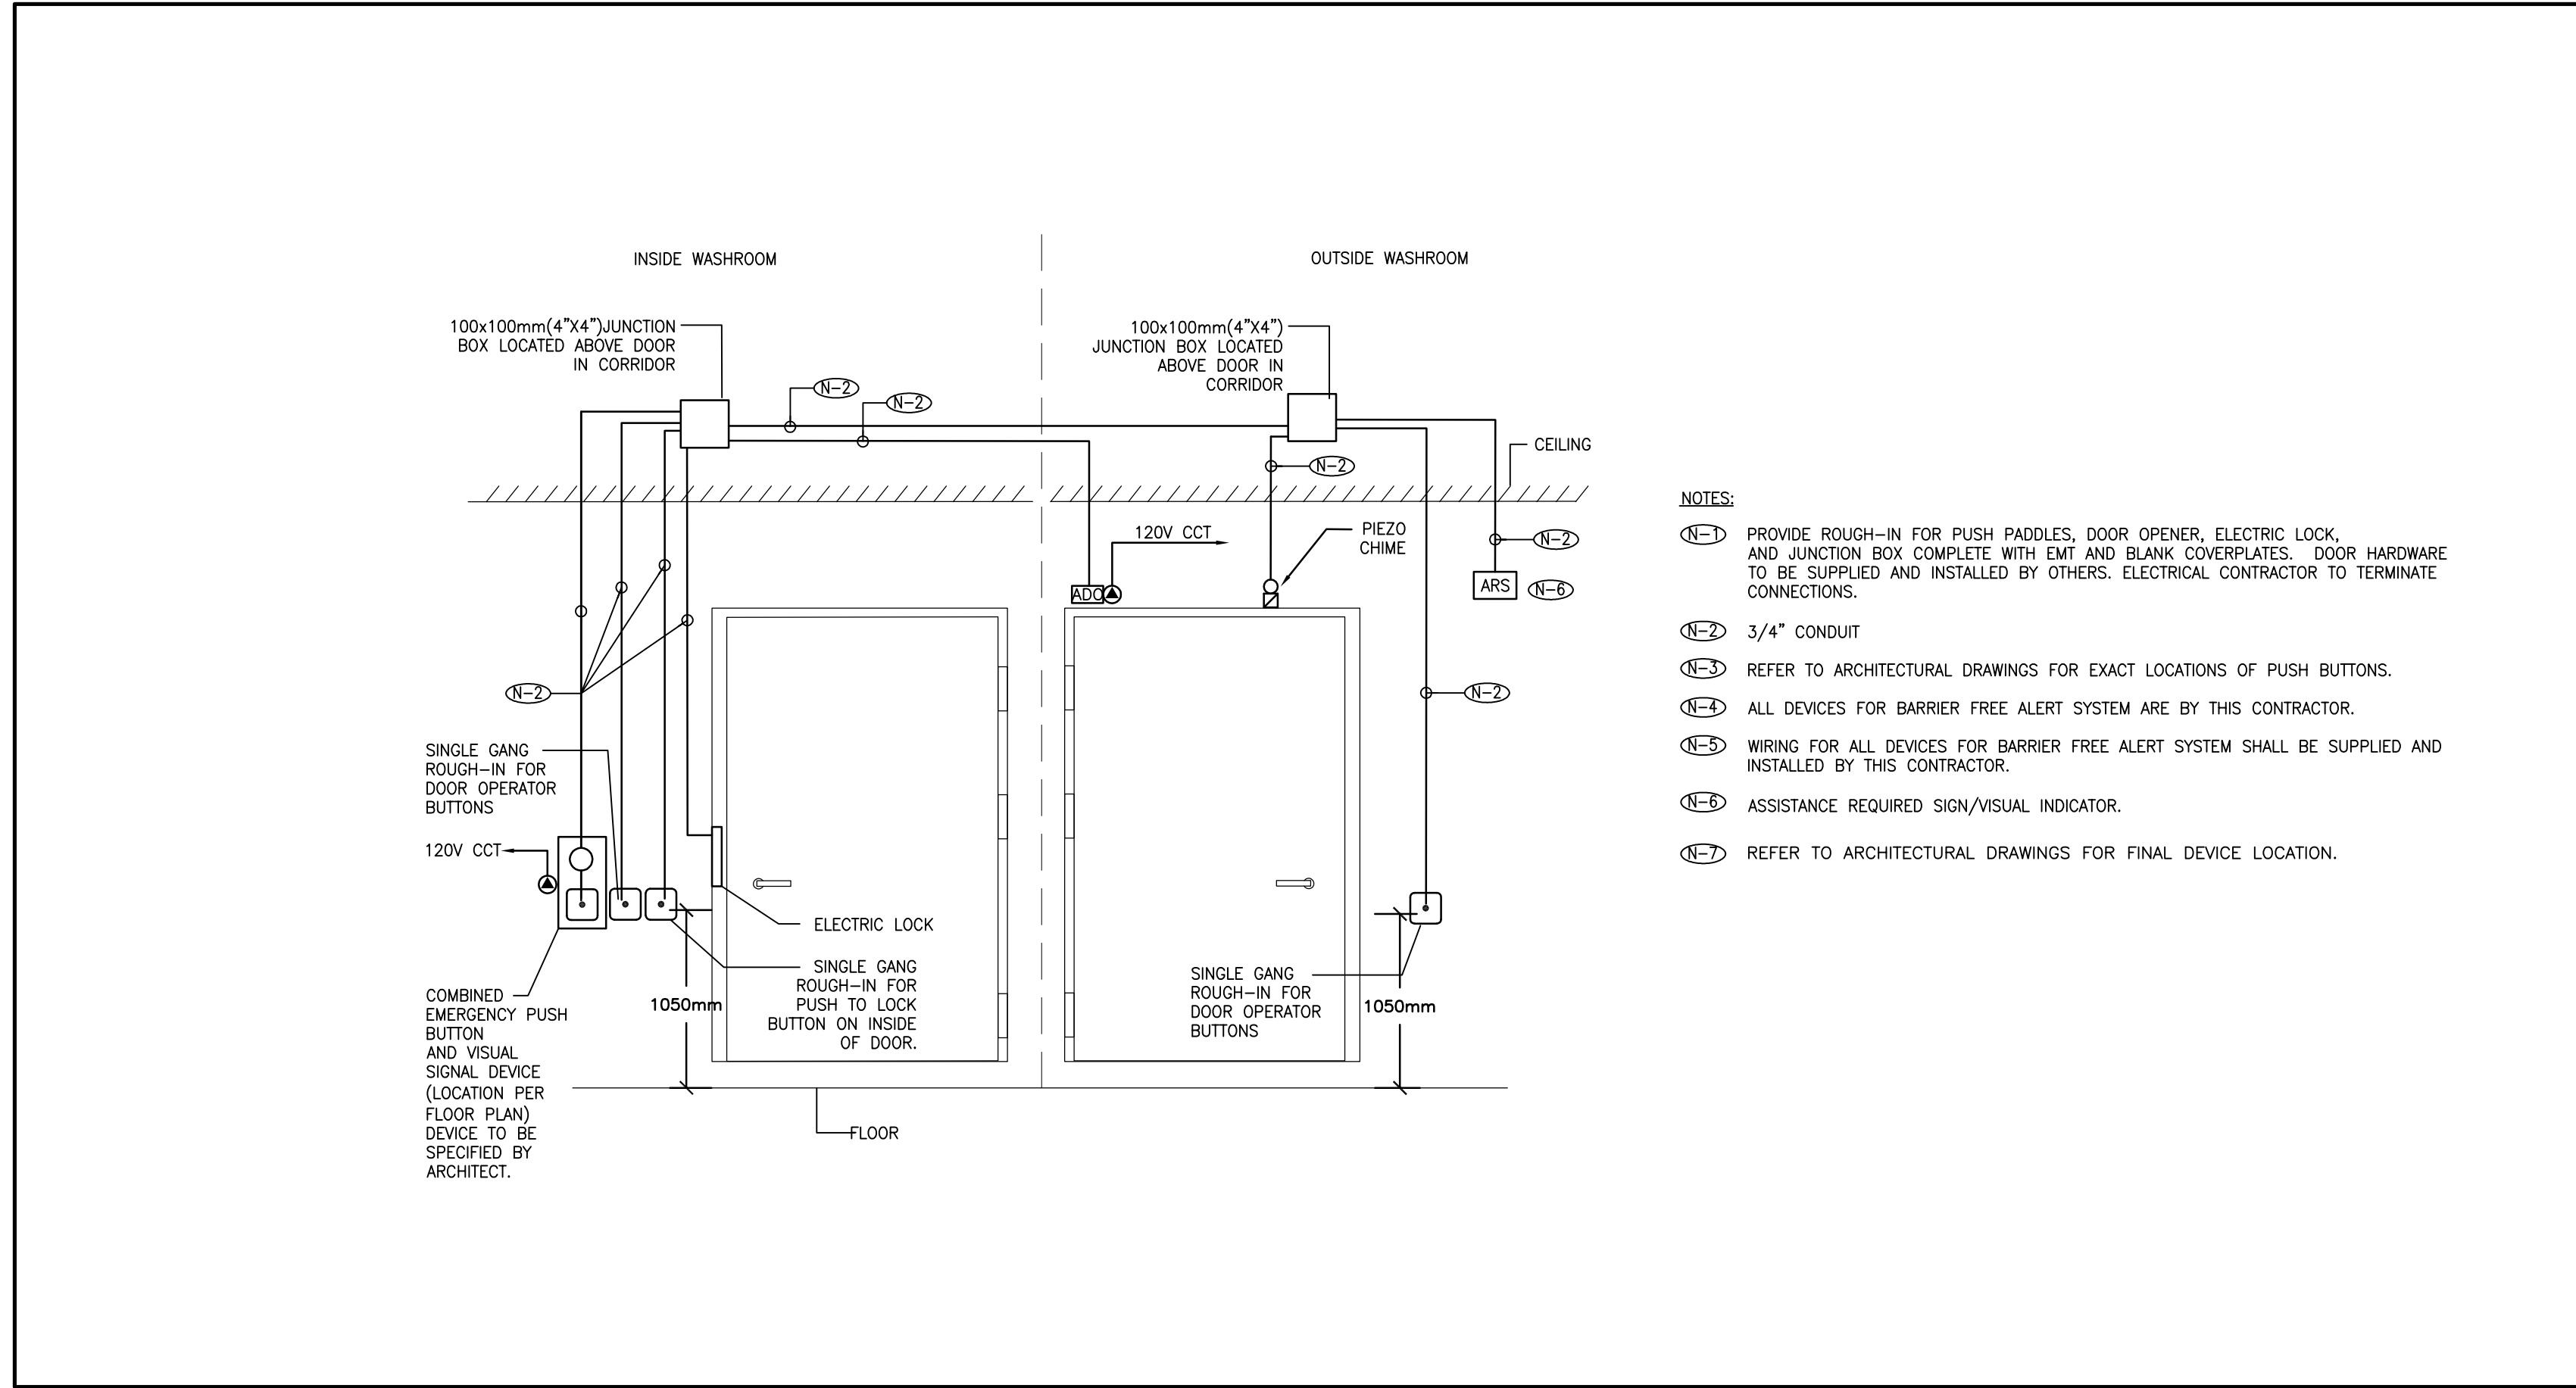

6 BARRIER FREE WASHROOM DETAIL

5.	2016.07.20	ISSUED FOR PTA-E-01
4.	2015.12.04	ISSUED FOR TENDER
3.	2015.10.27	ISSUED FOR PERMIT
2.	2015.05.01	ISSUED FOR PERMIT REVIEW
1.	2015.04.30	ISSUED FOR PROGRESS
REV.	DATE	ISSUED

ALL MEASUREMENTS MUST BE CHECKED ON THE JOB BY THE CONTRACTOR. DRAWINGS MUST NOT BE SCALED. ALL DRAWINGS AND SPECIFICATIONS ARE THE PROPERTY OF THE ARCHITECT AND MUST BE RETURNED UPON REQUEST.

OUR LADY OF PERPETUAL HELP CHURCH RENOVATIONS & ADDITIONS

TORONTO, ONTARIO

Our Lady of Perpetual Help Parish
78 Clifton Road
Toronto, ON M4T 2G2




Smith + Andersen
10320-102 Ave. Suite 501 Edmonton Alberta T5J 4A1
780 701 0331 www.smithandandersen.com

Project Title :


Our Lady of Perpetual Help Addition

Title :
LEGEND, DRAWING LIST, AND DETAILS


Drawn : Project Number : Reviewed By:	AW 14214.002.E001 AW	Scale : Drawing Number : Date : 2015.03.12	E001
---	----------------------------	---	------

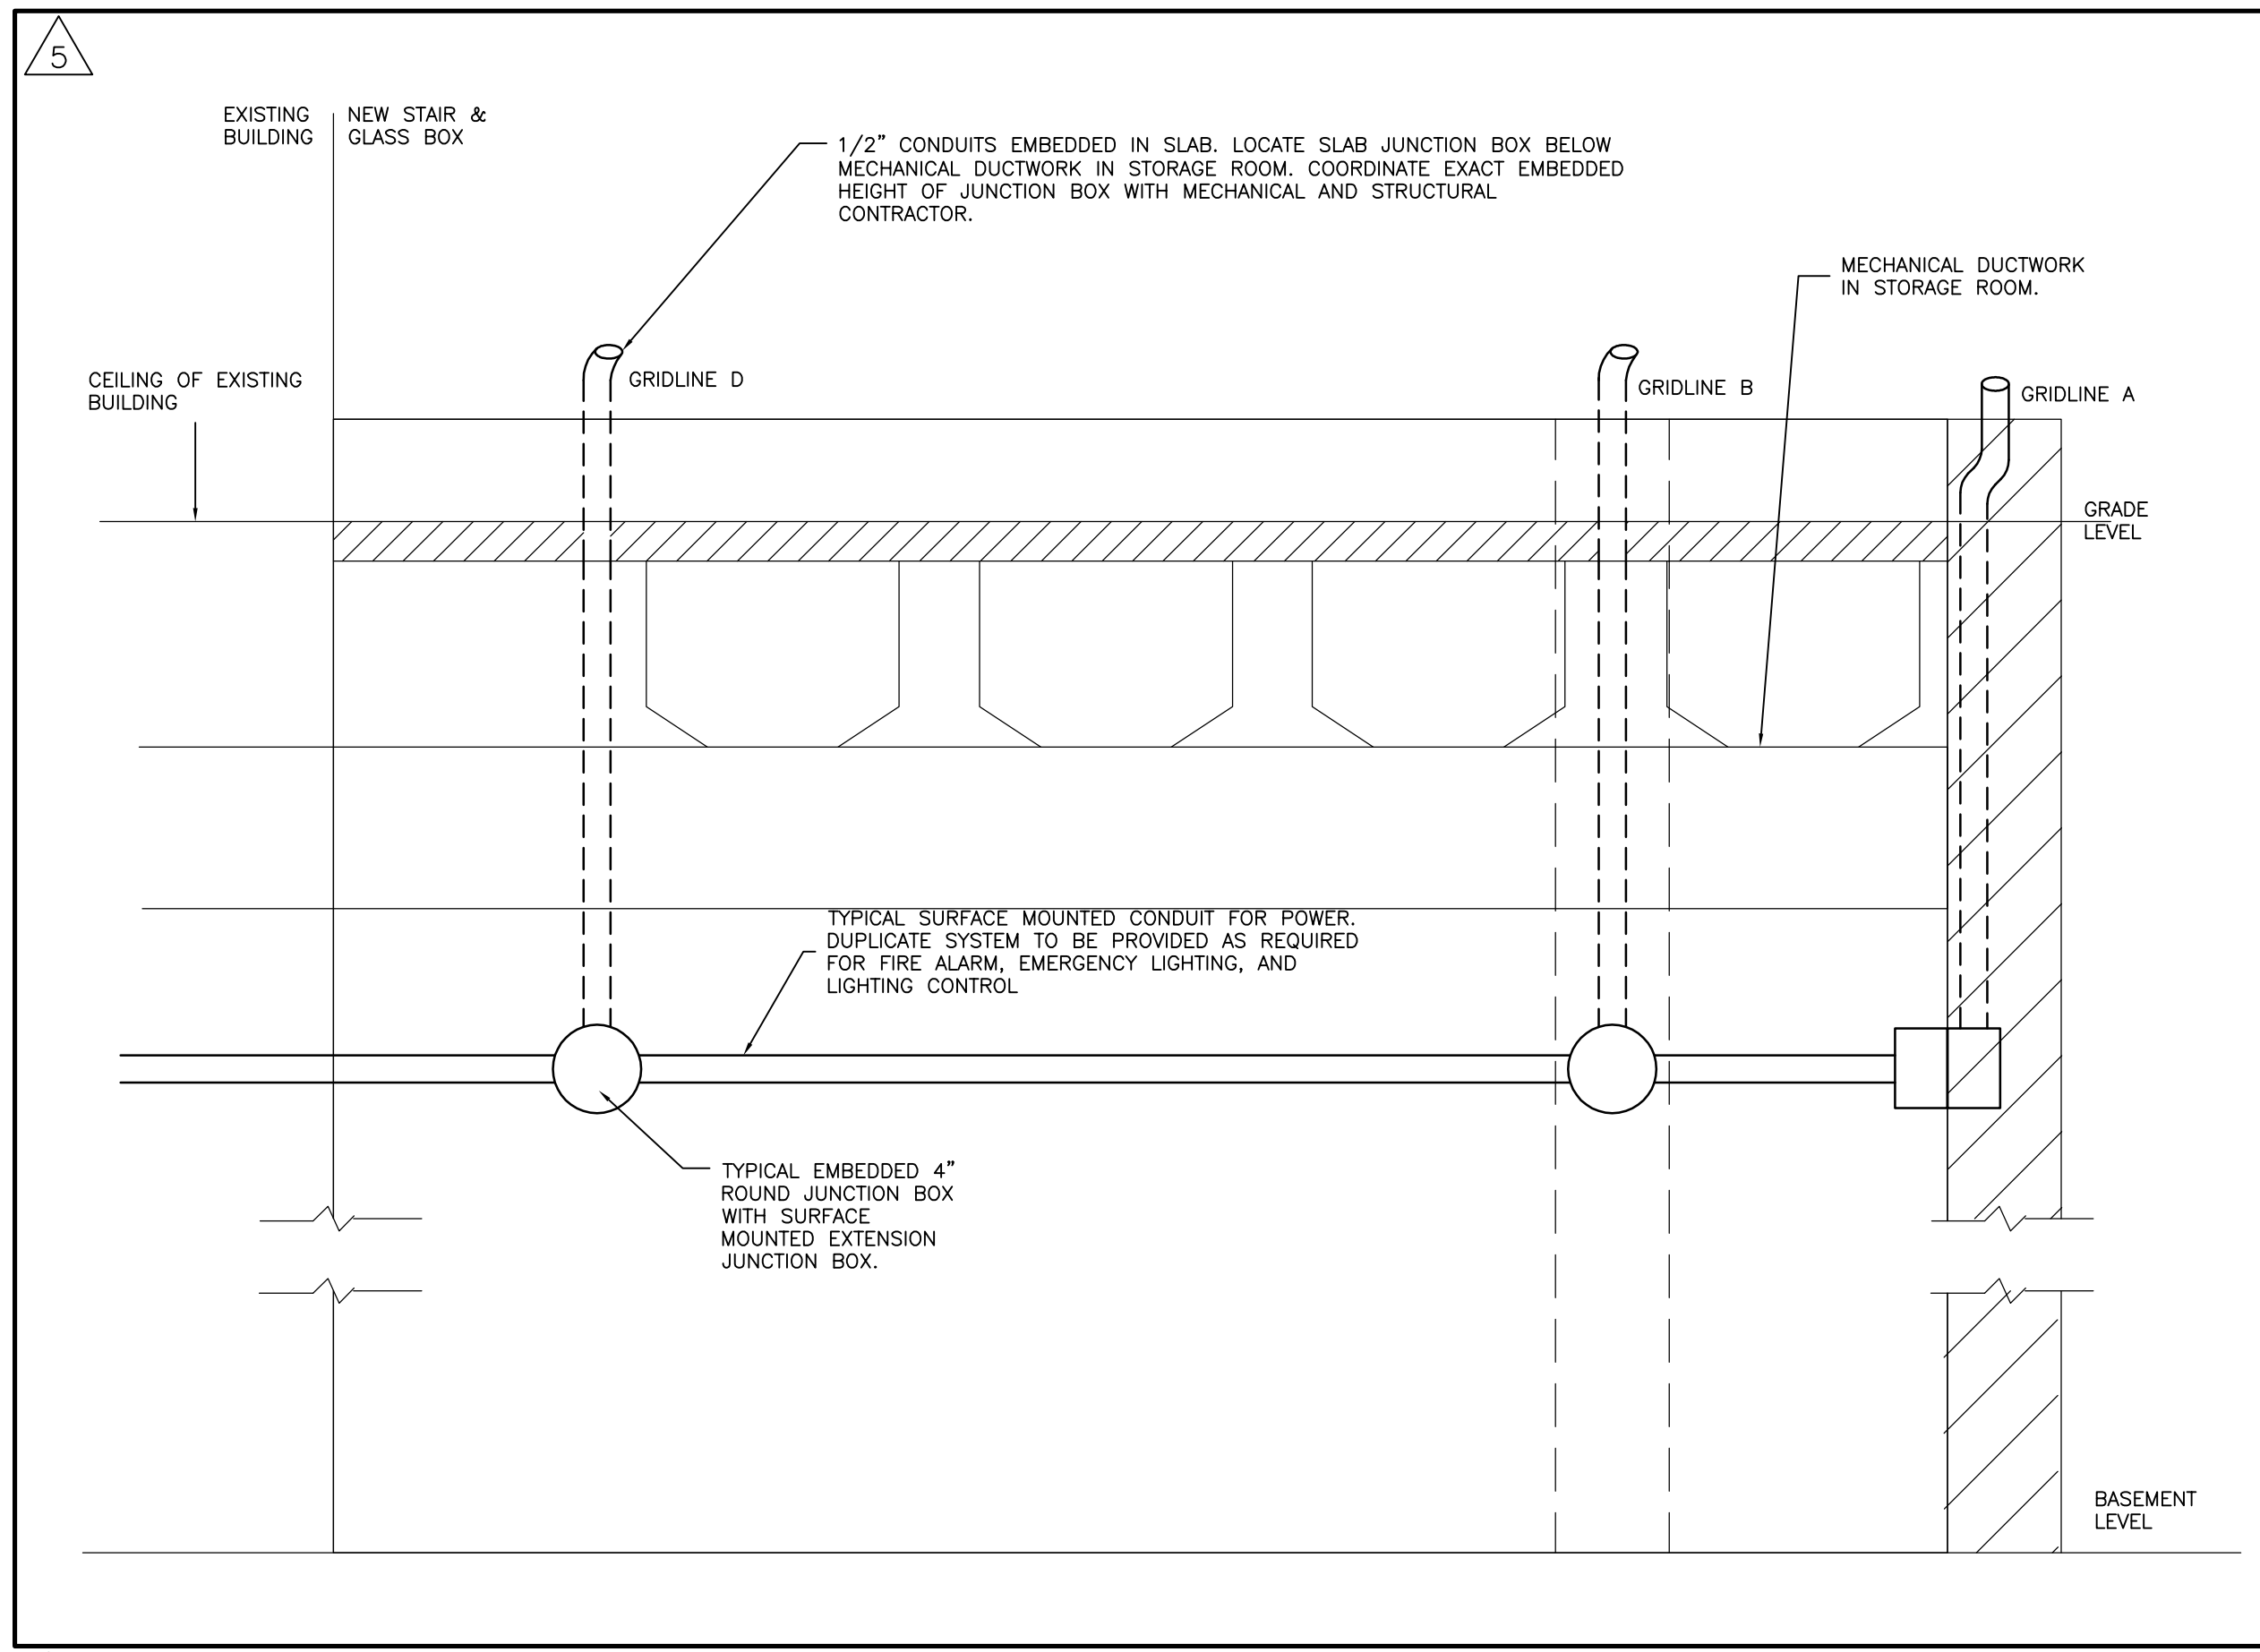


3 ELEVATION DETAIL OF FOUNDATION WALL ALONG GRIDLINE 1
N.T.S.

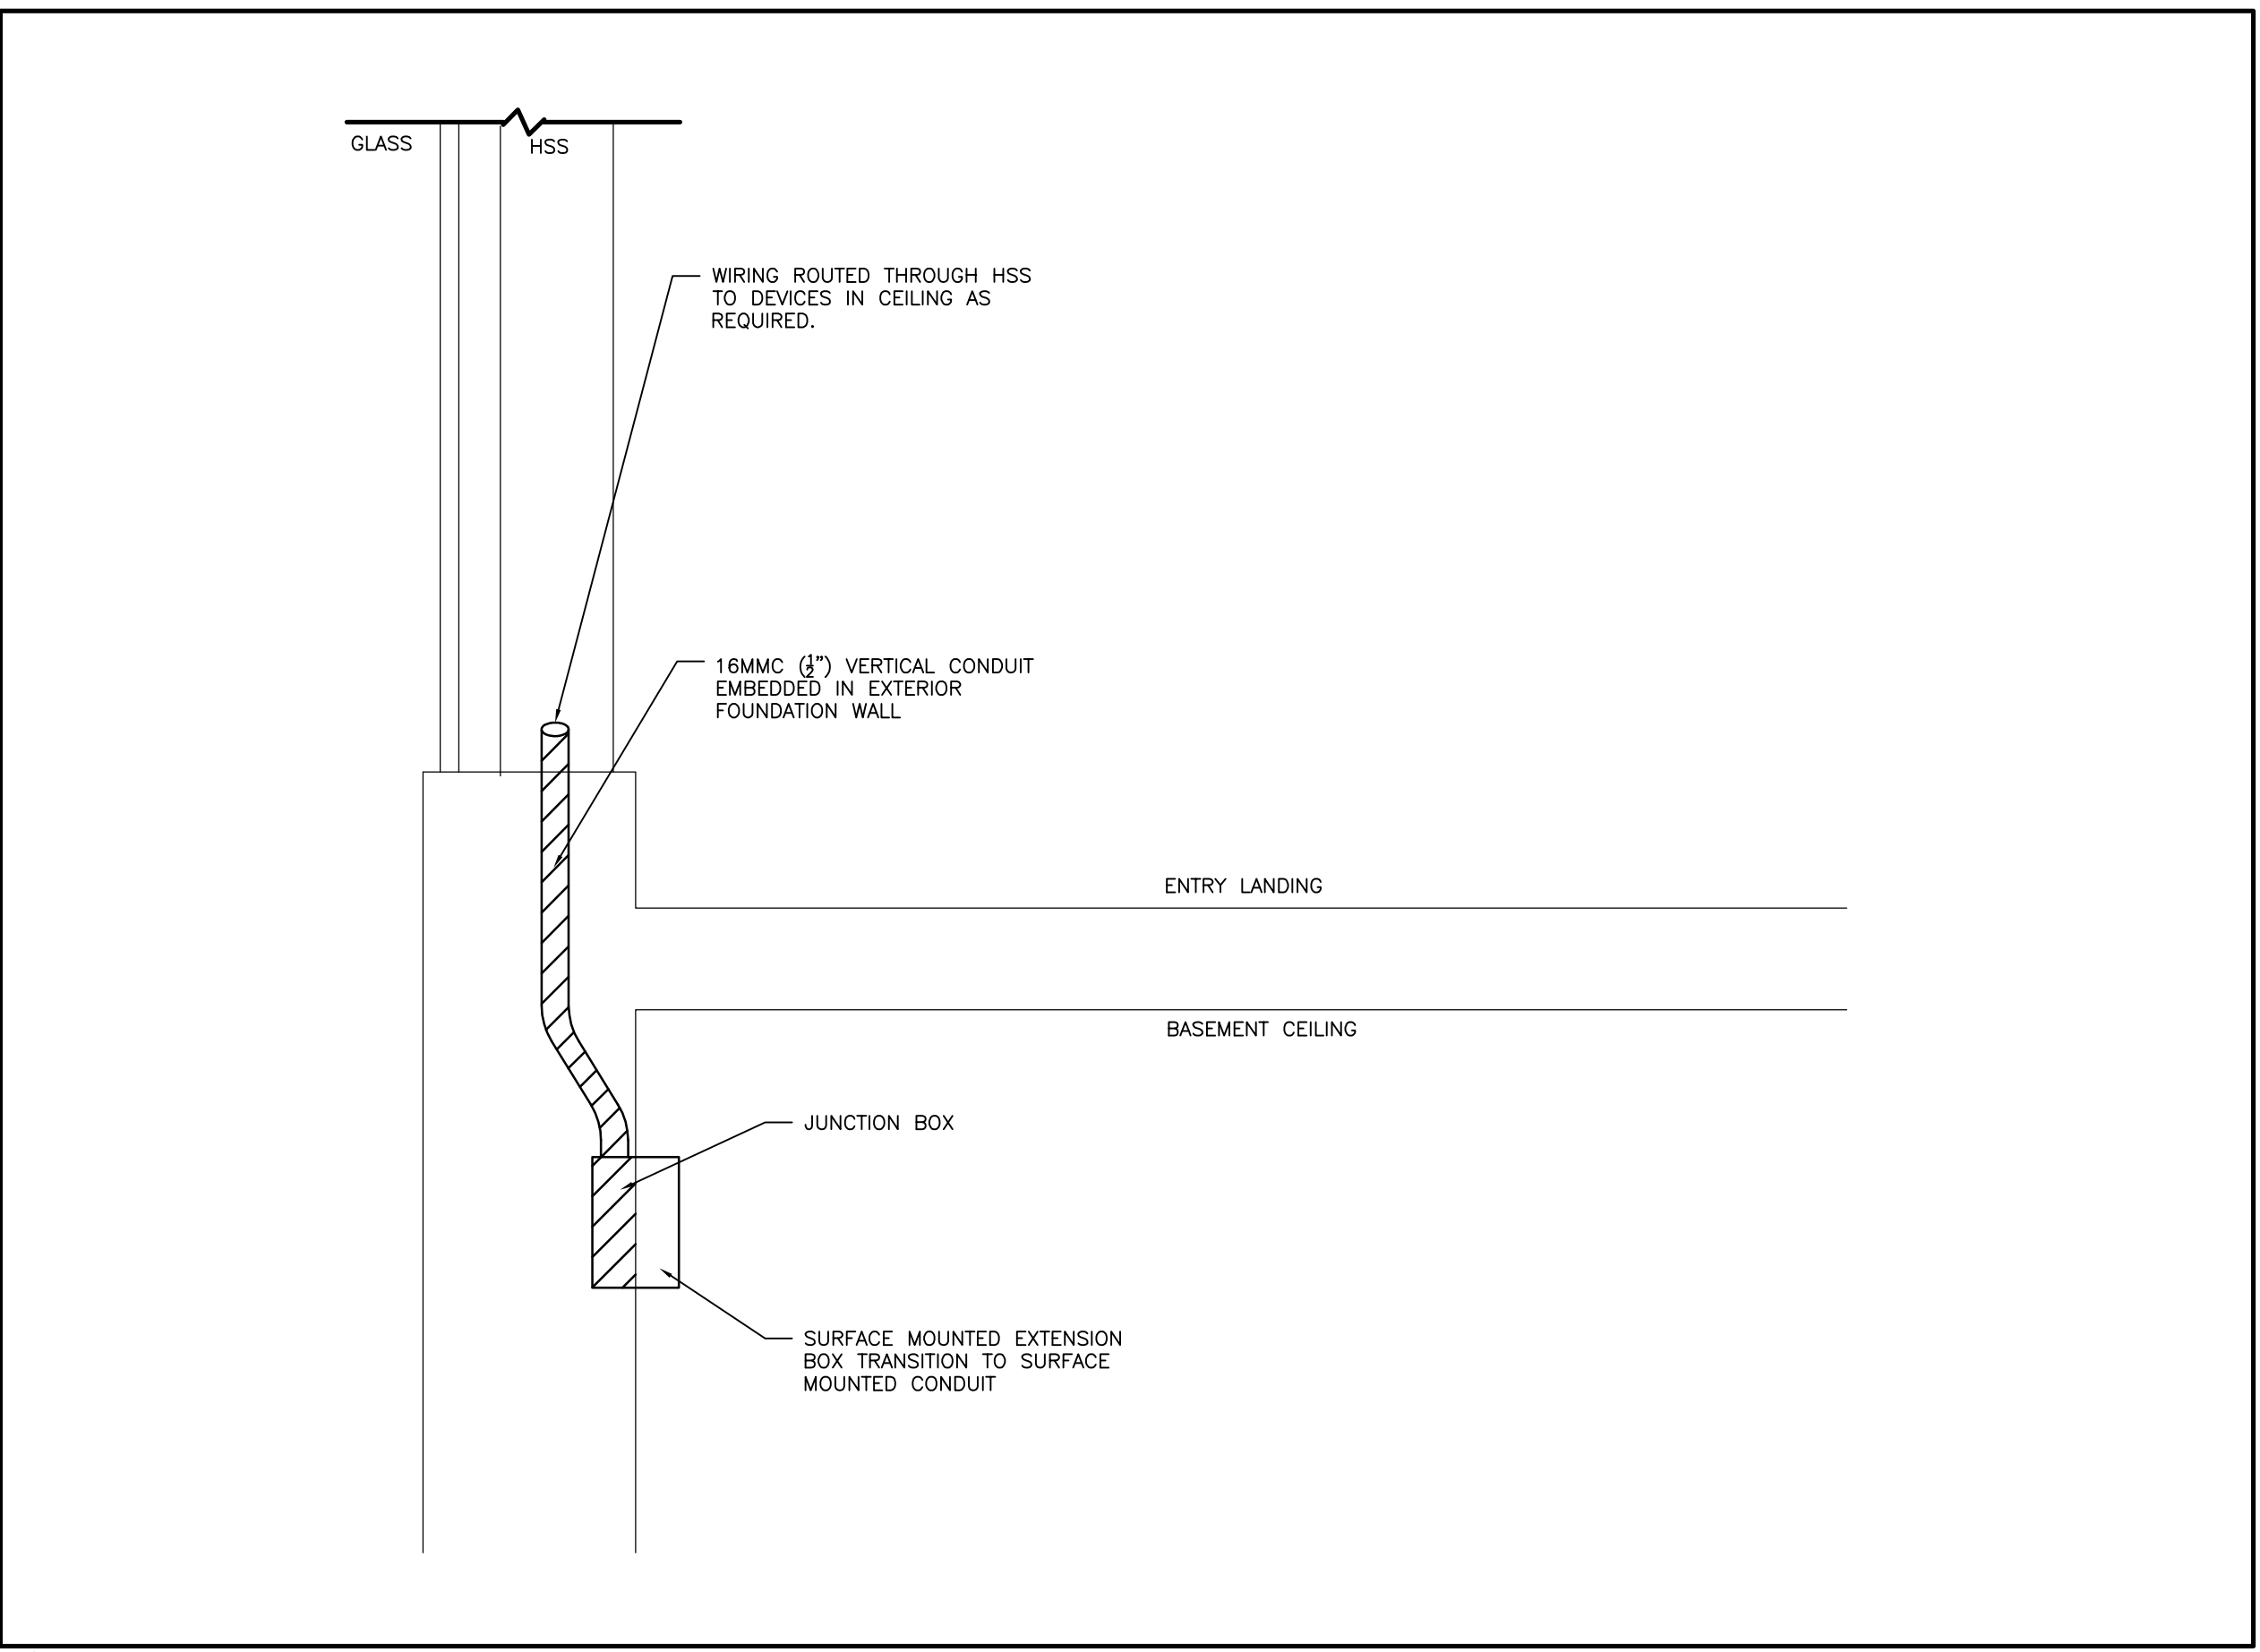

1 SECTION DETAIL OF FOUNDATION WALL ALONG GRIDLINE -1
N.T.S.

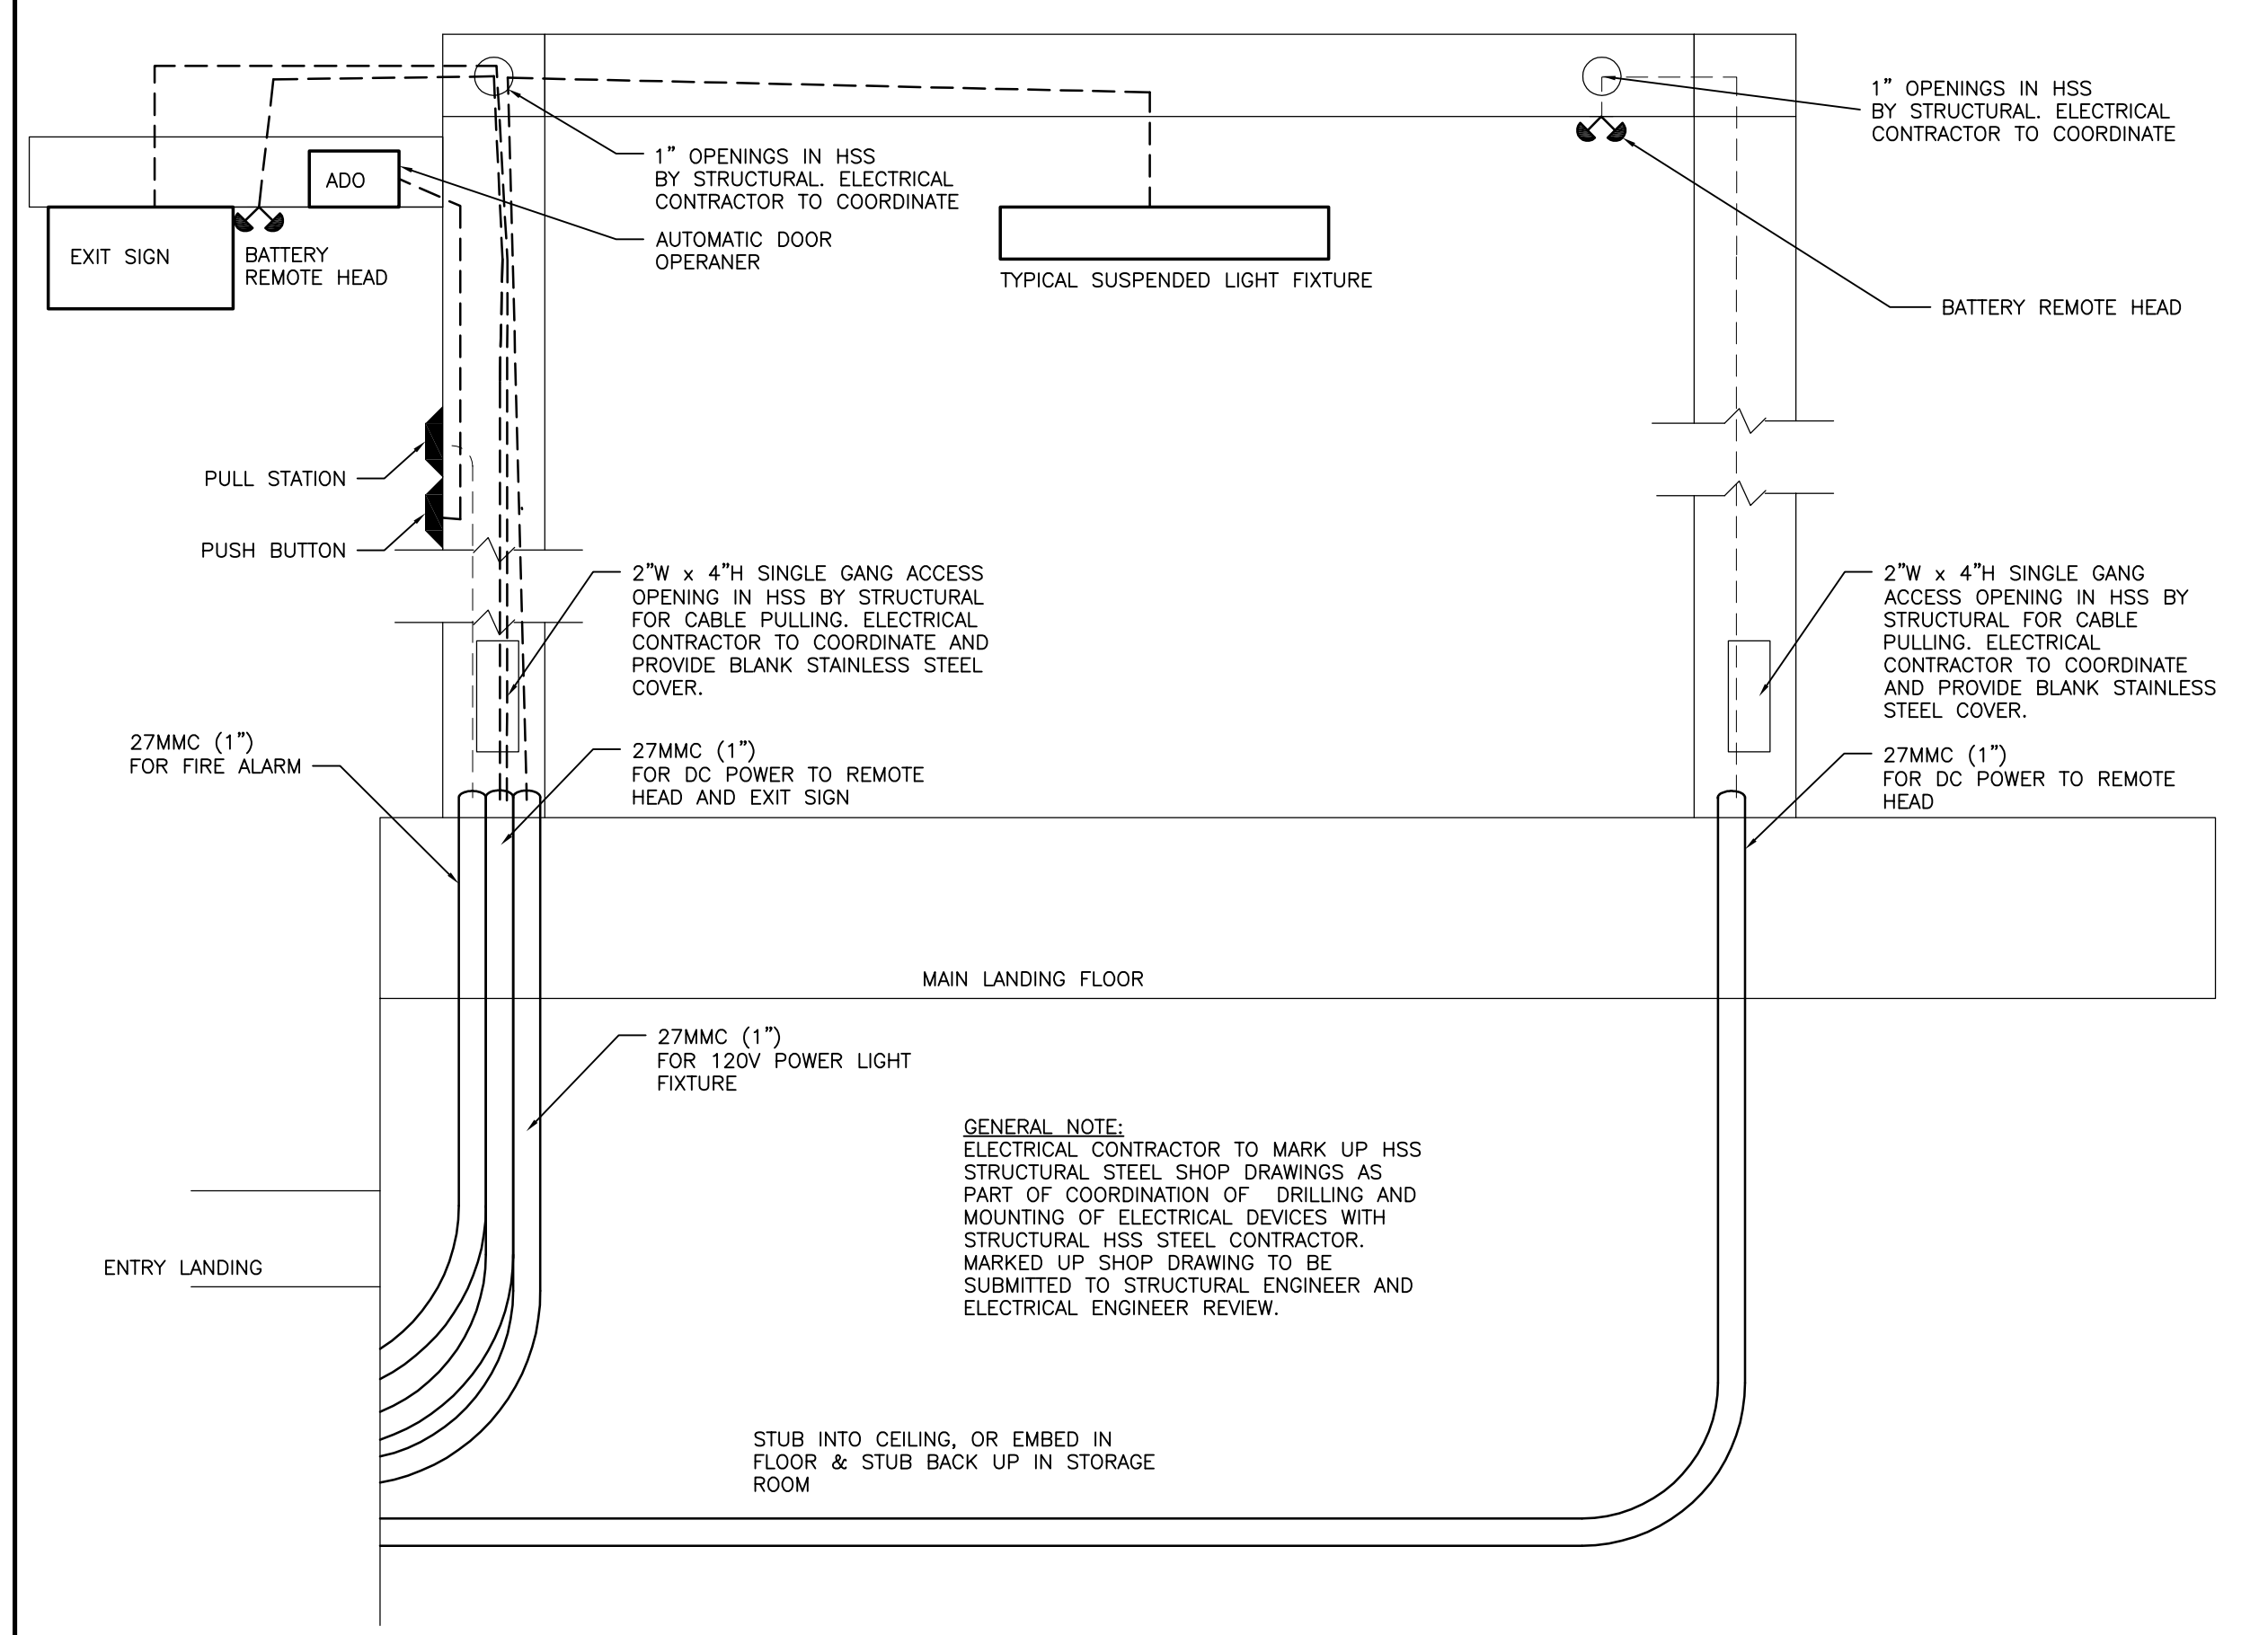

4 TYPICAL CONDUIT STUB AND DEVICE MOUNTING DETAIL INTO HSS
N.T.S.

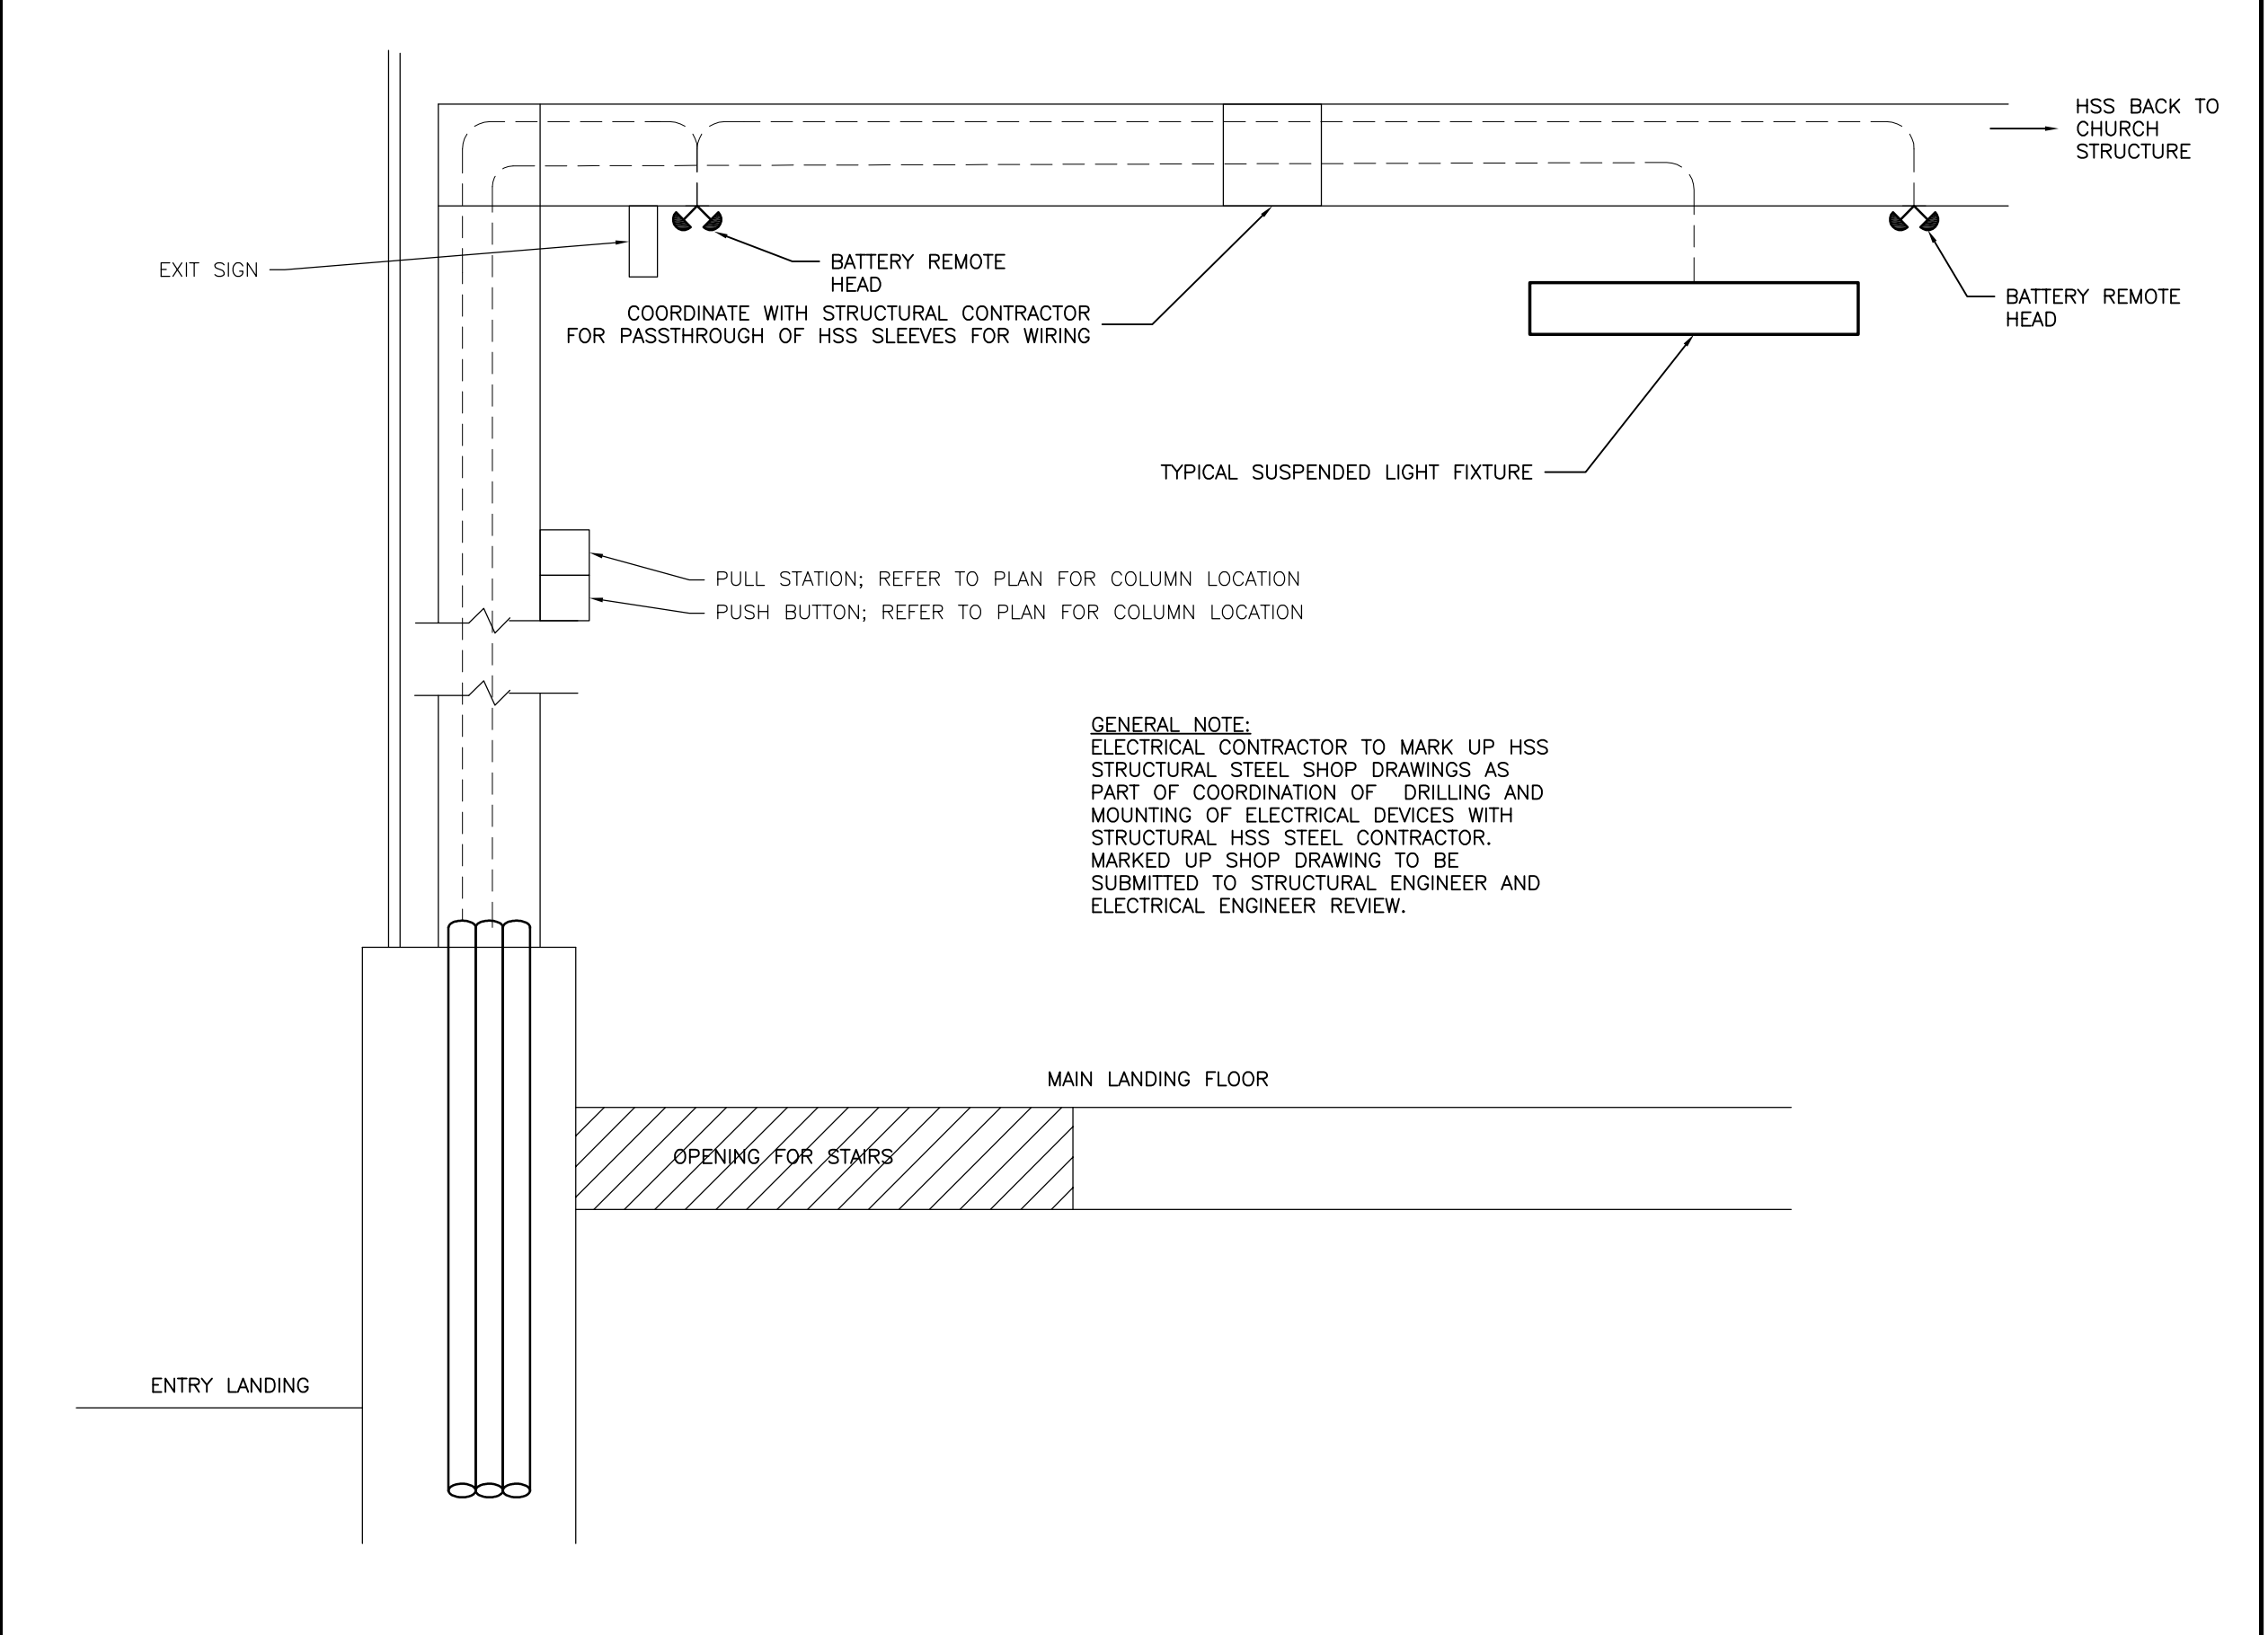

2 TYPICAL CONDUIT STUB AND DEVICE MOUNTING DETAIL INTO HSS
N.T.S.

5.	2016.07.20	ISSUED FOR PTA-E-01
4.	2015.12.04	ISSUED FOR TENDER
3.	2015.10.27	ISSUED FOR PERMIT
2.	2015.05.01	ISSUED FOR PERMIT REVIEW
1.	2015.04.30	ISSUED FOR PROGRESS
REV.	DATE	ISSUED

ALL MEASUREMENTS MUST BE CHECKED ON THE JOB BY THE CONTRACTOR. DRAWINGS MUST NOT BE SCALED. ALL DRAWINGS AND SPECIFICATIONS ARE THE PROPERTY OF THE ARCHITECT AND MUST BE RETURNED UPON REQUEST.

OUR LADY OF PERPETUAL HELP CHURCH RENOVATIONS & ADDITIONS

TORONTO, ONTARIO

Our Lady of Perpetual Help Parish
78 Clifton Road
Toronto, ON M4T 2G2



Smith + Andersen
10320-102 Ave, Suite 501 Edmonton Alberta T5J 4A1
780 701 0331 www.smithandandersen.com

Project Title :


Our Lady of Perpetual Help Addition

Title :

ELECTRICAL DETAILS

Drawn :	AW	Scale :	N.T.S.	Date :	2015.03.12
Project Number :	14214.002.E001	Drawing Number :			
Reviewed By :	AW				E002

22' x 34'

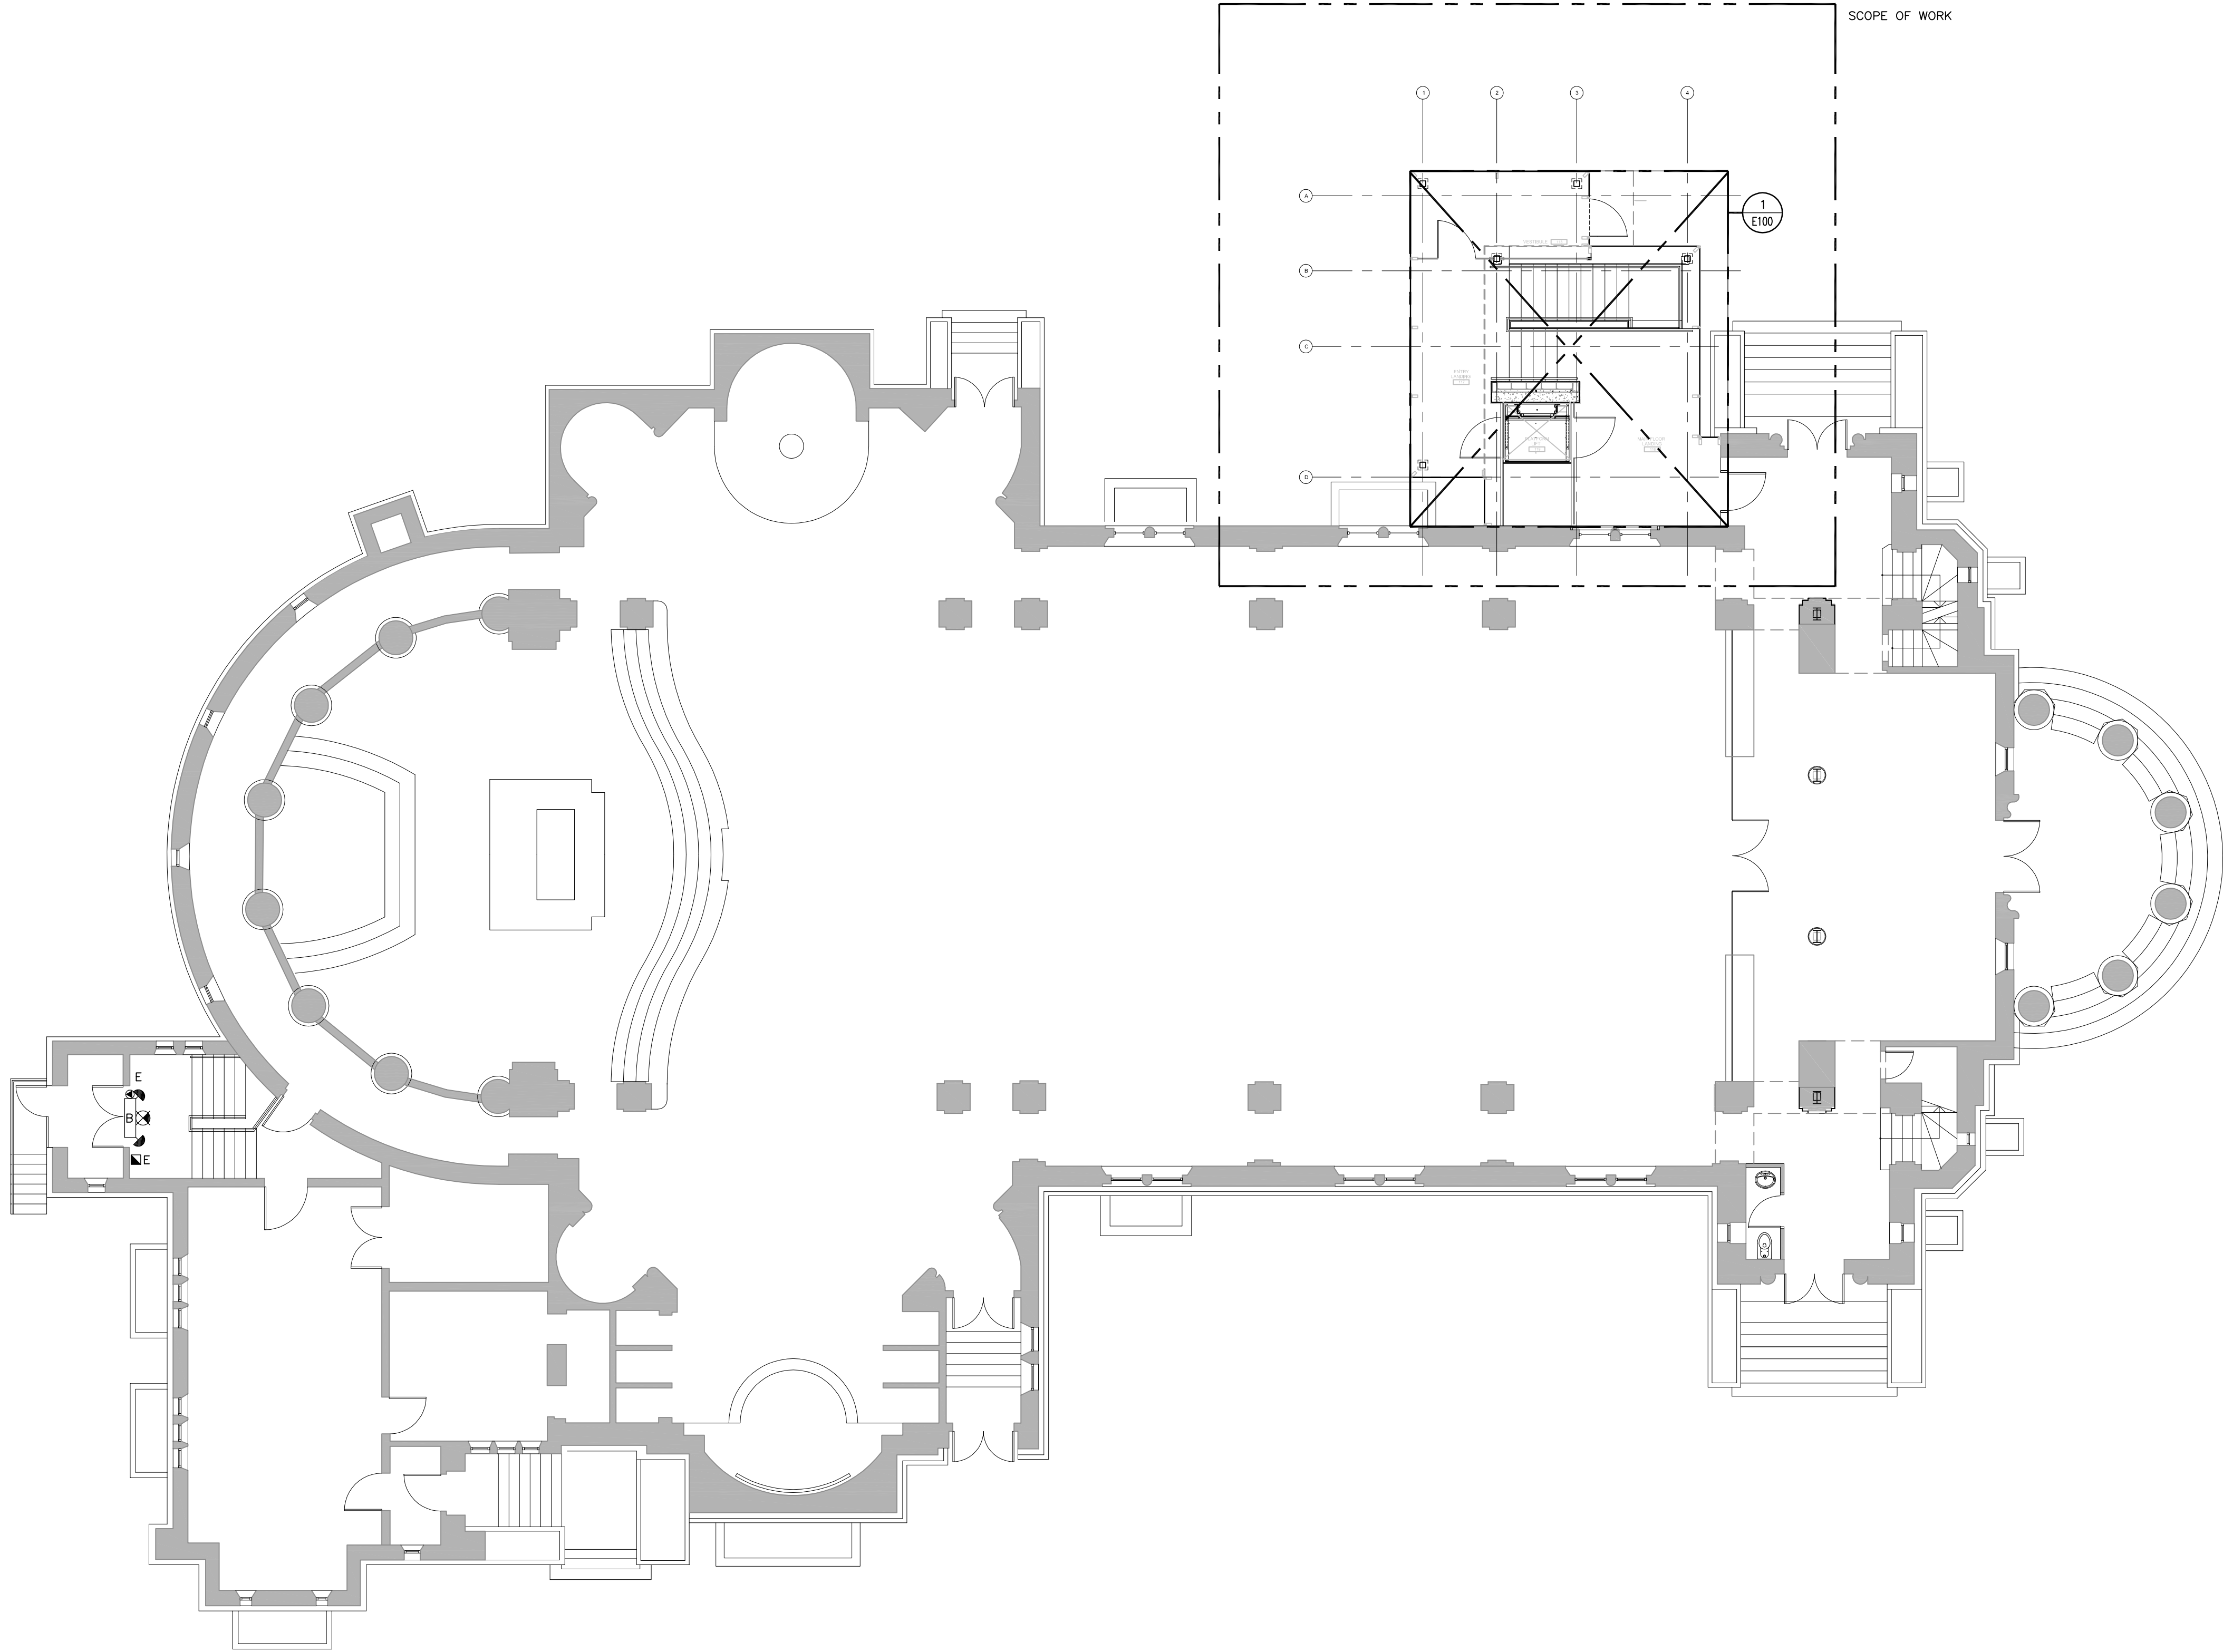

5.	2016.07.20	ISSUED FOR PTA-E-01
4.	2015.12.04	ISSUED FOR TENDER
3.	2015.10.27	ISSUED FOR PERMIT
2.	2015.05.01	ISSUED FOR PERMIT REVIEW
1.	2015.04.30	ISSUED FOR PROGRESS
REV.	DATE	ISSUED

ALL MEASUREMENTS MUST BE CHECKED ON THE JOB BY THE CONTRACTOR. DRAWINGS MUST NOT BE SCALED. ALL DRAWINGS AND SPECIFICATIONS ARE THE PROPERTY OF THE ARCHITECT AND MUST BE RETURNED UPON REQUEST.

OUR LADY OF PERPETUAL HELP CHURCH
RENOVATIONS & ADDITIONS

TORONTO, ONTARIO

Our Lady of Perpetual Help Parish
78 Clifton Road
Toronto, ON M4T 2G2




Smith + Andersen
10520-102 Ave, Suite 501 Edmonton Alberta T5J 4A1
780 701 0331 www.smithandandersen.com


Project Title :
Our Lady of Perpetual Help Addition

Title :
ELECTRICAL GROUND FLOOR PLAN

Drawn : AW	Scale : 1:100	Date : 2015.03.12
Project Number : 14214.002.E001	Drawing Number :	E004
Reviewed By: AW		

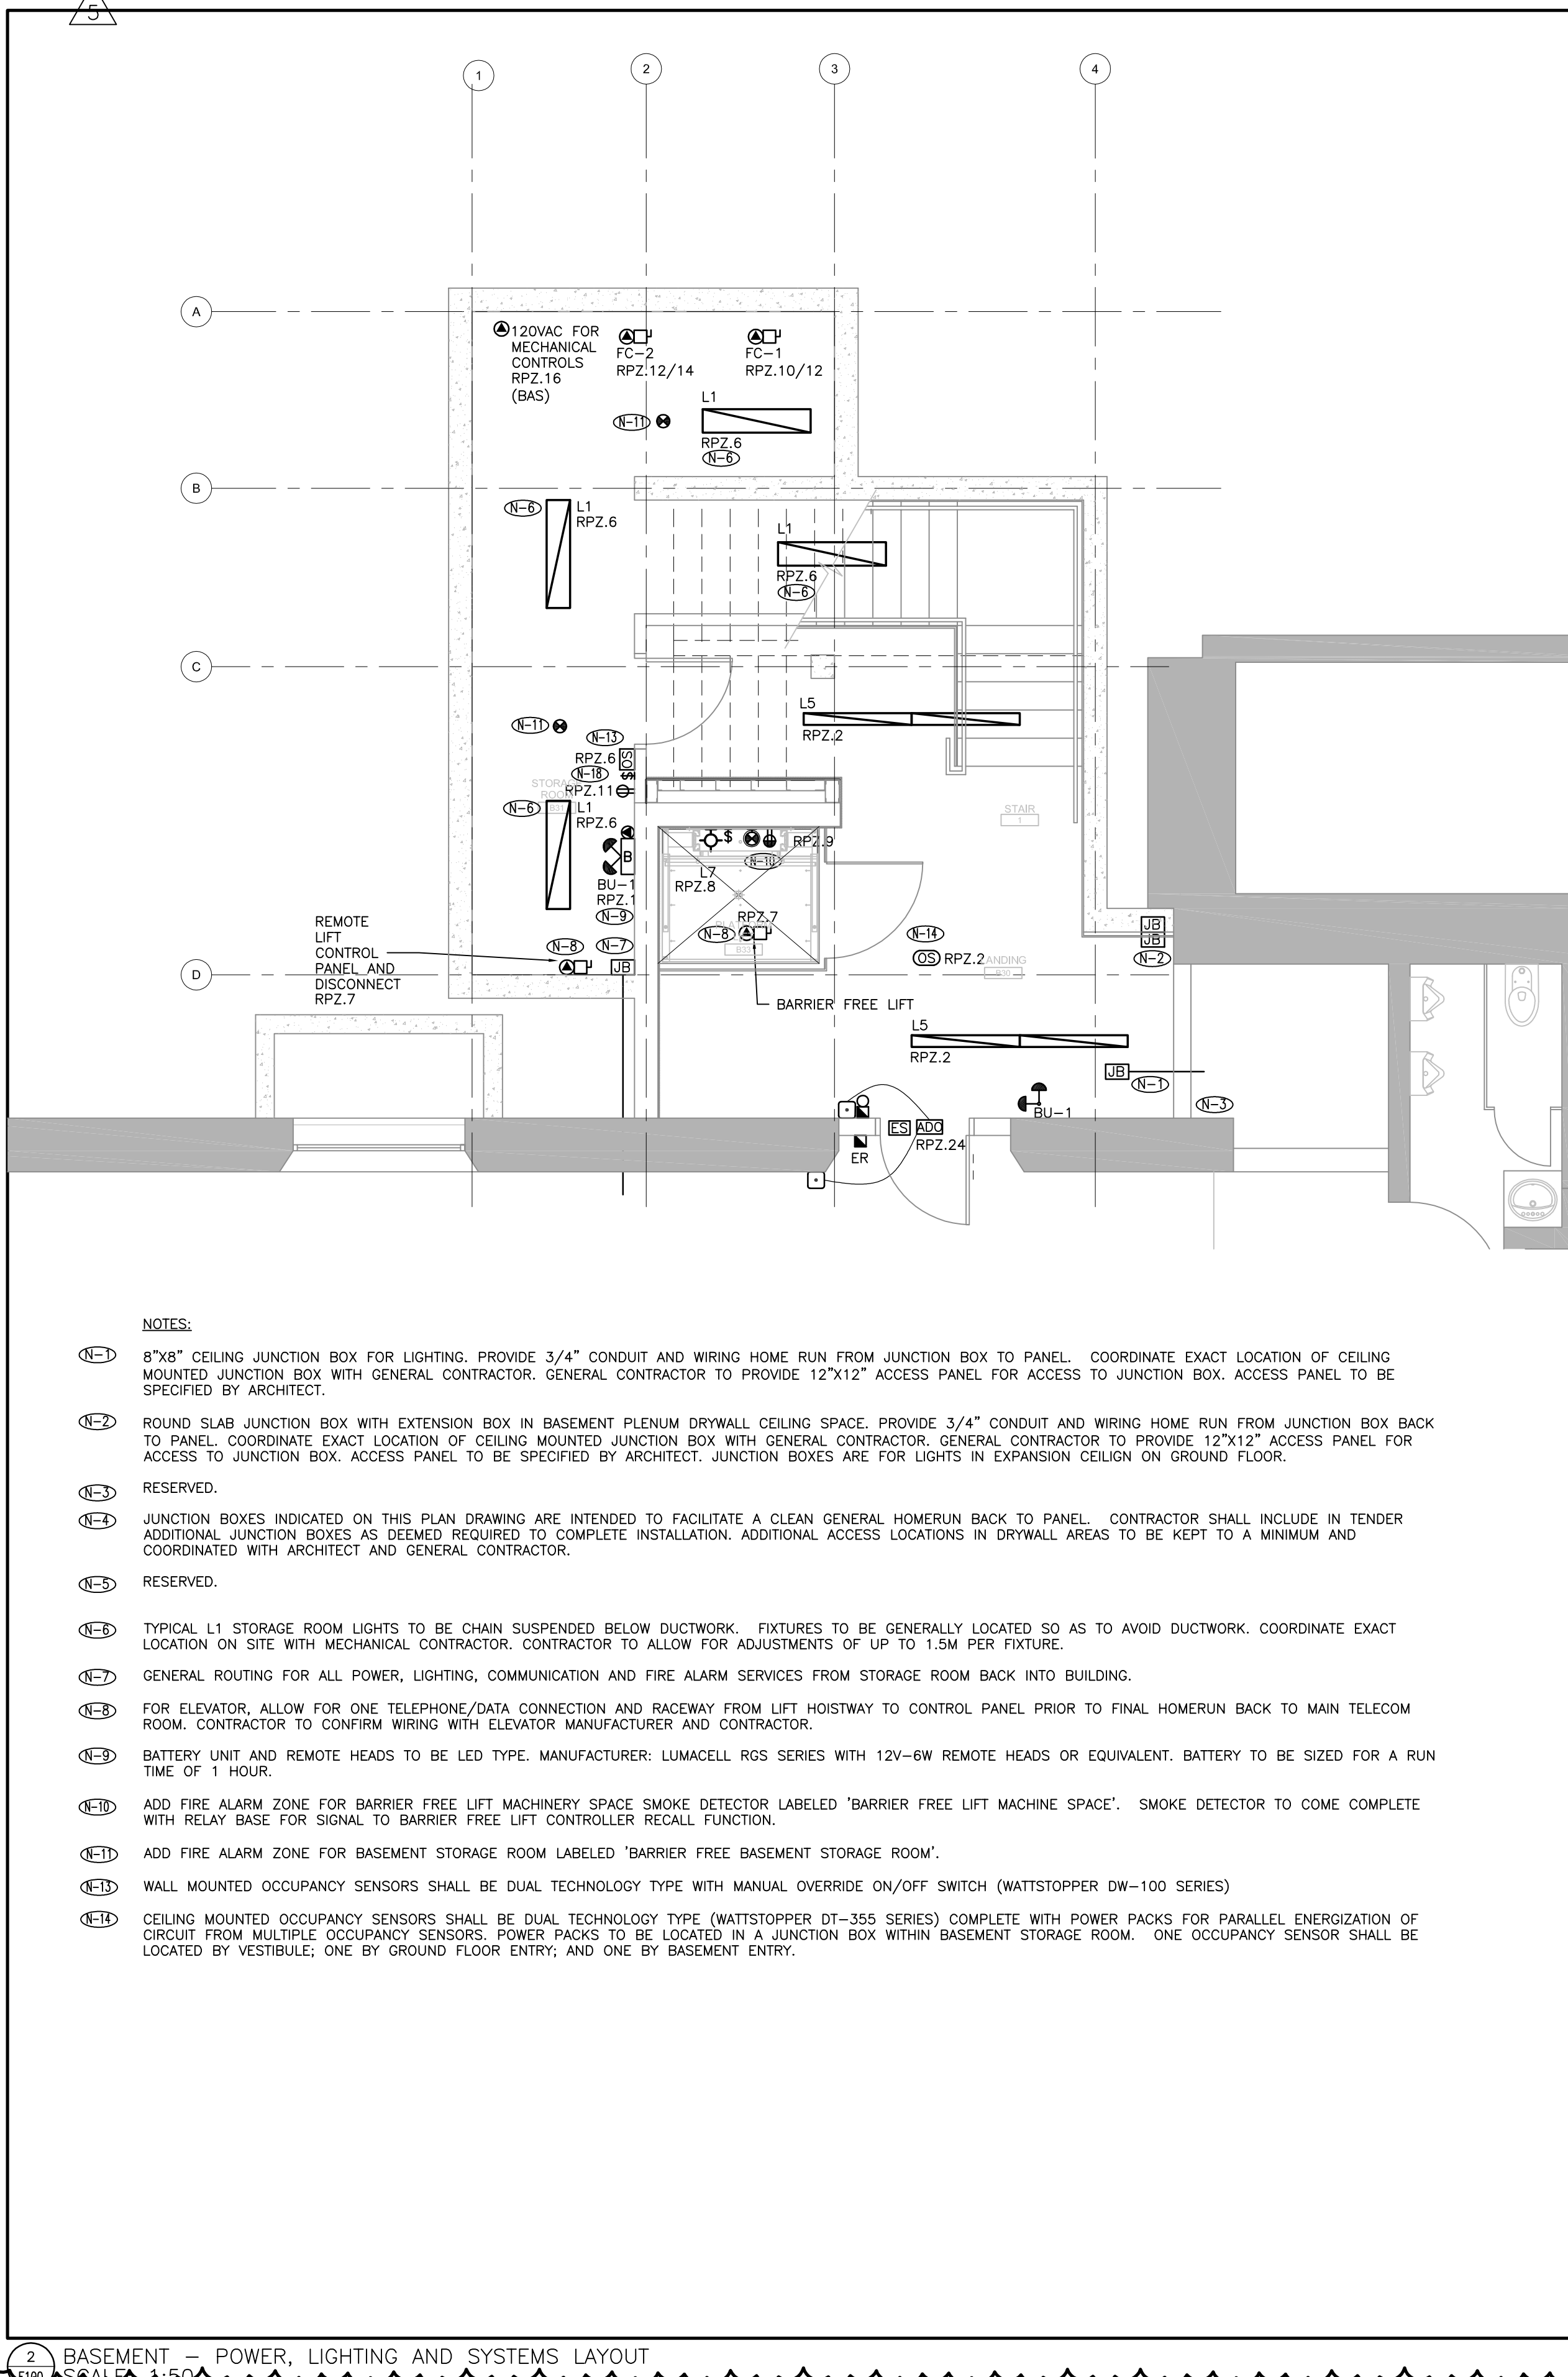

- NOTES:**
- (N-1) 8"x8" CEILING JUNCTION BOX FOR LIGHTING. PROVIDE 3/4" CONDUIT AND WIRING HOME RUN FROM JUNCTION BOX TO PANEL. COORDINATE EXACT LOCATION OF CEILING MOUNTED JUNCTION BOX WITH GENERAL CONTRACTOR. GENERAL CONTRACTOR TO PROVIDE 12"x12" ACCESS PANEL FOR ACCESS TO JUNCTION BOX. ACCESS PANEL TO BE SPECIFIED BY ARCHITECT.
 - (N-2) ROUND SLAB JUNCTION BOX WITH EXTENSION BOX IN BASEMENT PLENUM DRYWALL CEILING SPACE. PROVIDE 3/4" CONDUIT AND WIRING HOME RUN FROM JUNCTION BOX BACK TO PANEL. COORDINATE EXACT LOCATION OF CEILING MOUNTED JUNCTION BOX WITH GENERAL CONTRACTOR. GENERAL CONTRACTOR TO PROVIDE 12"x12" ACCESS PANEL FOR ACCESS TO JUNCTION BOX. ACCESS PANEL TO BE SPECIFIED BY ARCHITECT. JUNCTION BOXES ARE FOR LIGHTS IN EXPANSION CEILING ON GROUND FLOOR.
 - (N-3) RESERVED.
 - (N-4) JUNCTION BOXES INDICATED ON THIS PLAN DRAWING ARE INTENDED TO FACILITATE A CLEAN GENERAL HOMERUN BACK TO PANEL. CONTRACTOR SHALL INCLUDE IN TENDER ADDITIONAL JUNCTION BOXES AS DEEMED REQUIRED TO COMPLETE INSTALLATION. ADDITIONAL ACCESS LOCATIONS IN DRYWALL AREAS TO BE KEPT TO A MINIMUM AND COORDINATED WITH ARCHITECT AND GENERAL CONTRACTOR.
 - (N-5) RESERVED.
 - (N-6) TYPICAL L1 STORAGE ROOM LIGHTS TO BE CHAIN SUSPENDED BELOW DUCTWORK. FIXTURES TO BE GENERALLY LOCATED SO AS TO AVOID DUCTWORK. COORDINATE EXACT LOCATION ON SITE WITH MECHANICAL CONTRACTOR. CONTRACTOR TO ALLOW FOR ADJUSTMENTS OF UP TO 1.5M PER FIXTURE.
 - (N-7) GENERAL ROUTING FOR ALL POWER, LIGHTING, COMMUNICATION AND FIRE ALARM SERVICES FROM STORAGE ROOM BACK INTO BUILDING.
 - (N-8) FOR ELEVATOR, ALLOW FOR ONE TELEPHONE/DATA CONNECTION AND RACEWAY FROM LIFT HOISTWAY TO CONTROL PANEL PRIOR TO FINAL HOMERUN BACK TO MAIN TELECOM ROOM. CONTRACTOR TO CONFIRM WIRING WITH ELEVATOR MANUFACTURER AND CONTRACTOR.
 - (N-9) BATTERY UNIT AND REMOTE HEADS TO BE LED TYPE. MANUFACTURER: LUMACELL RGS SERIES WITH 12V-6W REMOTE HEADS OR EQUIVALENT. BATTERY TO BE SIZED FOR A RUN TIME OF 1 HOUR.
 - (N-10) ADD FIRE ALARM ZONE FOR BARRIER FREE LIFT MACHINERY SPACE SMOKE DETECTOR LABELED 'BARRIER FREE LIFT MACHINE SPACE'. SMOKE DETECTOR TO COME COMPLETE WITH RELAY BASE FOR SIGNAL TO BARRIER FREE LIFT CONTROLLER RECALL FUNCTION.
 - (N-11) ADD FIRE ALARM ZONE FOR BASEMENT STORAGE ROOM LABELED 'BARRIER FREE BASEMENT STORAGE ROOM'.
 - (N-12) WALL MOUNTED OCCUPANCY SENSORS SHALL BE DUAL TECHNOLOGY TYPE WITH MANUAL OVERRIDE ON/OFF SWITCH (WATTSTOPPER DW-100 SERIES)
 - (N-13) CEILING MOUNTED OCCUPANCY SENSORS SHALL BE DUAL TECHNOLOGY TYPE (WATTSTOPPER DT-355 SERIES) COMPLETE WITH POWER PACKS FOR PARALLEL ENERGIZATION OF CIRCUIT FROM MULTIPLE OCCUPANCY SENSORS. POWER PACKS TO BE LOCATED IN A JUNCTION BOX WITHIN BASEMENT STORAGE ROOM. ONE OCCUPANCY SENSOR SHALL BE LOCATED BY VESTIBULE; ONE BY GROUND FLOOR ENTRY; AND ONE BY BASEMENT ENTRY.

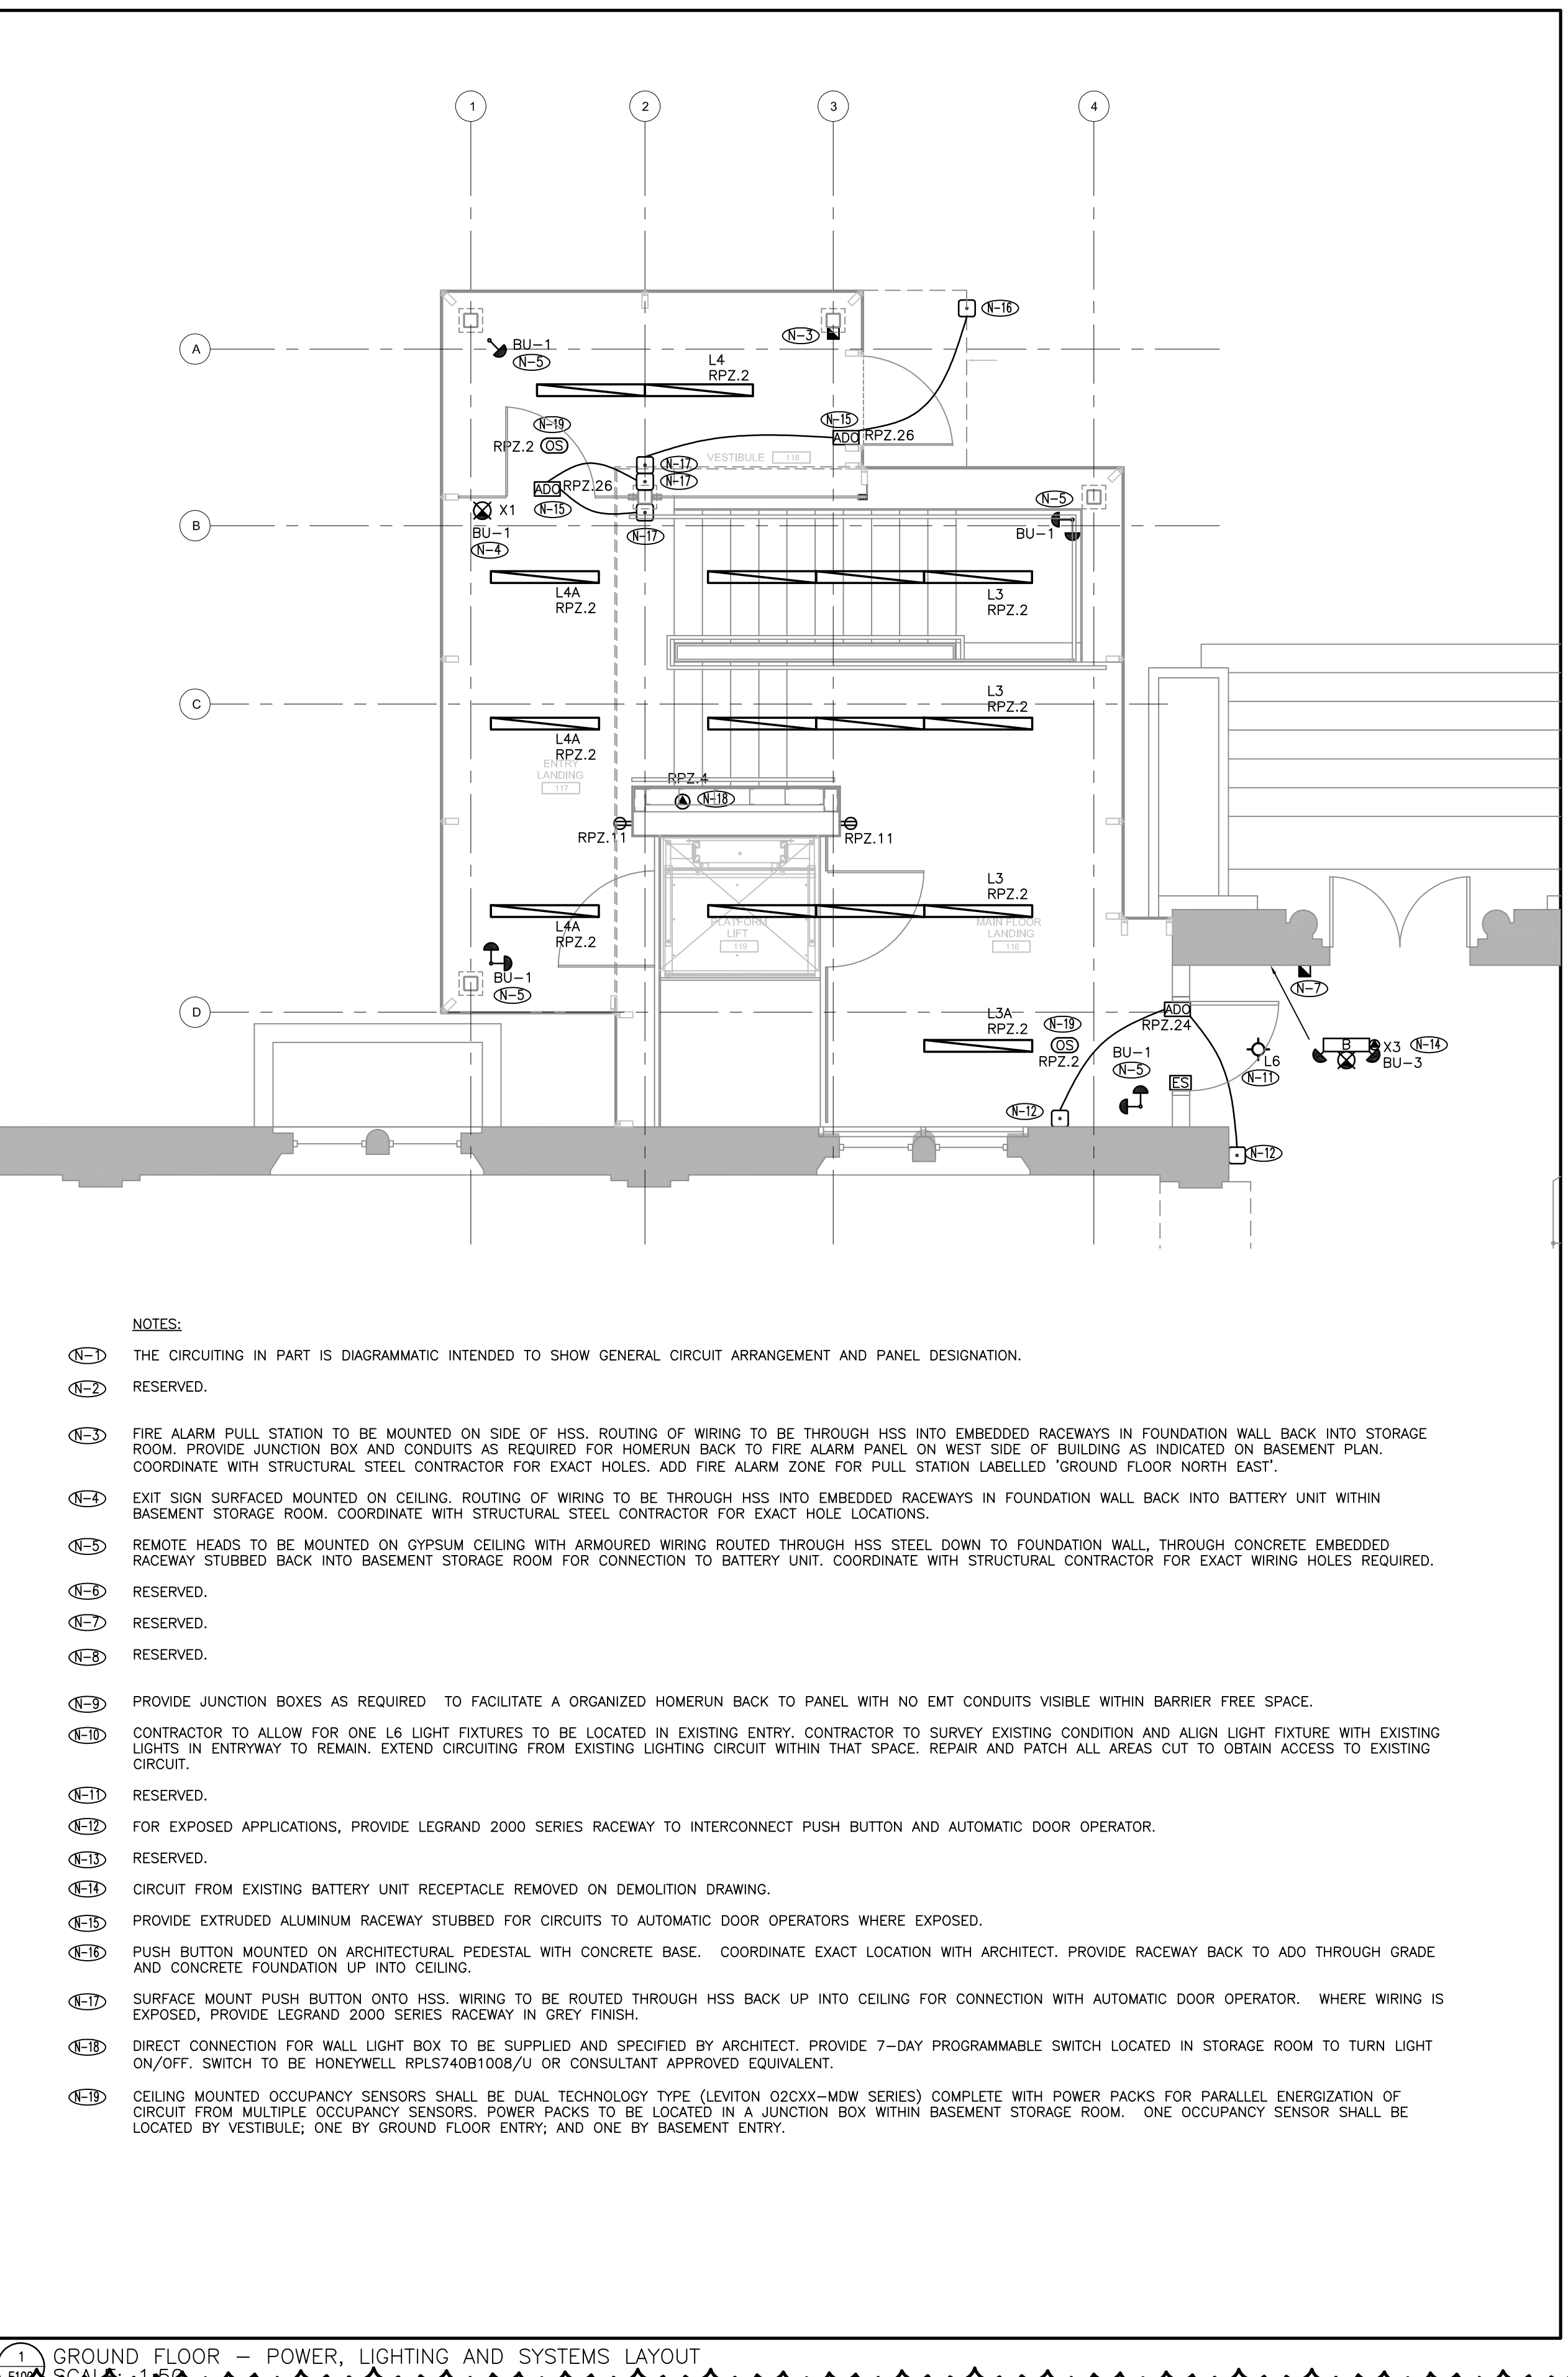

- NOTES:**
- (N-1) THE CIRCUITING IN PART IS DIAGRAMMATIC INTENDED TO SHOW GENERAL CIRCUIT ARRANGEMENT AND PANEL DESIGNATION.
 - (N-2) RESERVED.
 - (N-3) FIRE ALARM PULL STATION TO BE MOUNTED ON SIDE OF HSS. ROUTING OF WIRING TO BE THROUGH HSS INTO EMBEDDED RACEWAYS IN FOUNDATION WALL BACK INTO STORAGE ROOM. PROVIDE JUNCTION BOX AND CONDUITS AS REQUIRED FOR HOMERUN BACK TO FIRE ALARM PANEL ON WEST SIDE OF BUILDING AS INDICATED ON BASEMENT PLAN. COORDINATE WITH STRUCTURAL STEEL CONTRACTOR FOR EXACT HOLES. ADD FIRE ALARM ZONE FOR PULL STATION LABELED 'GROUND FLOOR NORTH EAST'.
 - (N-4) EXIT SIGN SURFACED MOUNTED ON CEILING. ROUTING OF WIRING TO BE THROUGH HSS INTO EMBEDDED RACEWAYS IN FOUNDATION WALL BACK INTO BATTERY UNIT WITHIN BASEMENT STORAGE ROOM. COORDINATE WITH STRUCTURAL STEEL CONTRACTOR FOR EXACT HOLE LOCATIONS.
 - (N-5) REMOTE HEADS TO BE MOUNTED ON GYPSUM CEILING WITH ARMoured WIRING ROUTED THROUGH HSS STEEL DOWN TO FOUNDATION WALL, THROUGH CONCRETE EMBEDDED RACEWAY STUBBED BACK INTO BASEMENT STORAGE ROOM FOR CONNECTION TO BATTERY UNIT. COORDINATE WITH STRUCTURAL CONTRACTOR FOR EXACT WIRING HOLES REQUIRED.
 - (N-6) RESERVED.
 - (N-7) RESERVED.
 - (N-8) RESERVED.
 - (N-9) PROVIDE JUNCTION BOXES AS REQUIRED TO FACILITATE A ORGANIZED HOMERUN BACK TO PANEL WITH NO EMT CONDUITS VISIBLE WITHIN BARRIER FREE SPACE.
 - (N-10) CONTRACTOR TO ALLOW FOR ONE L6 LIGHT FIXTURES TO BE LOCATED IN EXISTING ENTRY. CONTRACTOR TO SURVEY EXISTING CONDITION AND ALIGN LIGHT FIXTURE WITH EXISTING LIGHTS IN ENTRYWAY TO REMAIN. EXTEND CIRCUITING FROM EXISTING LIGHTING CIRCUIT WITHIN THAT SPACE. REPAIR AND PATCH ALL AREAS CUT TO OBTAIN ACCESS TO EXISTING CIRCUIT.
 - (N-11) RESERVED.
 - (N-12) FOR EXPOSED APPLICATIONS, PROVIDE LEGRAND 2000 SERIES RACEWAY TO INTERCONNECT PUSH BUTTON AND AUTOMATIC DOOR OPERATOR.
 - (N-13) RESERVED.
 - (N-14) CIRCUIT FROM EXISTING BATTERY UNIT RECEPTACLE REMOVED ON DEMOLITION DRAWING.
 - (N-15) PROVIDE EXTRUDED ALUMINUM RACEWAY STUBBED FOR CIRCUITS TO AUTOMATIC DOOR OPERATORS WHERE EXPOSED.
 - (N-16) PUSH BUTTON MOUNTED ON ARCHITECTURAL PEDESTAL WITH CONCRETE BASE. COORDINATE EXACT LOCATION WITH ARCHITECT. PROVIDE RACEWAY BACK TO ADD THROUGH GRADE AND CONCRETE FOUNDATION UP INTO CEILING.
 - (N-17) SURFACE MOUNT PUSH BUTTON ONTO HSS. WIRING TO BE ROUTED THROUGH HSS BACK UP INTO CEILING FOR CONNECTION WITH AUTOMATIC DOOR OPERATOR. WHERE WIRING IS EXPOSED, PROVIDE LEGRAND 2000 SERIES RACEWAY IN GREY FINISH.
 - (N-18) DIRECT CONNECTION FOR WALL LIGHT BOX TO BE SUPPLIED AND SPECIFIED BY ARCHITECT. PROVIDE 7-DAY PROGRAMMABLE SWITCH LOCATED IN STORAGE ROOM TO TURN LIGHT ON/OFF. SWITCH TO BE HONEYWELL RPLS740B1008/U OR CONSULTANT APPROVED EQUIVALENT.
 - (N-19) CEILING MOUNTED OCCUPANCY SENSORS SHALL BE DUAL TECHNOLOGY TYPE (LEVITON O2CXX-MDW SERIES) COMPLETE WITH POWER PACKS FOR PARALLEL ENERGIZATION OF CIRCUIT FROM MULTIPLE OCCUPANCY SENSORS. POWER PACKS TO BE LOCATED IN A JUNCTION BOX WITHIN BASEMENT STORAGE ROOM. ONE OCCUPANCY SENSOR SHALL BE LOCATED BY VESTIBULE; ONE BY GROUND FLOOR ENTRY; AND ONE BY BASEMENT ENTRY.

5.	2016.07.20	ISSUED FOR PTA-E-01
4.	2015.12.04	ISSUED FOR TENDER
3.	2015.10.27	ISSUED FOR PERMIT
2.	2015.05.01	ISSUED FOR PERMIT REVIEW
1.	2015.04.30	ISSUED FOR PROGRESS
REV.	DATE	ISSUED

ALL MEASUREMENTS MUST BE CHECKED ON THE JOB BY THE CONTRACTOR. DRAWINGS MUST NOT BE SCALED. ALL DRAWINGS AND SPECIFICATIONS ARE THE PROPERTY OF THE ARCHITECT AND MUST BE RETURNED UPON REQUEST.

OUR LADY OF PERPETUAL HELP CHURCH RENOVATIONS & ADDITIONS

TORONTO, ONTARIO

Our Lady of Perpetual Help Parish
78 Clifton Road
Toronto, ON M4T 2G2



Project Title :

Our Lady of Perpetual Help Addition

Title :
POWER, LIGHTING AND SYSTEMS PLAN

Drawn : AW	Scale : 1:50	Date : 2015.03.12
Project Number : 14214.002.E001	Drawing Number :	E100
Reviewed By: AW		

5.	2016.07.20	ISSUED FOR PTA-E-01
4.	2015.12.04	ISSUED FOR TENDER
3.	2015.10.27	ISSUED FOR PERMIT
2.	2015.05.01	ISSUED FOR PERMIT REVIEW
1.	2015.04.30	ISSUED FOR PROGRESS
REV.	DATE	ISSUED

ALL MEASUREMENTS MUST BE CHECKED ON THE JOB BY THE CONTRACTOR. DRAWINGS MUST NOT BE SCALED. ALL DRAWINGS AND SPECIFICATIONS ARE THE PROPERTY OF THE ARCHITECT AND MUST BE RETURNED UPON REQUEST.

OUR LADY OF
PERPETUAL HELP CHURCH
RENOVATIONS & ADDITIONS

TORONTO, ONTARIO

Our Lady of Perpetual Help Parish
78 Clifton Road
Toronto, ON M4T 2G2




Smith + Andersen
10320-102 Ave, Suite 501 Edmonton Alberta T5J 4A1
780 701 0331 www.smithandandersen.com

Project Title :
**Our Lady of Perpetual Help
Addition**

Title :
**POWER, LIGHTING, AND SYSTEMS
DEMOLITION PLAN**


Drawn :	AW	Scale :	1:50	Date :	2015.03.12
Project Number :	14214.002.E001	Drawing Number :			
Reviewed By :	AW				ED100

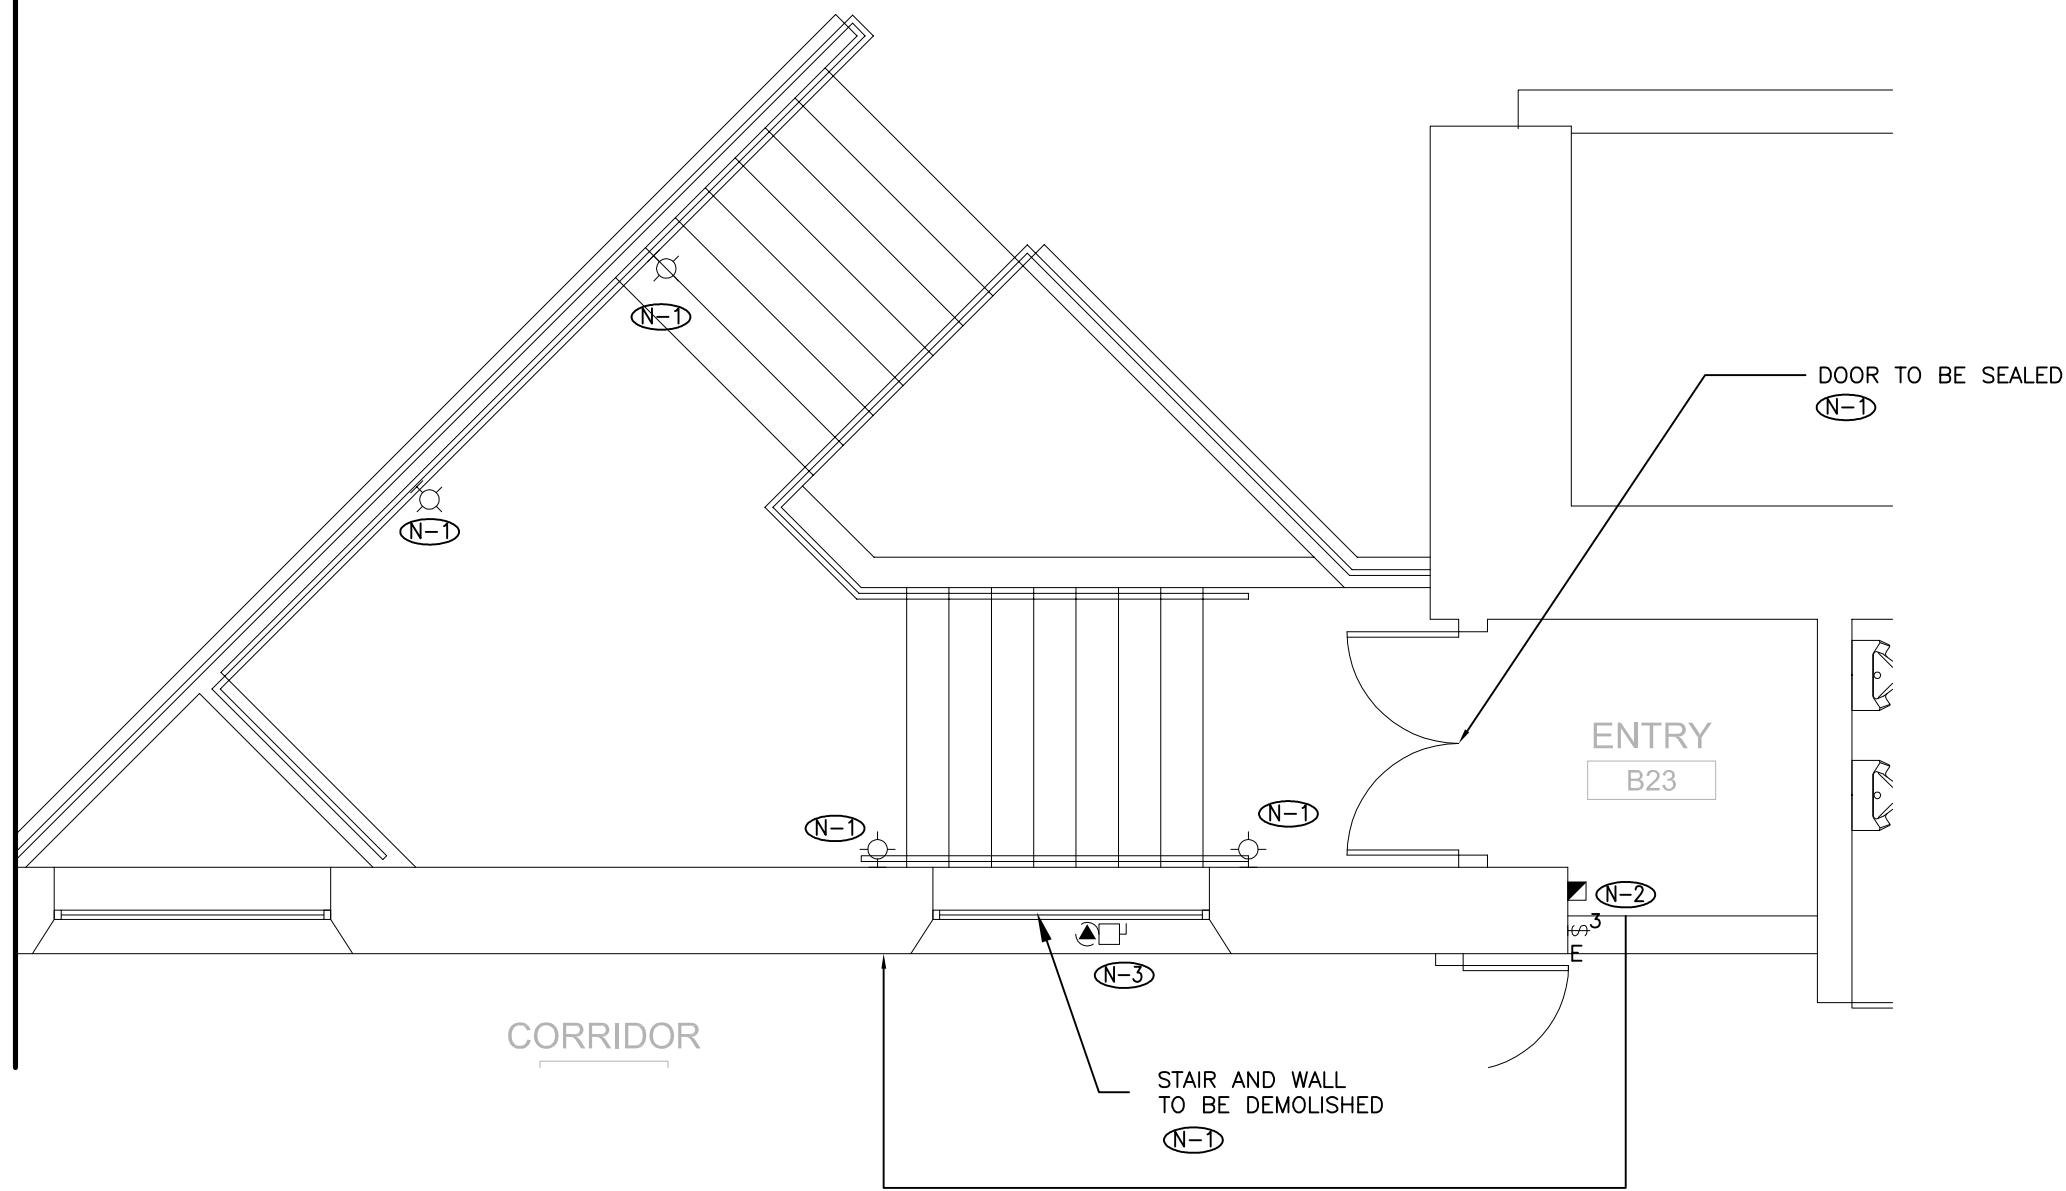

NOTES:

- (N-1) FOR AREAS IDENTIFIED TO BE DEMOLISHED, CONTRACTOR TO REMOVE CONDUIT, REMOVE WIRING BACK TO SOURCE AND MAKE SAFE. FOR ELECTRICAL AND SYSTEM SERVICES PASSING THROUGH THE AREA, CONTRACTOR SHALL INCLUDE FOR ALL REROUTING NECESSARY TO ACHIEVE NEW DESIGN AND MAINTAIN EXISTING SERVICES.
- (N-2) RELOCATE FIRE ALARM PULL STATION AND END OF LINE RESISTOR. PROVIDE NEW RECESSED OUTLET BOXES AT NEW LOCATION.
- (N-3) DISCONNECT AND REMOVE EXHAUST FAN IN WINDOW. RETURN TO OWNER AS SPARE. MAKE SAFE ELECTRICAL CONNECTIONS TO A JUNCTION BOX WITHIN ACCESSIBLE CEILING SPACE BY EXHAUST FAN.

2 BASEMENT - POWER, LIGHTING AND SYSTEMS DEMOLITION LAYOUT
E100 SCALE: 1:50

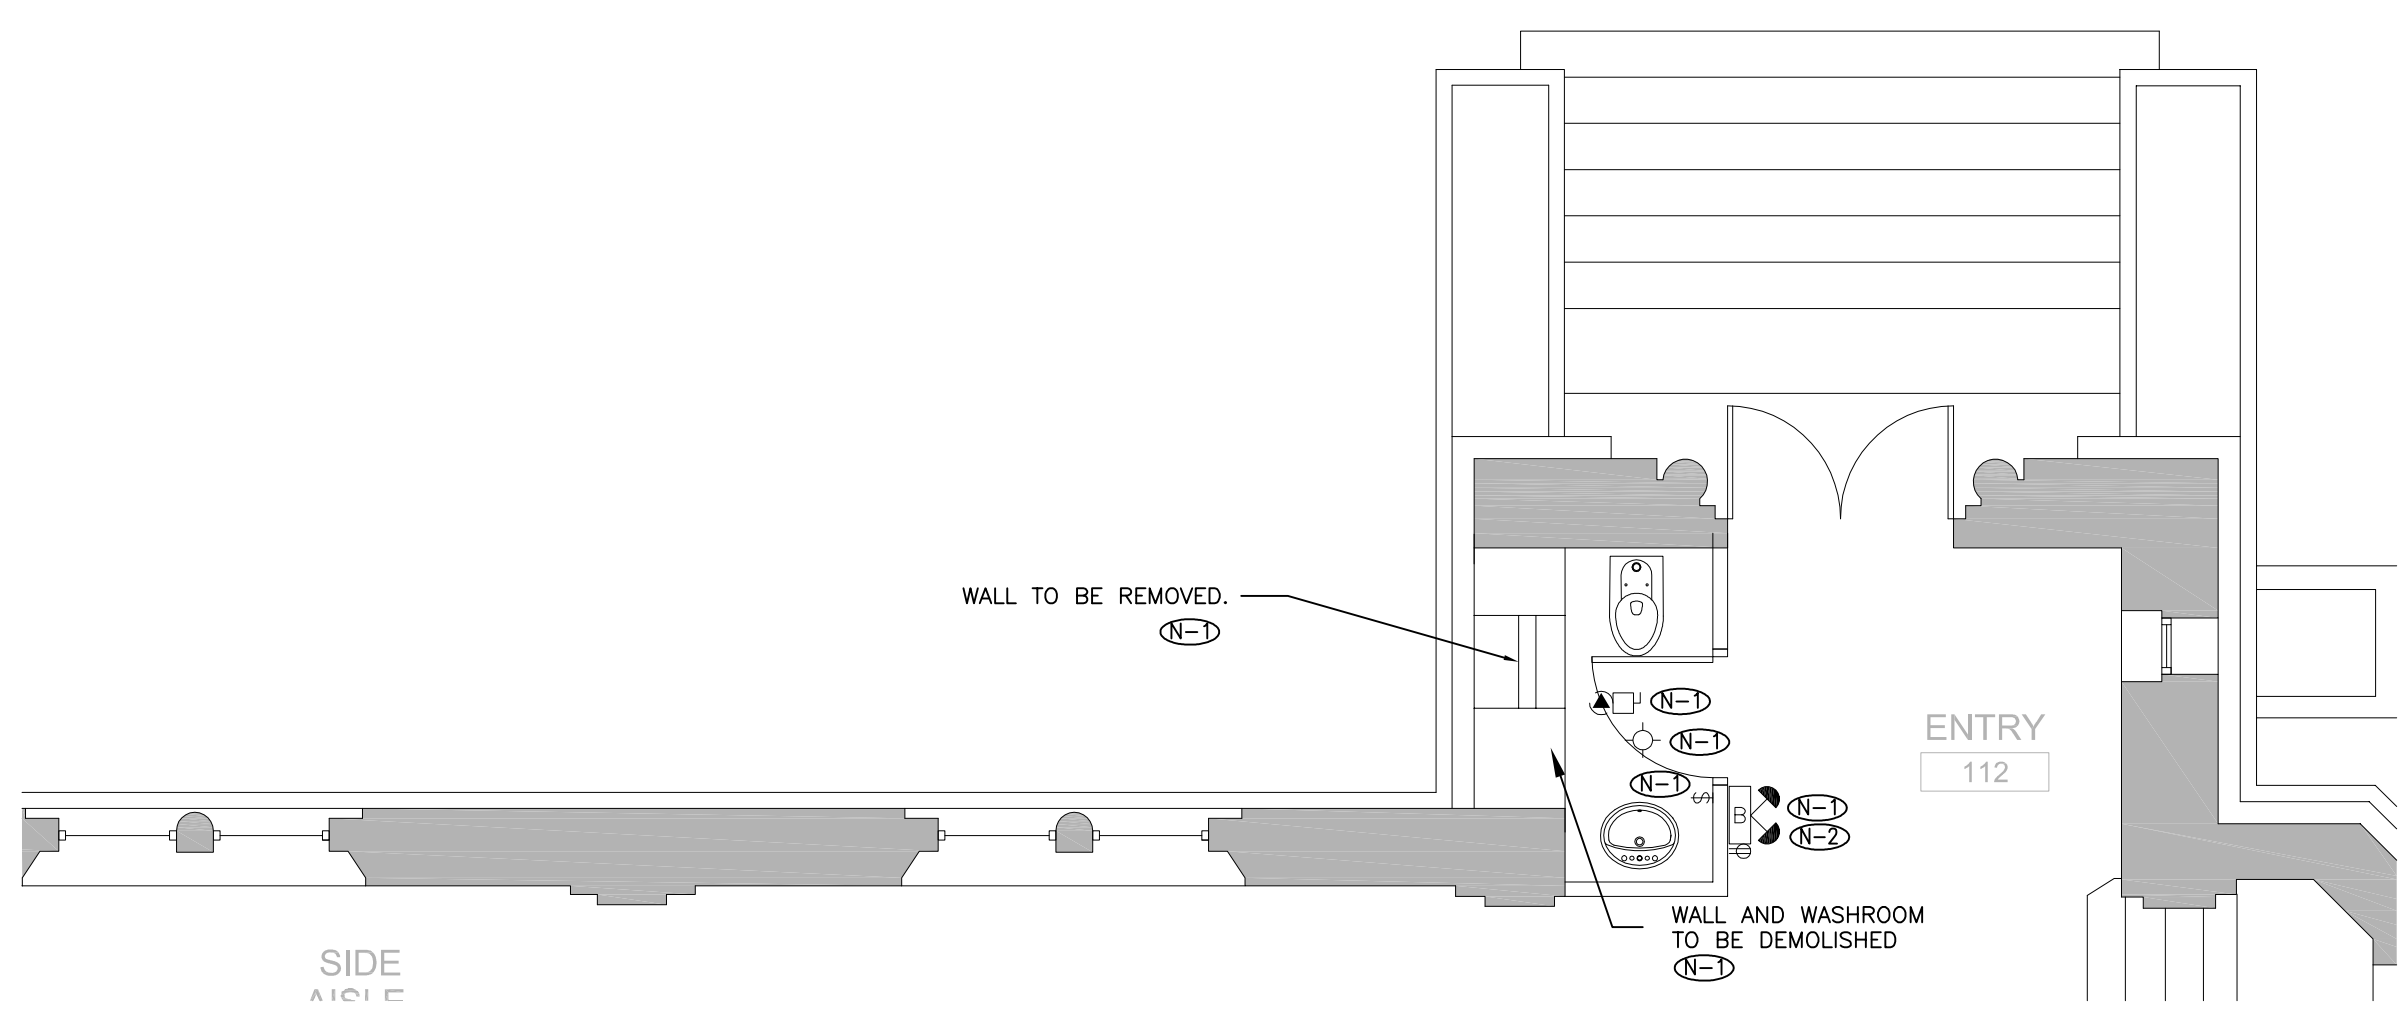

NOTES:

- (N-1) FOR AREAS IDENTIFIED TO BE DEMOLISHED, CONTRACTOR TO REMOVE CONDUIT, REMOVE WIRING BACK TO SOURCE AND MAKE SAFE. FOR ELECTRICAL AND SYSTEM SERVICES PASSING THROUGH THE AREA, CONTRACTOR SHALL INCLUDE FOR ALL REROUTING NECESSARY TO ACHIEVE NEW DESIGN AND MAINTAIN EXISTING SERVICES.
- (N-2) CIRCUIT FOR BATTERY UNIT RECEPTACLE TO BE RE-USED. CONTRACTOR TO TRACE, REMOVE AND ALLOW FOR ENTIRELY NEW WIRING TO NEW EXIT SIGN LOCATION SHOWN ON DRAWING E100 DETAIL 1.

1 GROUND FLOOR - POWER, LIGHTING AND SYSTEMS DEMOLITION LAYOUT
E100 SCALE: 1:50