



| NO. | ISSUE             | DATE     |
|-----|-------------------|----------|
| 00  | ISSUED FOR PERMIT | 10.01.28 |
| 01  | ISSUED FOR TENDER | 10.06.01 |

|  |  |  |  |  |  |  |
|--|--|--|--|--|--|--|
|  |  |  |  |  |  |  |
|  |  |  |  |  |  |  |
|  |  |  |  |  |  |  |
|  |  |  |  |  |  |  |
|  |  |  |  |  |  |  |

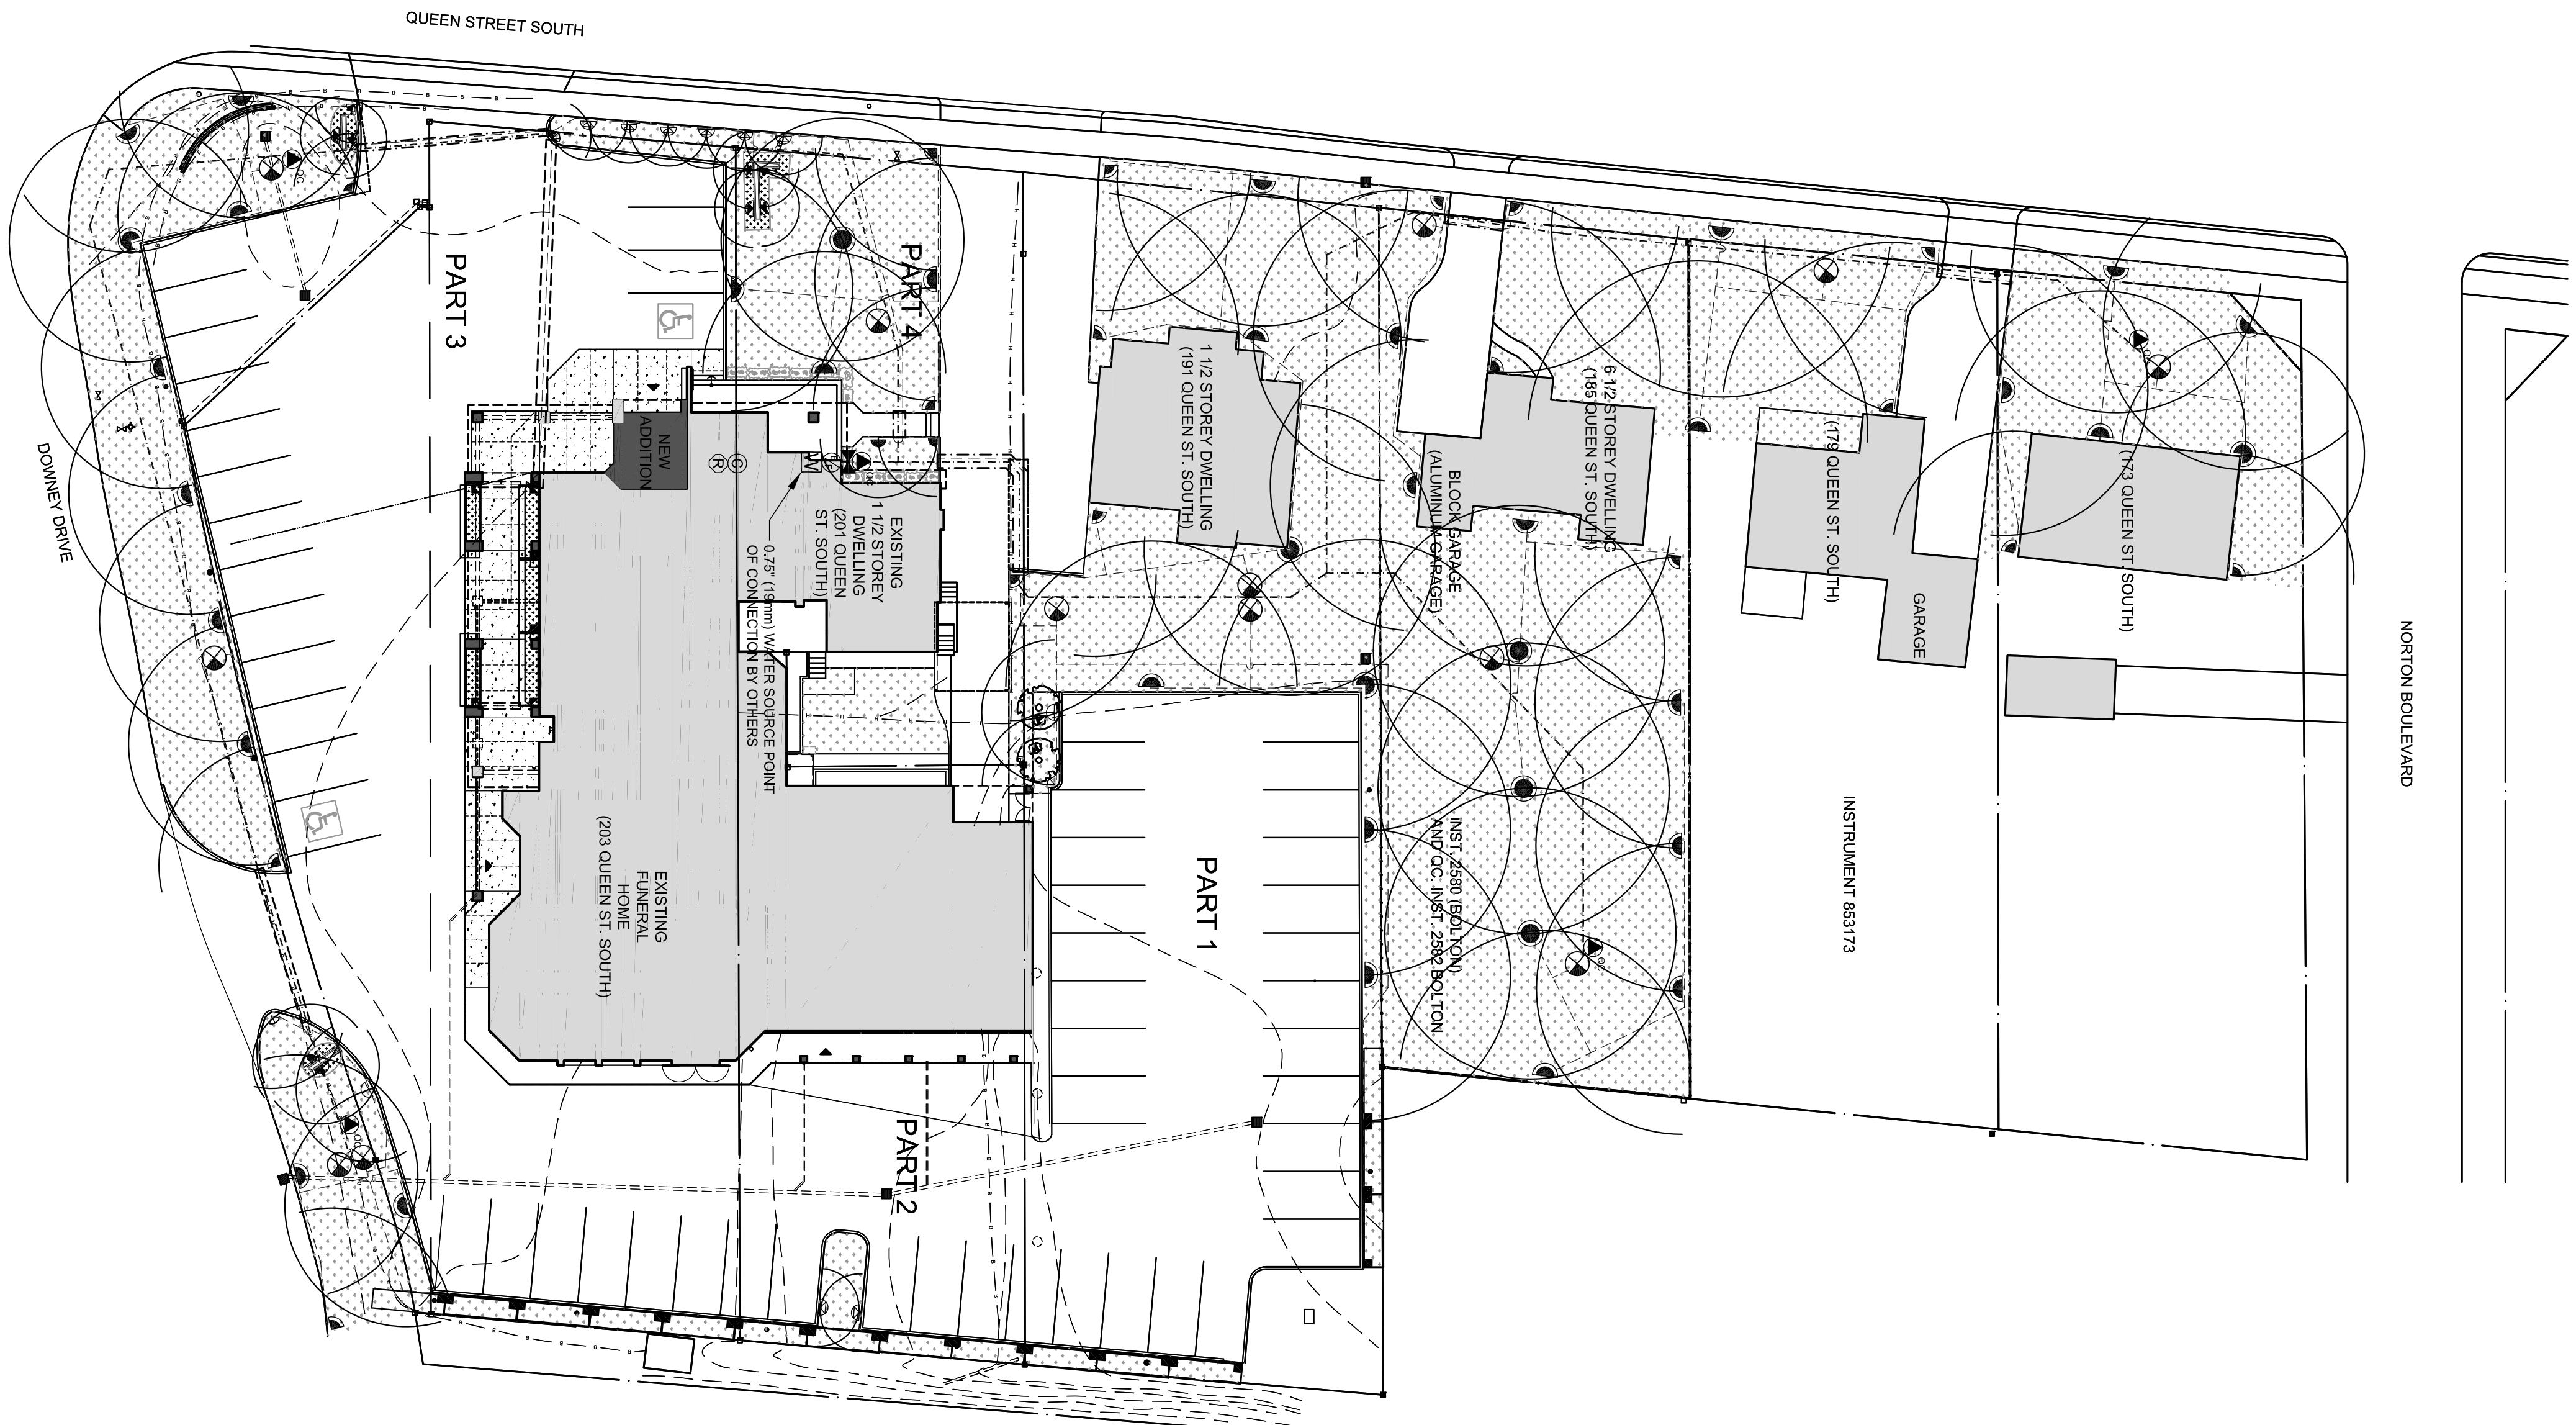


## IRRIGATION NOTES


1. SYSTEM DESIGN: 123pm@engr.
2. PIPES ARE DIAGRAMATIC ONLY.
3. ALL WORK SHALL BE CARRIED OUT IN ACCORDANCE WITH BY-LAWS AND CODES HAVING JURISDICTION OVER SITE LOCATION.
4. IT IS THE RESPONSIBILITY OF THE PLAN USER TO INFORM THEMSELVES OF THE EXIST LOCATION OF ALL POLES, LINES, CONDUIT, WATER MAINS, SEWERS AND OTHER UNDERGROUND AND OVERHEAD UTILITIES AND STRUCTURES BEFORE COMMENCING WORK.
5. LOCATION OF THE SPRINKLERS AND PIPES ARE APPROXIMATE. VALVES MAY BE LOCATED INAPPROPRIATELY ON THE PLAN DUE TO SPACE LIMITATIONS ON DRAWING.
6. ACTUAL LOCATION OF SPRINKLERS TO BE DETERMINED AT TIME OF CONSTRUCTION.
7. ALL SPRAY HEADS TO BE PRESSURE COMPENSATED.
8. ALL SPRINKLERS LOCATED IN FLOWER BEDS TO BE HIP-OP SPRINKLERS.
9. IT IS THE RESPONSIBILITY OF PLAN USER TO INFORM THEMSELVES OF THE EXIST MATERIAL QUANTITIES REQUIRED.
10. THE IRRIGATION PLAN IS BASED UPON AND IS TO BE READ IN CONJUNCTION WITH THE LANDSCAPE PLANSITE PLAN, AND THEREFORE MAY BE SUBJECT TO RELATED CHANGES, IRRESPECTIVE OF THE IRRIGATION DESIGN INTENSIONS.
11. THE PLAN USER IS TO FAMILIARIZE THEMSELVES WITH ALL RELATED SPECIFICATIONS.
12. MECHANICAL CONTRACTOR IS TO PROVIDE A 0.75" WATER SOURCE POINT OF CONNECTION (POC) AT THE LOCATION SHOWN ON THE PLAN OUTSIDE OF THE BUILDING, INCLUDING SUPPLY AND INSTALLATION OF A 0.75" SHUT-OFF VALVE, 0.75" BACKFLOW PREVENTER AND 1" BRAIN VALVE AT THE POINT OF CONNECTION TO THE MAIN WATER SUPPLY IN THE MECHANICAL ROOM, AS PER LOCAL PLUMBING CODE.
13. ELECTRICAL CONTRACTOR IS TO PROVIDE A 110 VOLT POWER SUPPLY TO THE IRRIGATION CONTROLLER AND 1" ELECTRICAL CONDUIT FROM THE CONTROLLER TO THE WATER SUPPLY POINT OF CONNECTION OUTSIDE OF THE BUILDING.

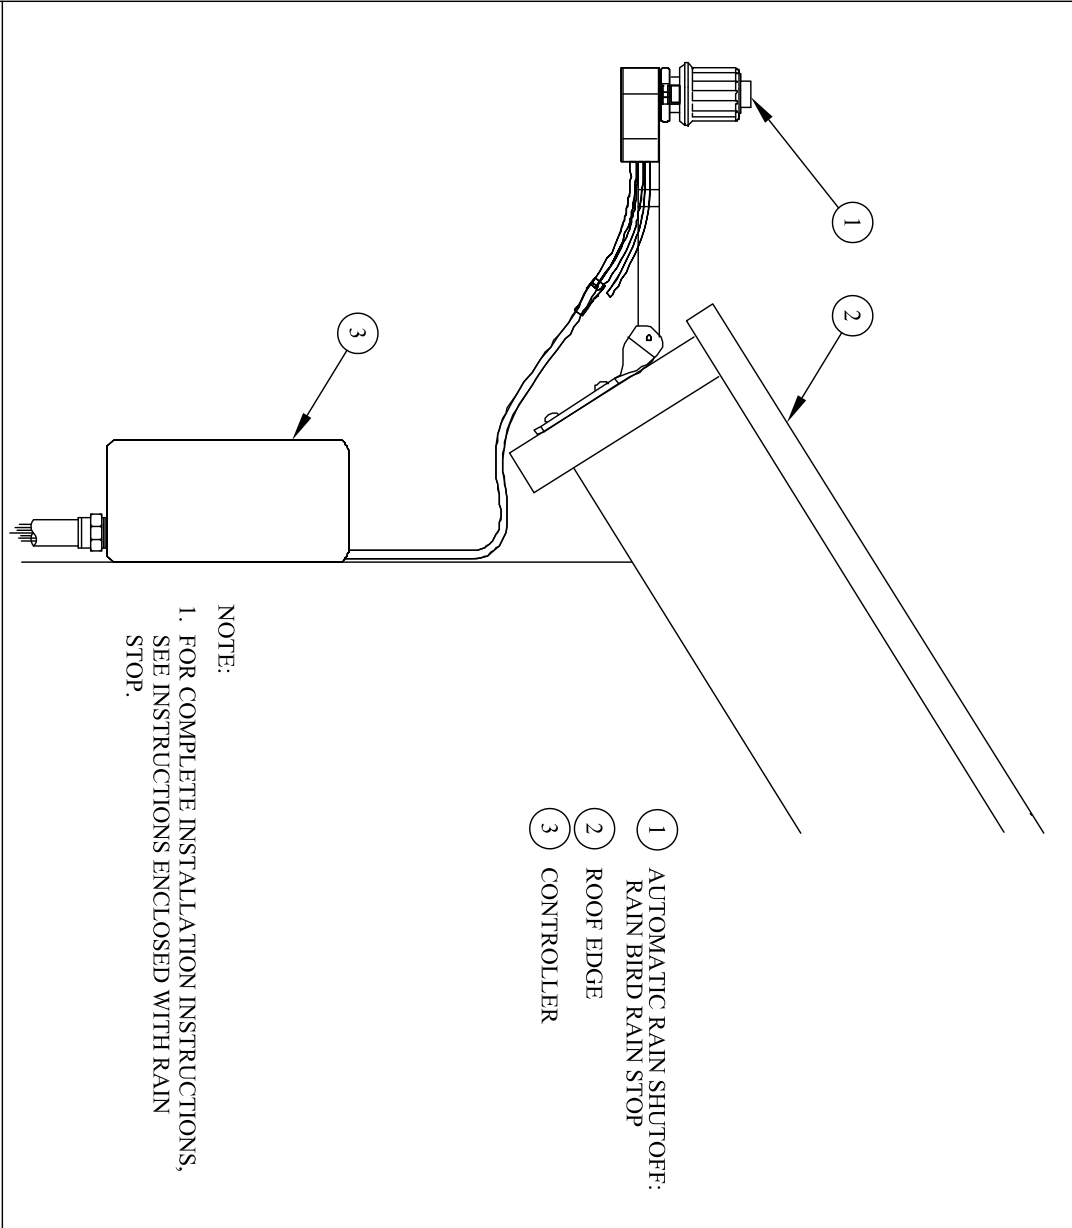


## AUTOMATIC RAIN SHUTOFF

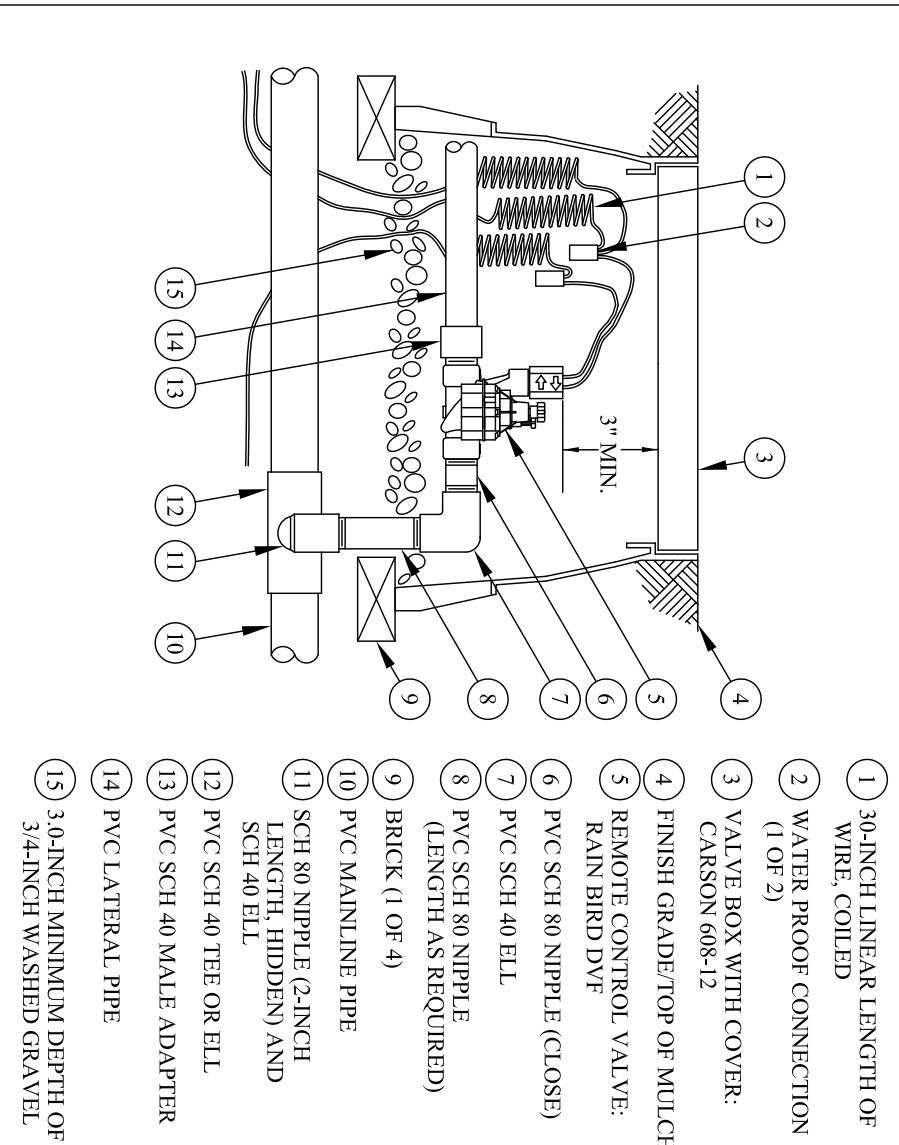


## DVF VALVE

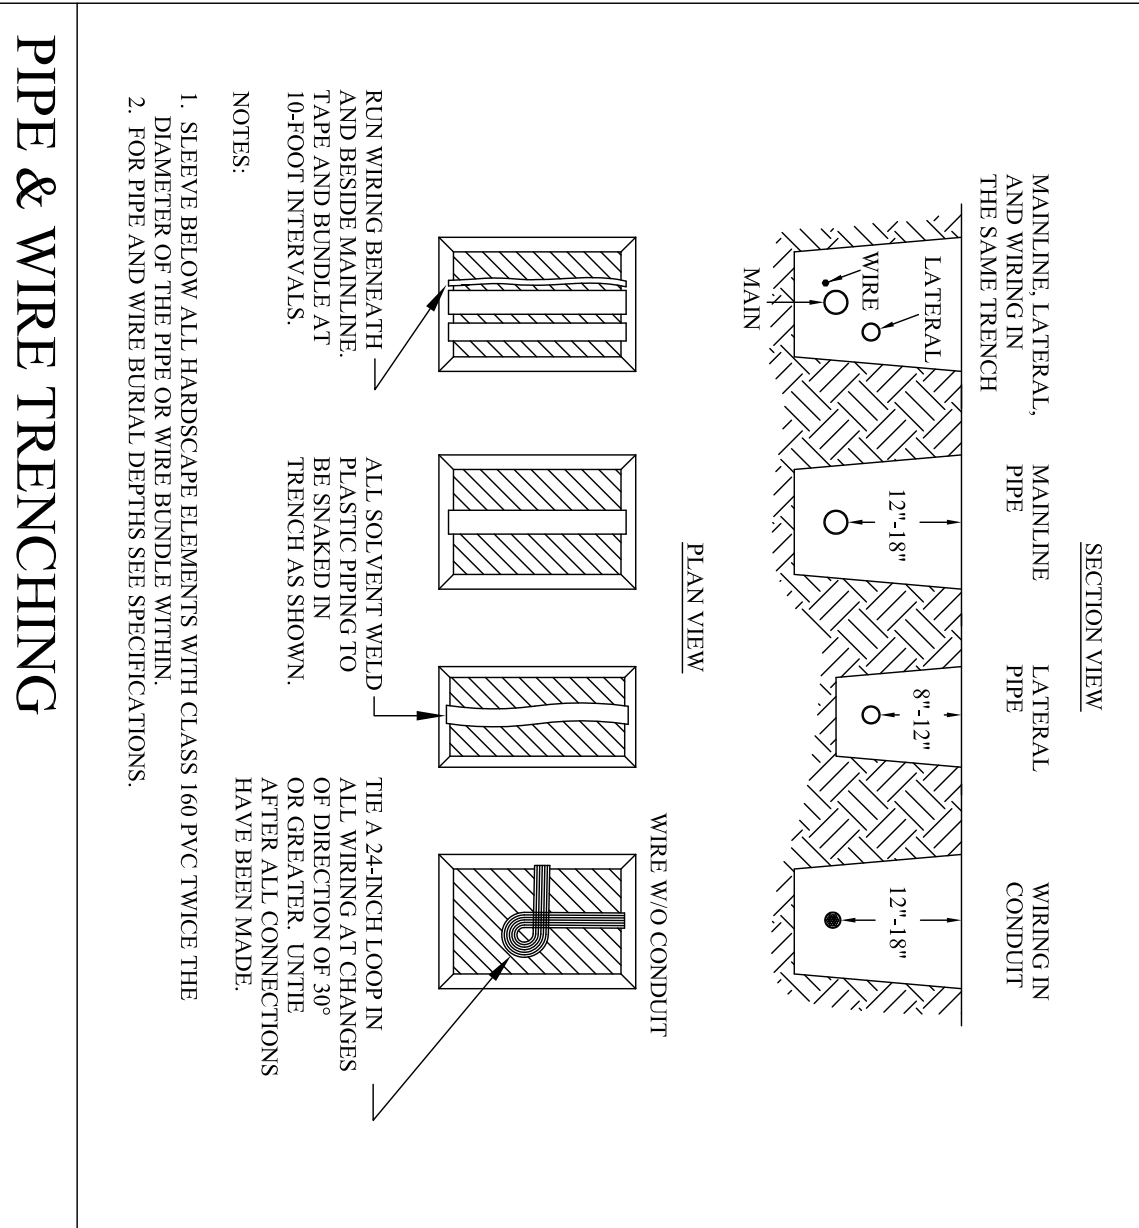


## PIPE & WIRE TRENCHING

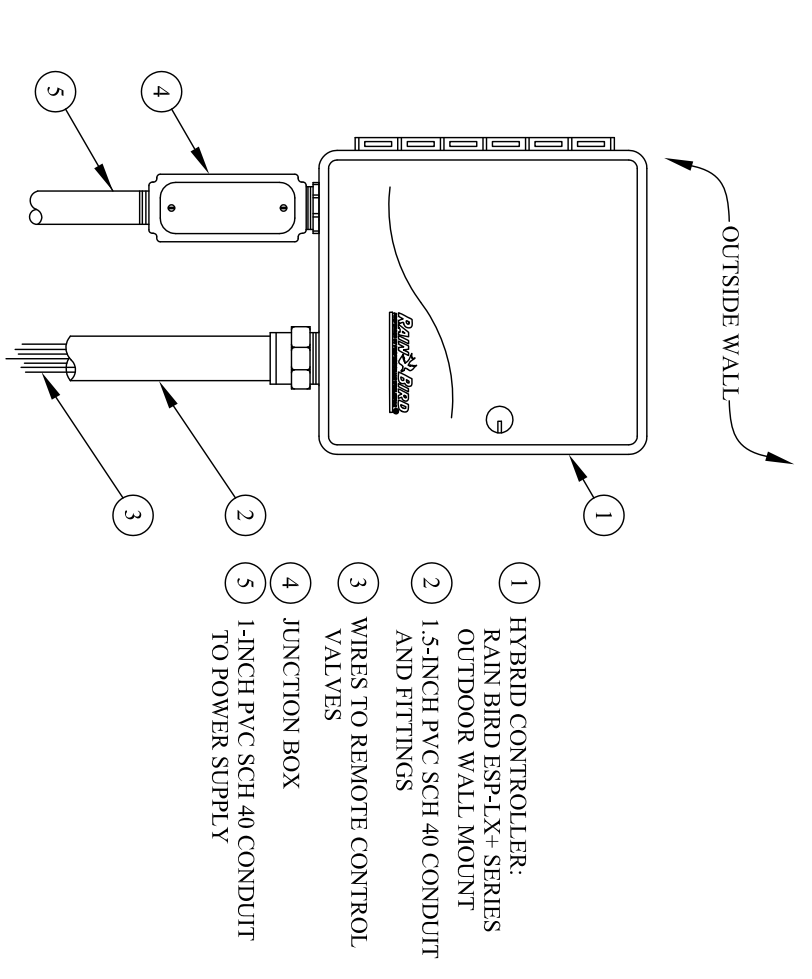


## WALL MOUNT CONTROLLER

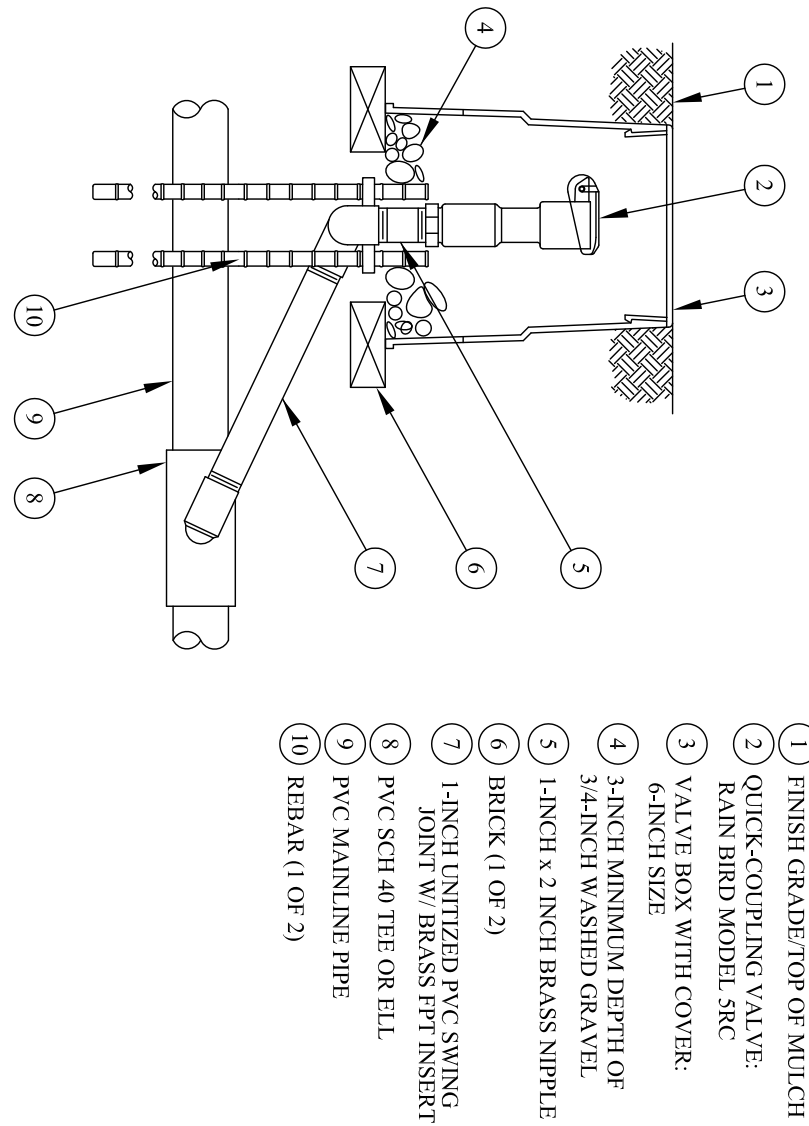


## QUICK-COUPPLING VALVE

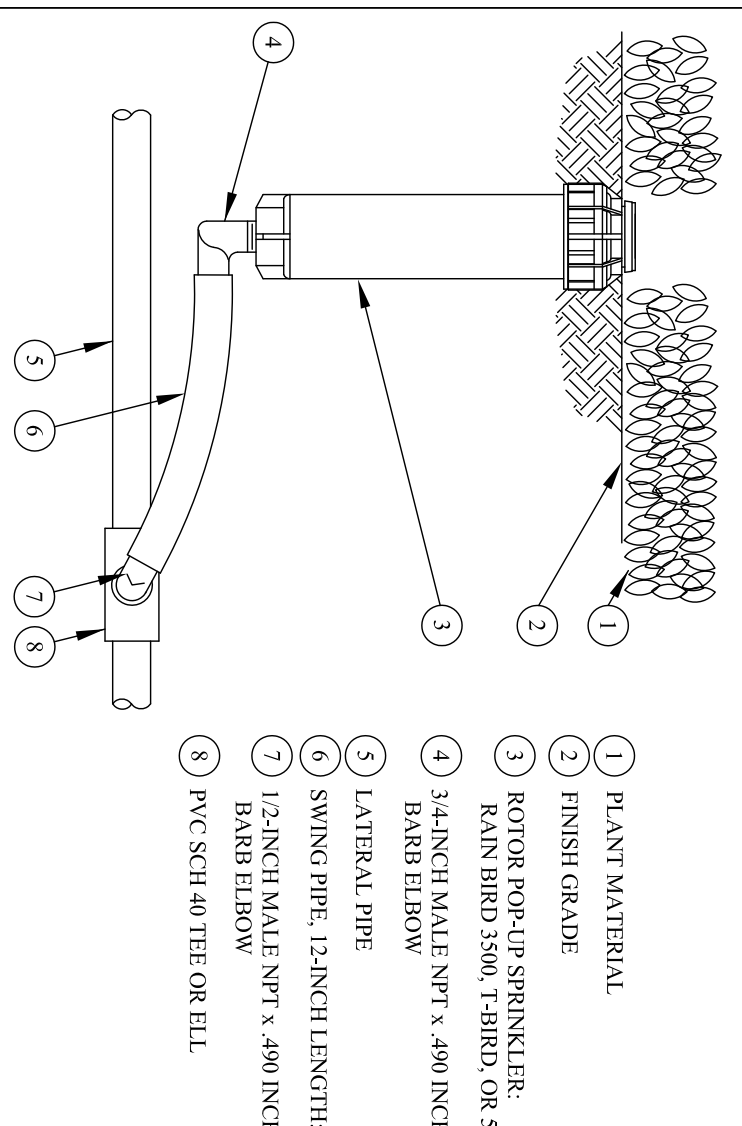


## SMALL TURF ROTOR

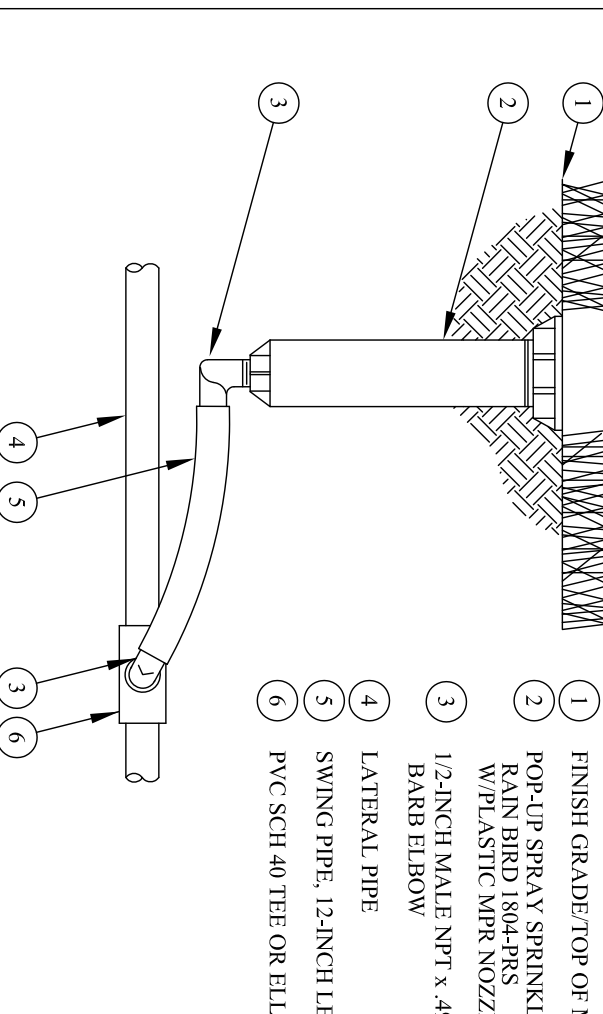

## TURF POP-UP SPRAY

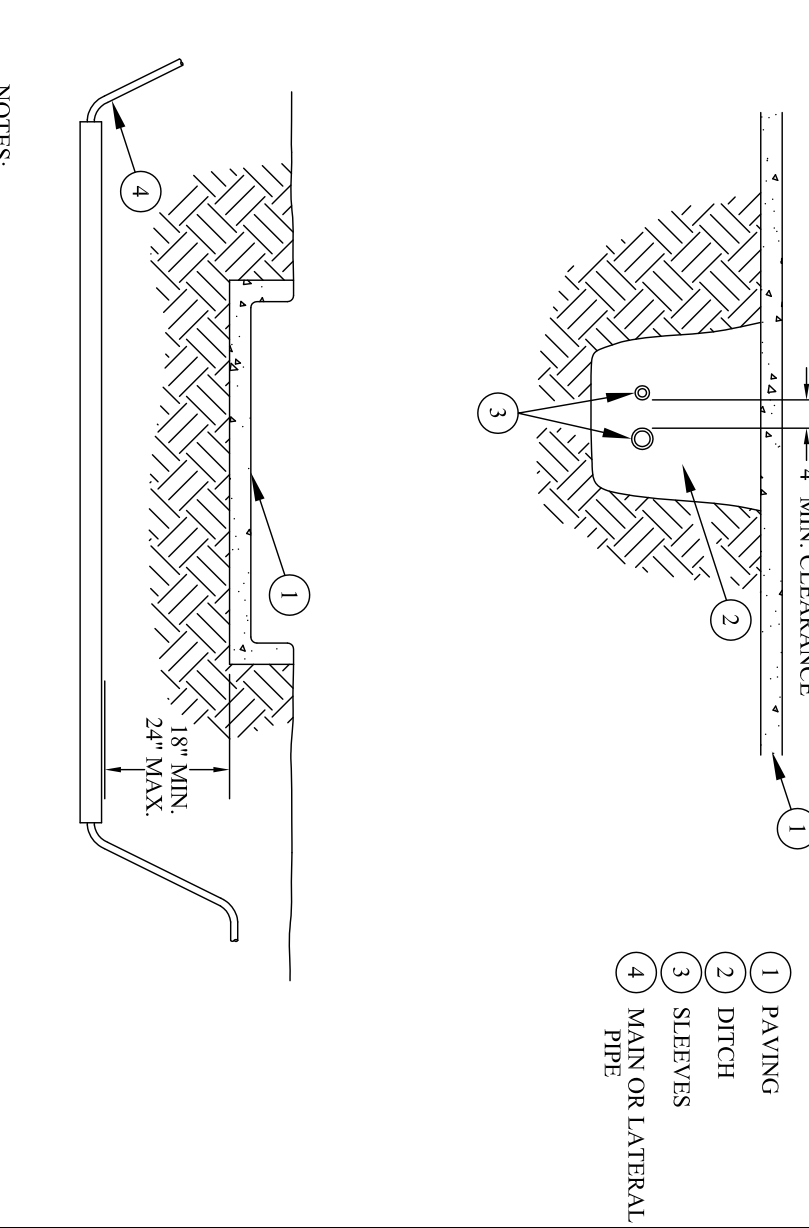

## SLEEVING

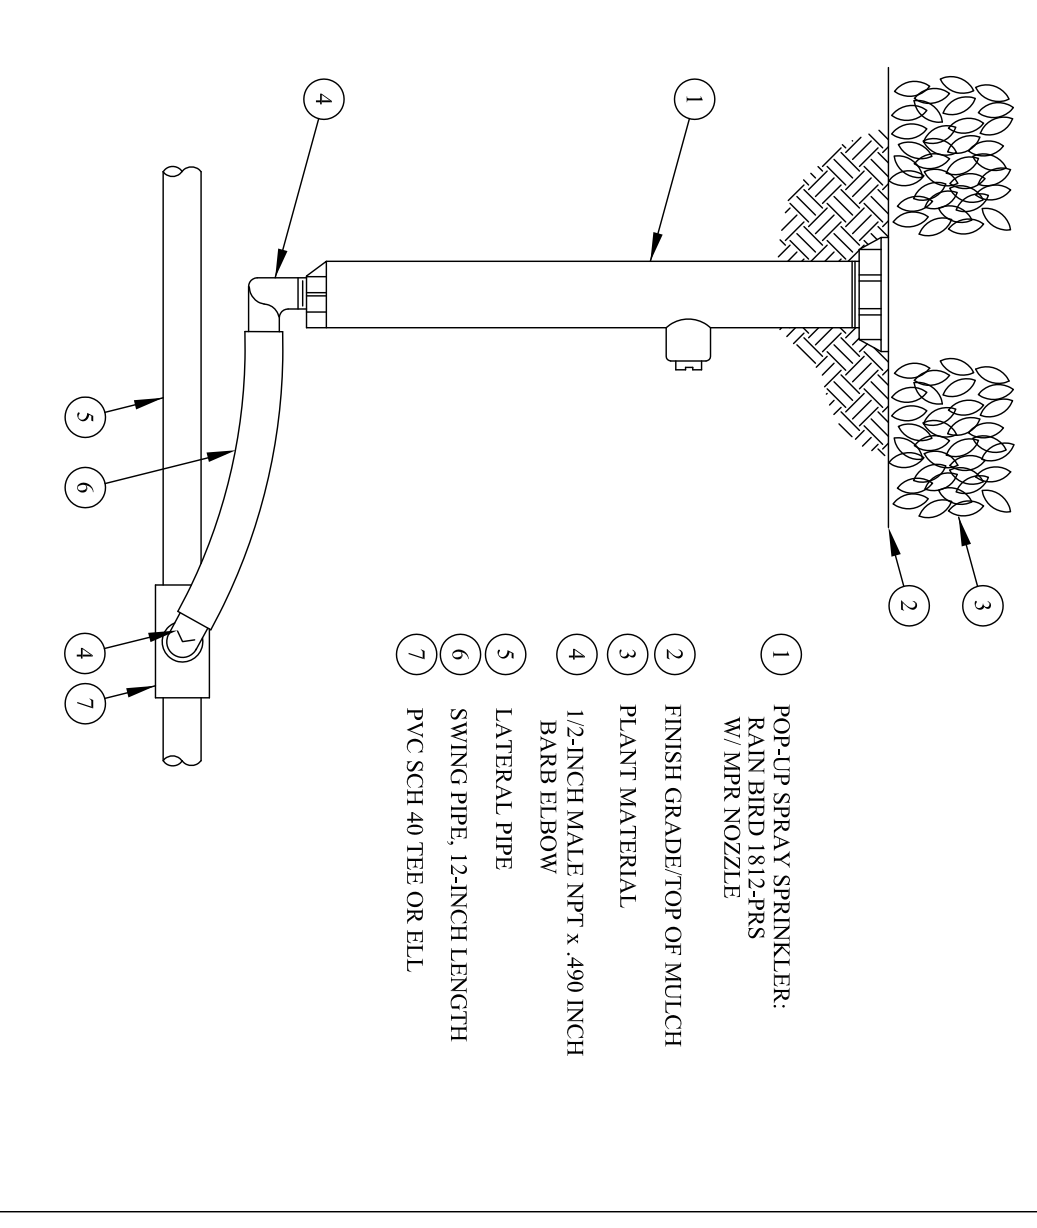

## HIGH-POP SPRAY

## IRRIGATION PLAN & DETAILS

|                |                 |
|----------------|-----------------|
| PROJECT NUMBER | 0660            |
| SCALE          | 1" = 25'-0"     |
| DATE           | 28 JANUARY 2010 |
| DRAWN          | CIS             |
| CHECKED        | D.F.S.          |
| SET NO.        | DRAWING NO.     |