

ALL DIMENSIONS TO BE CHECKED AND VERIFIED ON THE JOB.
ANY AND ALL DISCREPANCIES TO BE REPORTED TO THE ARCHITECT.

ALL DRAWINGS REMAIN THE PROPERTY OF THE ARCHITECT.
DO NOT SCALE DRAWINGS.

No.	Issue	Date
00	ISSUED FOR PERMIT	10.01.28
01	ISSUED FOR TENDER	10.06.01
02	RE-ISSUED FOR TENDER	11.04.08



ADDITION & ALTERATIONS -
EGAN FUNERAL HOME

203 Queen St. S., Bolton, ON

Ground Floor Plan New
Lighting Layout


PROJECT NUMBER	CE-1157
SCALE	1/4" = 1'-0"
DATE	FEB 09, 2009
DRAWN	DJR
CHECKED	MJV
SET NO.	DRAWING NO.

E200

LIGHTING FIXTURE SCHEDULE							
SYMBOL	DESCRIPTION	VOLTAGE	LAMPS	MOUNTING	SYMBOL	DESCRIPTION	VOLTAGE
A	ARCHITECTURAL SURFACE DECORATIVE 22" DIAMETER FIXTURE WITH POLISHED BRASS RINGS WITH ELECTRONIC DIMMABLE BALLAST CANLYTE - LIGHTOLIER SPILL RING SERIES LIGHTOLIER SPECDECG #854-SPB326U	120	2 - 28W QT 2700K	SURFACE MOUNTED ON CEILINGS	H	SPECIFICATION GRADE RECESSED FLUORESCENT TROFFER WITH 0.125" ACYLIC LENS, TWO BALLASTS ON TO SWITCH 2 LAMPS AND ONE FOR 3RD LAMP; LITHONIA SP SERIES OR APPROVED EQUAL SPFS-F--32BT42 GS-MOULT-1/3-EEB1OPS-CSA	120
B	SINGLE CANDELABRA DECORATIVE WALL SCONCE SEAQUILL LIGHTING 4178-02 SINGLE LIGHT TRADITIONAL WALL SCONCE 4.5"W x 13.25"H x 9"D OR 4167-02 SINGLE LIGHT TRADITIONAL WALL SCONCE 4.5"W x 10"H x 7.75"D	120	ONE (1) CANDELABRA TORREDO 60W MAX	SURFACE WALL	I	JAM JAR VAPOR TIGHT STYLE CAST ALUMINUM FIXTURE IN ELEVATOR PIT WITH WIRE GUARD LITHONIA LIGHTING VM SERIES OR APPROVED EQUAL VM150L M12WC	120
C	DOUBLE CANDELABRA DECORATIVE WALL SCONCE SEAQUILL LIGHTING 4179-02 TWO LIGHT TRADITIONAL WALL SCONCE 13.25"W x 13.25"W x 5.75"D	120	TWO (2) CANDELABRA TORREDO 60W MAX	SURFACE WALL	J	GLASS LENSED PENDANT FIXTURE (MR-16) TO BE COMPLETE WITH TRACK AND ALL ACCESSORIES FOR COMPLETE INSTALLATION. PROVIDE \$800 CASH ALLOWANCE FOR TWO(2) FIXTURES. MP LIGHTING P202C SERIES OR APPROVED EQUAL. MP LIGHTING P202C-FROM-MC	120
D	SQUARE RECESSED FIXTURES DALI-MX-4 MATRIX SERIES OR EUREKA 1254D-2X2 OR LITHONIA R105-1/42TRI-MOULT	120	FOUR (4) MR16 OR ONE(1) 42W TRI 2700K	RECESSED	K	EYEBALL TYPE POT LIGHT WITH 350 DEGREE ROTATION AND 70 DEGREE ANGLE ADJUSTMENT, SATIN CHROME FINISH. EUREKA 10305C OR APPROVED EQUAL	120V
E1	T5 FLUORESCENT STRIP FIXTURE CANLYTE SV128UNVPG WITH SV5GXG3 WIREGUARD WHERE NOTED ON PLANS	120	ONE (1) T5-28W 3000K	SURFACE	L	DOWNLIGHT POT LIGHT WITH 9 1/2" OPEN APERTURE WITH SPECULAR CLEAR ALZAK REFLECTOR AND LENS. CANLYTE - CALCULITE DL9AQL5C5LW OR APPROVED EQUAL	120V
E2	T5 FLUORESCENT STRIP FIXTURE CANLYTE SV228UNVPG WITH SV5GXG3 WIREGUARD WHERE NOTED ON PLANS	120	TWO (2) T5-28W 3000K	SURFACE			
E3	T5 FLUORESCENT STRIP FIXTURE CANLYTE SV128UNVPG WITH SV5R1W4ASLD ASYMMETRIC REFLECTOR	120	ONE (1) T5-28W 2700K	SURFACE			
F	INCANDESCENT THEATRICAL TRACK LIGHT FIXTURE MOUNTED ON SINGLE CIRCUIT TRACK CANLYTE-LITESPAN E259W1 WITH A44 DIFFUSOR AND A44 COLOURED FILTER. CONFIRM DIFFUSOR AND FILTER TYPE WITH OWNER.	120	ONE (1) 150W PAR-38	TRACK MOUNTED			
G	ARCHITECTURAL CHANDELIER FIXTURE OR CEILING MOUNTED TYPE FIXTURE TO BE CONFIRMED BY OWNER	120	THREE (3) 100W A-19	CEILING MOUNTED			
G1	ARCHITECTURAL CEILING MOUNTED FIXTURE TYPE TO BE CONFIRMED BY OWNER	120	ONE (1) 100W A-19	CEILING MOUNTED			

NOTES:
1. RE-USE EXISTING LIGHTING AND POWER CIRCUITS TO FEED NEW DEVICES IN THESE AREAS UNLESS NOTED OTHERWISE.
2. LIGHTING AND POWER SYSTEMS BEYOND THE DELINEATED AREA TO REMAIN FUNCTIONAL DURING CONSTRUCTION. PROVIDE POWER FROM EXISTING PANEL TO REFEED CIRCUITS AFFECTED BY DEMOLITION OF UPPER FLOOR ABOVE. SEE PANEL SCHEDULES ON DRAWING E302.
3. GENERALLY, NEW DEVICES AND SYSTEMS ONLY ARE SHOWN BEYOND THE DELINEATED AREA. EXISTING TO REMAIN UNLESS NOTED OTHERWISE.
4. EMERGENCY LIGHTS TO BE CONNECTED TO UNSWITCHED LOCAL LIGHTING CIRCUITS.
5. REFER TO SITE LIGHTING PLAN E100 FOR ADDITIONAL BUILDING MOUNTED OUTDOOR LIGHT FIXTURES AND POLE MOUNTED PARKING LOT FIXTURES.

EXIT SIGN/EMERGENCY BATTERY SCHEDULE						
UNIT	MANUFACTURER	MODEL No.	WATTAGE	VOLTAGE	# OF HEADS	TIME
EB1	BEGHELLI	QUADRA EXIT COMBO	36	12	2 + 0	30 MINS
EB2	BEGHELLI	QUADRA EXIT COMBO	72	12	2 + 4	30 MINS
EB3	BEGHELLI	QUADRA EXIT	-	12	0 + 0	30 MINS
EB4	BEGHELLI	NOVA	72	12	2 + 4	30 MINS
-	-	-	-	-	-	-

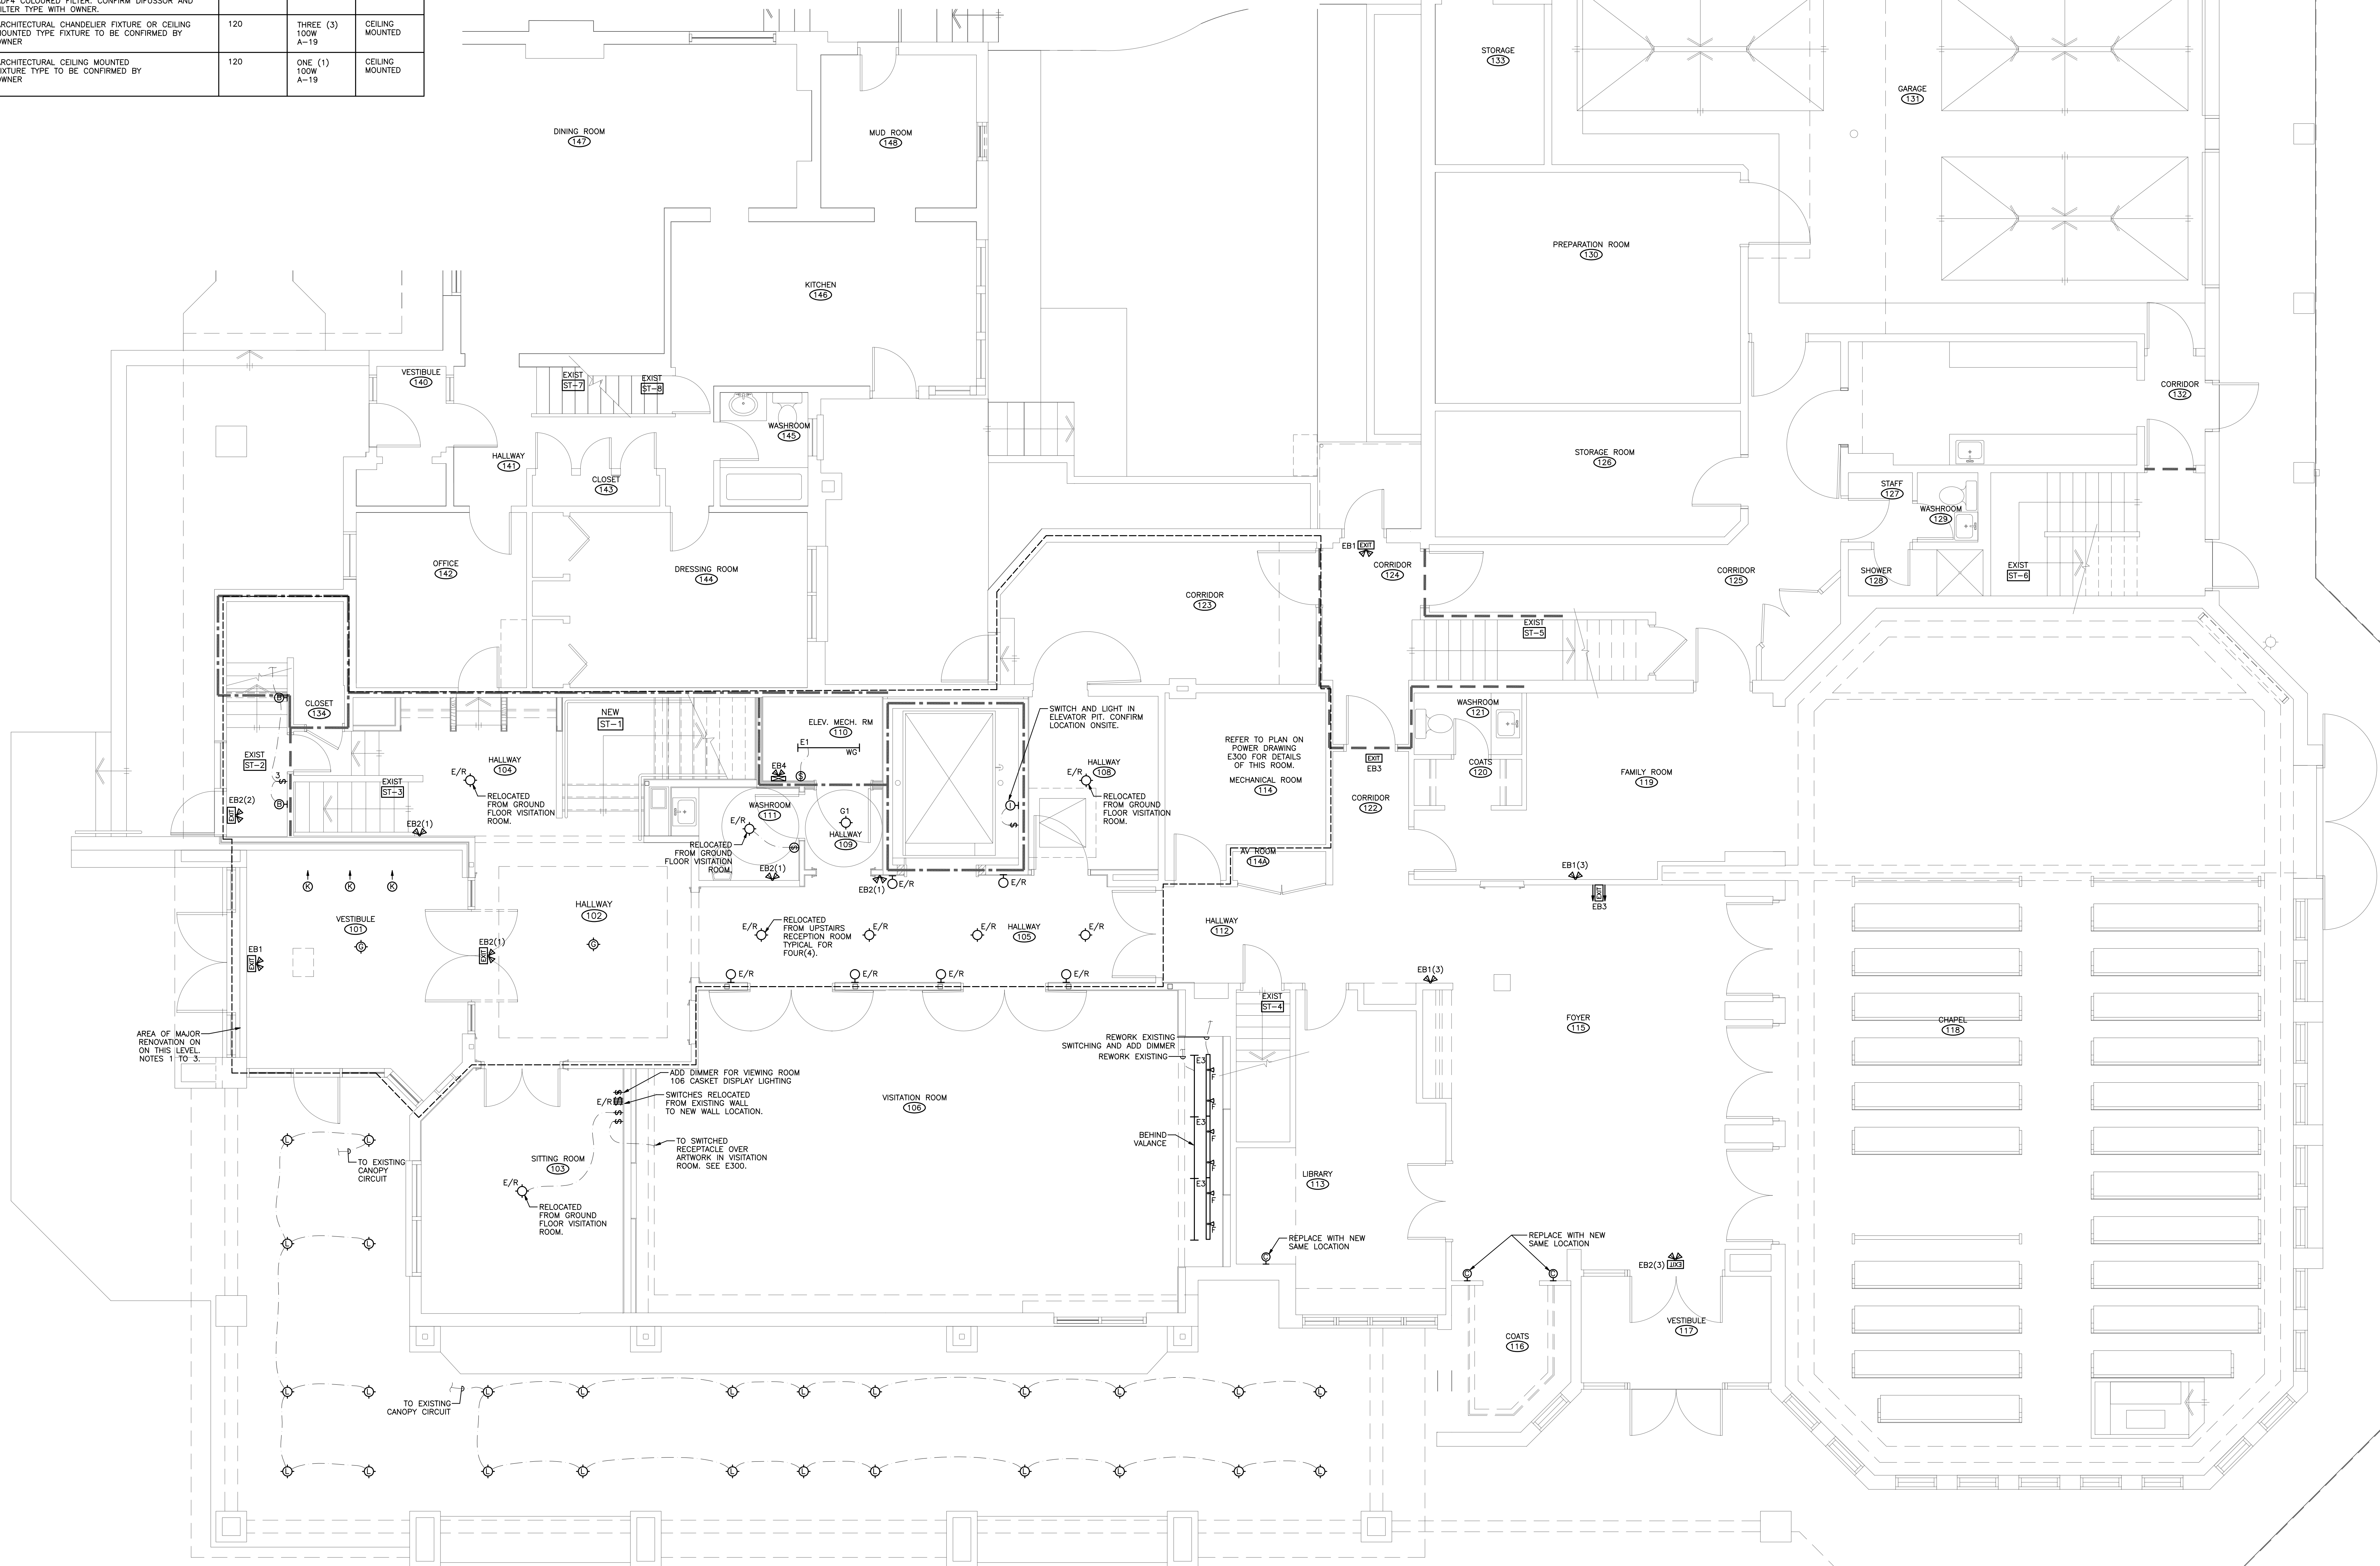

GROUND FLOOR PLAN
SCALE: 1/4" = 1'-0"