


ALL DIMENSIONS TO BE CHECKED AND VERIFIED ON THE JOB.
ANY AND ALL DISCREPANCIES TO BE REPORTED TO THE ARCHITECT.

ALL DRAWINGS REMAIN THE PROPERTY OF THE ARCHITECT.
DO NOT SCALE DRAWINGS.

No.	Issue	Date
00	ISSUED FOR PERMIT	10.01.28
01	ISSUED FOR TENDER	10.06.01
02	RE-ISSUED FOR TENDER	11.04.08

Callidus Engineering
A Division of 1640286 Ontario Inc.
1385 North Routledge Park, Unit 9 - London, ON N6H 5N5
P: 519-472-7640 F: 519-471-9239 E: info@callidus.ca

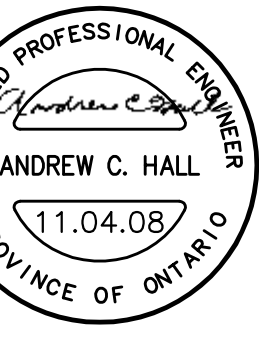


ADDITION & ALTERATIONS -
EGAN FUNERAL HOME

203 Queen St. S., Bolton, ON


Ground Floor Plan
Power and Systems

PROJECT NUMBER	CE-1157
SCALE	1/4" = 1'-0"
DATE	FEB 09, 2009
DRAWN	DJR
CHECKED	MJV
SET NO.	DRAWING NO.

E300

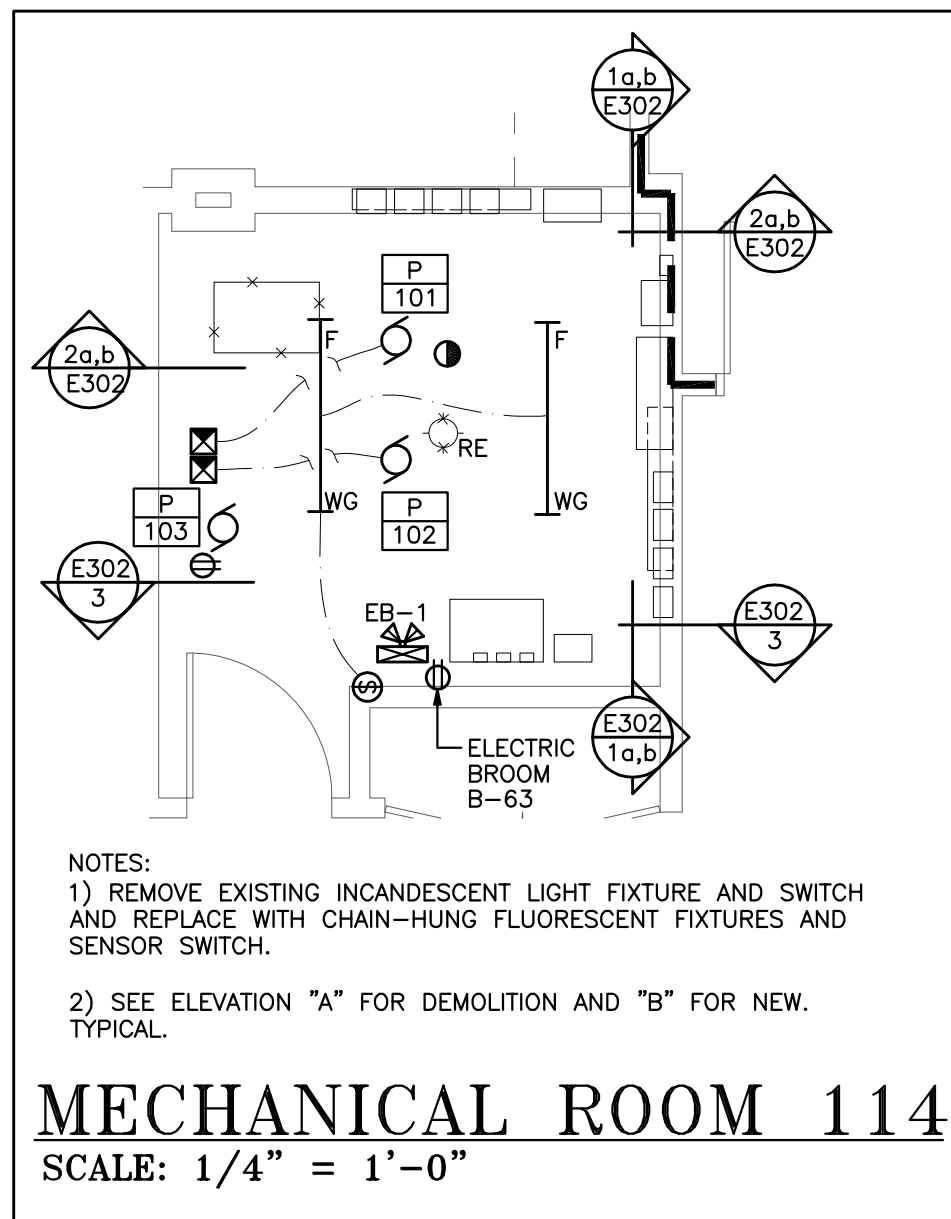

NOTES:
1. RE-USE EXISTING LIGHTING AND POWER CIRCUITS TO FEED NEW DEVICES IN THESE AREAS UNLESS NOTED OTHERWISE.
2. LIGHTING AND POWER SYSTEMS BEYOND THE DELINEATED AREA TO REMAIN FUNCTIONAL DURING CONSTRUCTION. PROVIDE POWER FROM EXISTING PANEL TO REFEED CIRCUITS AFFECTED BY DEMOLITION OF UPPER FLOOR ABOVE. SEE PANEL SCHEDULES ON DRAWING E302.
3. GENERALLY, NEW DEVICES AND SYSTEMS ONLY ARE SHOWN BEYOND THE DELINEATED AREA. EXISTING TO REMAIN UNLESS NOTED OTHERWISE.

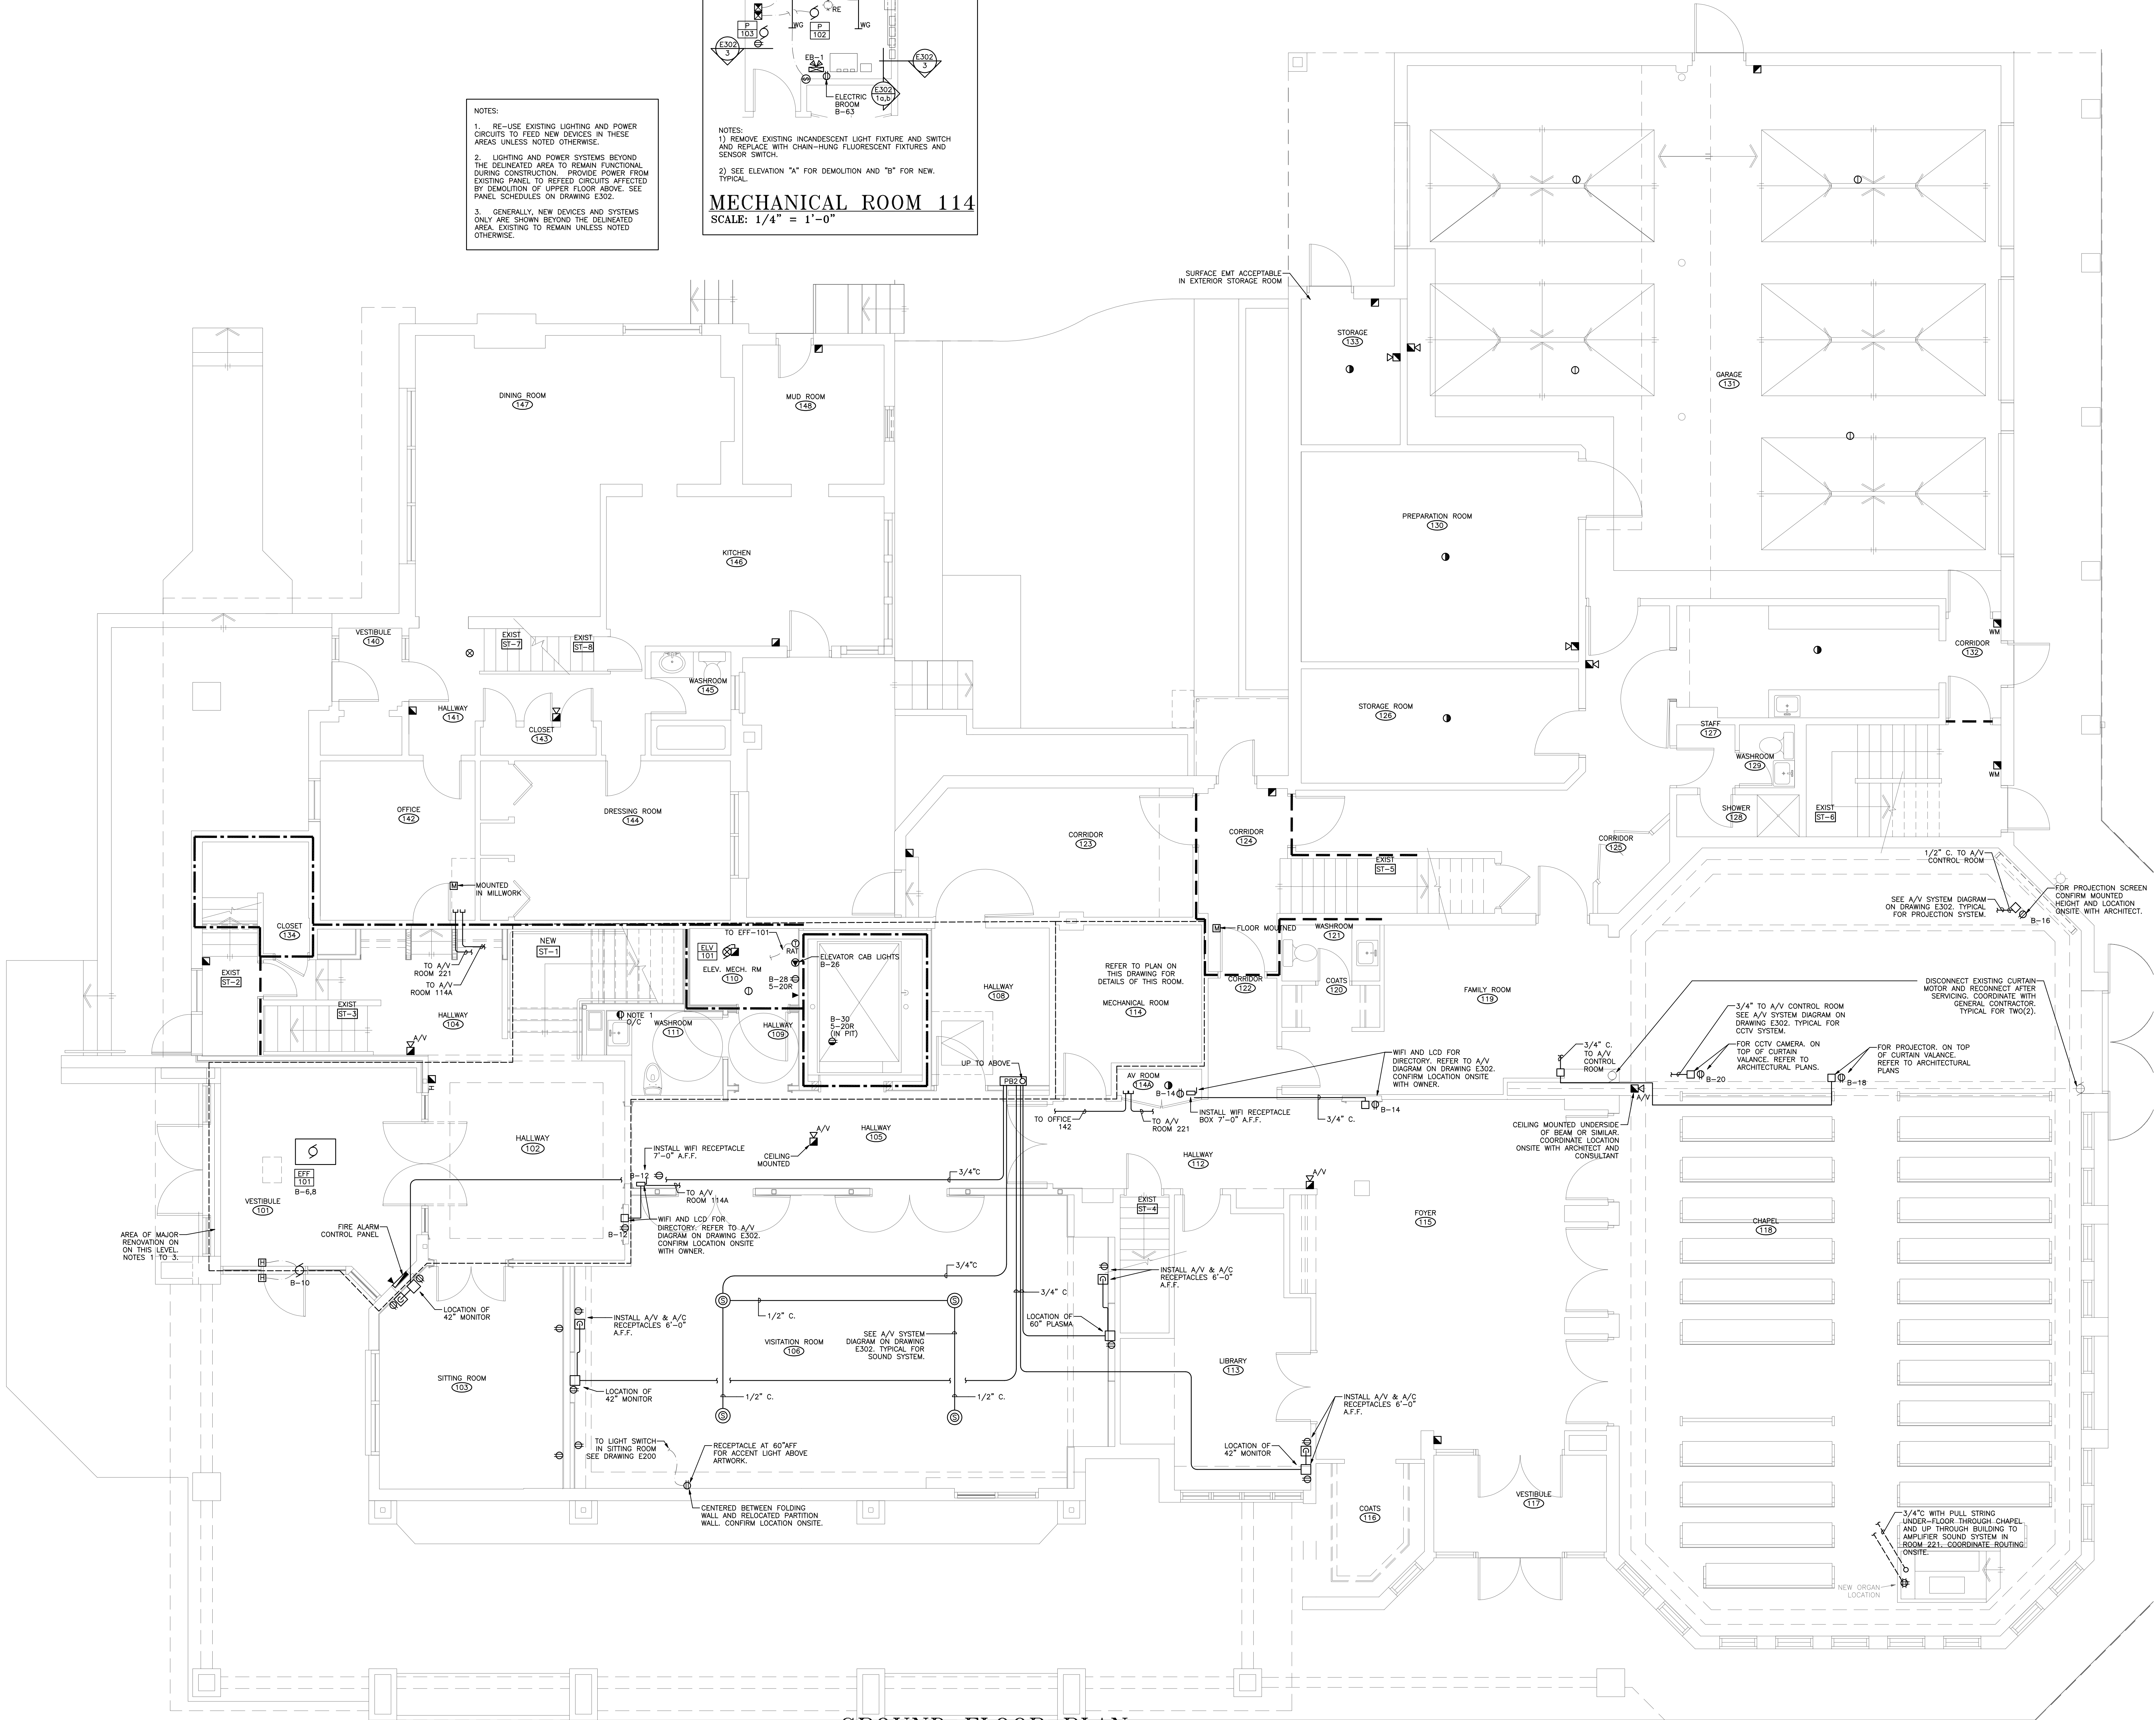

GROUND FLOOR PLAN
SCALE: 1/4" = 1'-0"