



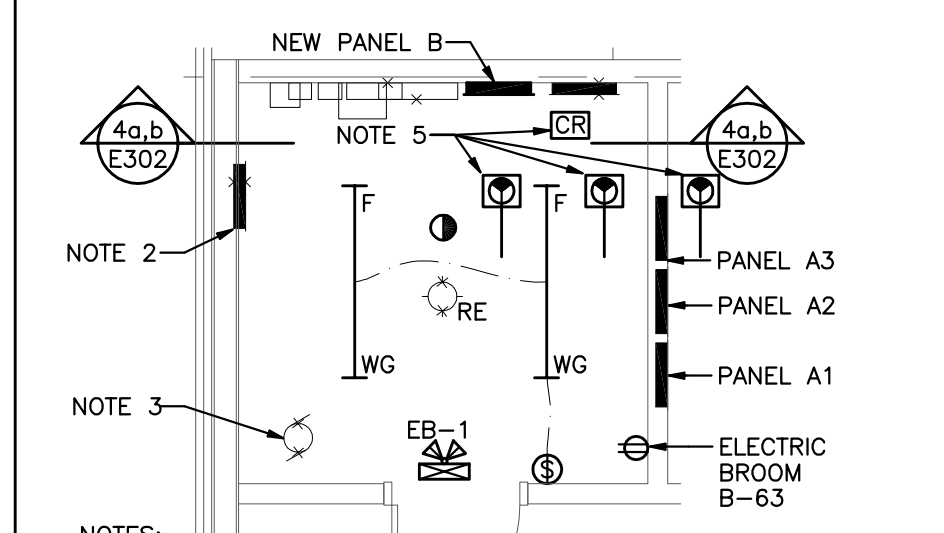

- NOTES:
1. RE-USE EXISTING LIGHTING AND POWER CIRCUITS TO FEED NEW DEVICES IN THESE AREAS UNLESS NOTED OTHERWISE.
 2. LIGHTING AND POWER SYSTEMS BEYOND THE DELINEATED AREA TO REMAIN FUNCTIONAL DURING CONSTRUCTION.
 3. GENERALLY, ONLY NEW DEVICES AND SYSTEMS ARE SHOWN BEHIND THE DELINEATED AREA. EXISTING TO REMAIN UNLESS NOTED OTHERWISE.
 4. PROVIDE NEW ELECTRIC HEAT TRACING ALONG ROOF EDGE AT LOCATION SHOWN AND IN OUTLETS AND DOWNROPS. REFER TO ARCHITECTURAL DRAWINGS. PROVIDE NEW SNOW MELTING CONTROLLER COMPLETE WITH GUTTER SENSOR AND SNOW SENSOR. SNOW MELTING CONTROLLER TO INCLUDE GFI PROTECTION FOR HEATING CABLE. APPROVED MANUFACTURERS T200 THERMAL CONTROLS OR THERMAN.
 5. DISCONNECT AND REMOVE OF EXISTING FEED BACK TO FUSED DISCONNECT, REFUSE AND RE-FEED NEW ROOFTOP UNIT AS ELECTRICAL. SEPARATE PRICE #3.
 6. DISCONNECT AND REMOVE OF EXISTING FEED BACK TO FUSED DISCONNECT, REFUSE AND RE-FEED NEW ROOFTOP UNIT AS ELECTRICAL. SEPARATE PRICE #4.

MECHANICAL ROOM 218
SCALE: 1/4" = 1'-0"

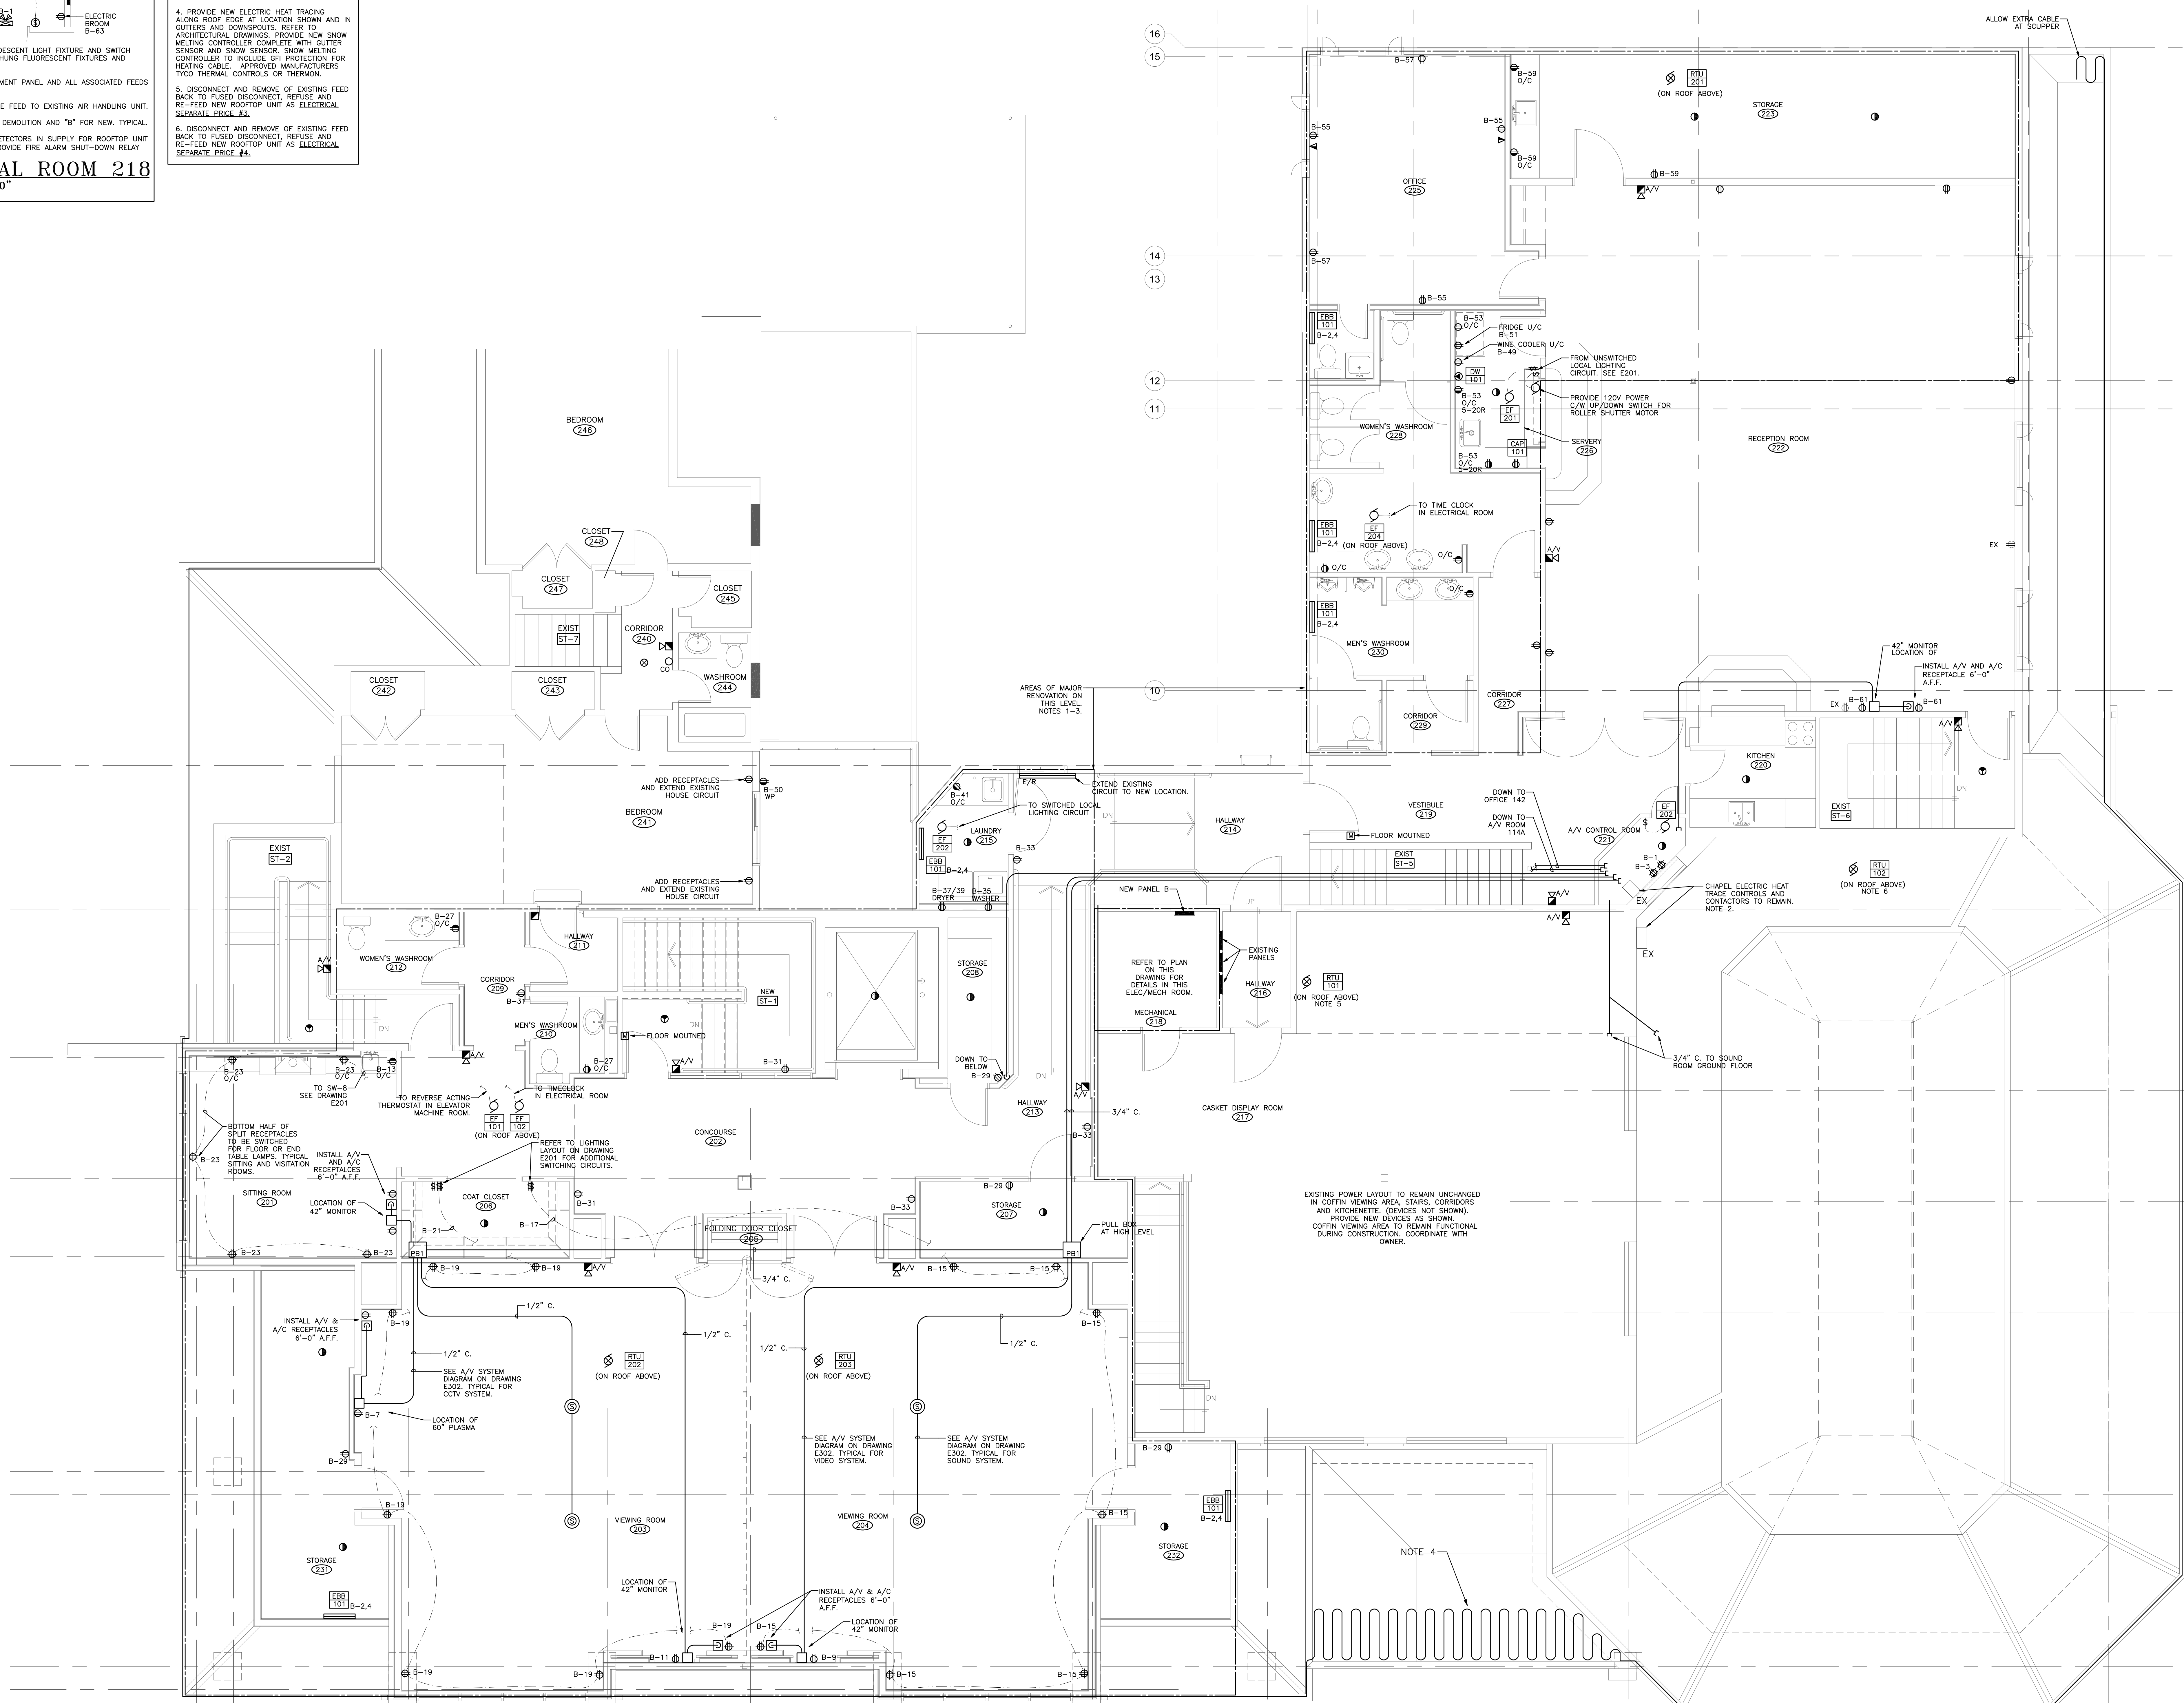

UPPER FLOOR PLAN
SCALE: 1/4" = 1'-0"

GEORGE ROBB
ARCHITECT


4800 DUNDAS STREET WEST, SUITE 201
TORONTO ONTARIO M9A 1B1
(TEL) 416-596-8301
(FAX) 416-596-1508

ALL DIMENSIONS TO BE CHECKED AND VERIFIED ON THE JOB.
ANY AND ALL DISCREPANCIES TO BE REPORTED TO THE ARCHITECT.

ALL DRAWINGS REMAIN THE PROPERTY OF THE ARCHITECT.
DO NOT SCALE DRAWINGS.

No.	Issue	Date
00	ISSUED FOR PERMIT	10.01.28
01	ISSUED FOR TENDER	10.06.01
02	RE-ISSUED FOR TENDER	11.04.08

Callidus Engineering
A Division of 1640286 Ontario Inc.
1385 North Routledge Park, Unit 9 - London, ON N6H 5N5
P: 519-472-7640 F: 519-471-9239 E: info@callidus.ca

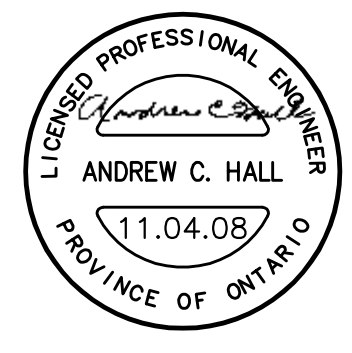

ADDITION & ALTERATIONS -
EGAN FUNERAL HOME

203 Queen St. S., Bolton, ON

Upper Floor Plan
Power and Systems

PROJECT NUMBER	CE-1157
SCALE	1/4" = 1'-0"
DATE	FEB 09, 2009
DRAWN	DJR
CHECKED	MJV
SET NO.	DRAWING NO.

E301