


LUMINAIRE SCHEDULE					
TYPE	LAMP QTY.	LAMP TYPE	VOLTAGE	DIMENSION	DESCRIPTION
L1	1	41.03W LED (3500K)	120V	3"W X 3'-7/8"H X 4"L	NARROW 4" LENSED LED STRIP LIGHT WITH ELECTRONIC DRIVER, AND FULL FROSTED LENS.
L2	1	34W LED (3500K)	120V	2'-1/8"W X 4"H X 4"L	4' EXTRUDED ALUMINUM LINEAR LED LIGHT SURFACE MOUNT WITH THREE SIDED DIFFUSE LENS AND MACHINED ALUMINUM END CAPS. STANDARD FINISH TO BE CONFIRMED BY ARCHITECT AS PART OF SHOP DRAWING PROCESS.
L3	1	35W LED (3500K)	120V	1170mm X 136mm DIA	OUTDOOR PAVEMENT MOUNTED LUMINAIRE WITH WARM WHITE LED, DOUBLE EMISSION DIFFUSION LENS, IP65 RATED, STANDARD FINISH TO BE CONFIRMED WITH ARCHITECT AS PART OF SHOP DRAWING PROCESS.
L4	1	19.2W LED (3500K)	120V	3.5"H X 3.5"D X 24" L	24" WIDE RECESSED STEP LIGHT WITH IP67 RATING WITH STEP LIGHT LENS OPTION AND INTEGRAL TRANSFORMER AND DRIVER. STANDARD FINISH TO BE CONFIRMED WITH ARCHITECT AS PART OF SHOP DRAWING PROCESS.
L5	1	48W LED (3500K) 4742 LUMENS	120V	1.1"W X 3.5"H X 4' L	4' NARROW EXTRUDED ALUMINUM LINEAR LED FIXTURE WITH REMOTE LED DRIVER. LOCATE LED DRIVER IN BASEMENT STORAGE ROOM. STANDARD FINISH TO BE CONFIRMED WITH ARCHITECT AS PART OF SHOP DRAWING PROCESS. PROVIDE MOUNTING ACCESSORIES FOR SURFACE MOUNTING ONTO METAL HOLLOW STEEL STRUCTURE.
L6	1	16W LED (3500K)	120V	6" DIA. X 17'-1/2" L	4" INTEGRATED LED RECESSED DOWNLIGHT WITH SPECIFICATION GRADE REMODEL HOUSING AND ELECTRONIC DRIVER. TRIM TO BE SPECIFICATION GRADE SPECULAR REFLECTOR WITH MEDIUM BEAM.
L7	1	26W LED (3500K)	120V	8'-1/2"D X 11'-5/8" H X 6"W	DIE-CAST ALUMINUM VABOUR TIGHT LED SERVICE LIGHT WITH FROSTED GLASS GLOBE.
X1	1	LED	120VAC /12VDC	10'-3/4"H X 4'-1/4"W X 12'-1/2"L	ALUMINUM SLIM EDGE-UT PICTOGRAM EXIT SIGN.
X2	1	LED	120VAC /12VDC	10'-3/4"H X 4'-1/4"W X 12'-1/2"L	EXTRUDED ALUMINUM PICTOGRAM EXIT SIGN. FLAT TRIM FOR CEILING RECESSED MOUNT. ANGULAR TRIM FOR END MOUNT AND WALL MOUNT.
X3	1	6W LED	120VAC /12VDC	12"H X 14"W X 6'-1/2"D	EXTRUDED ALUMINUM PICTOGRAM EXIT SIGN WITH BATTERY REMOTE HEADS AND BATTERY.


5 LIGHT FIXTURE SCHEDULE

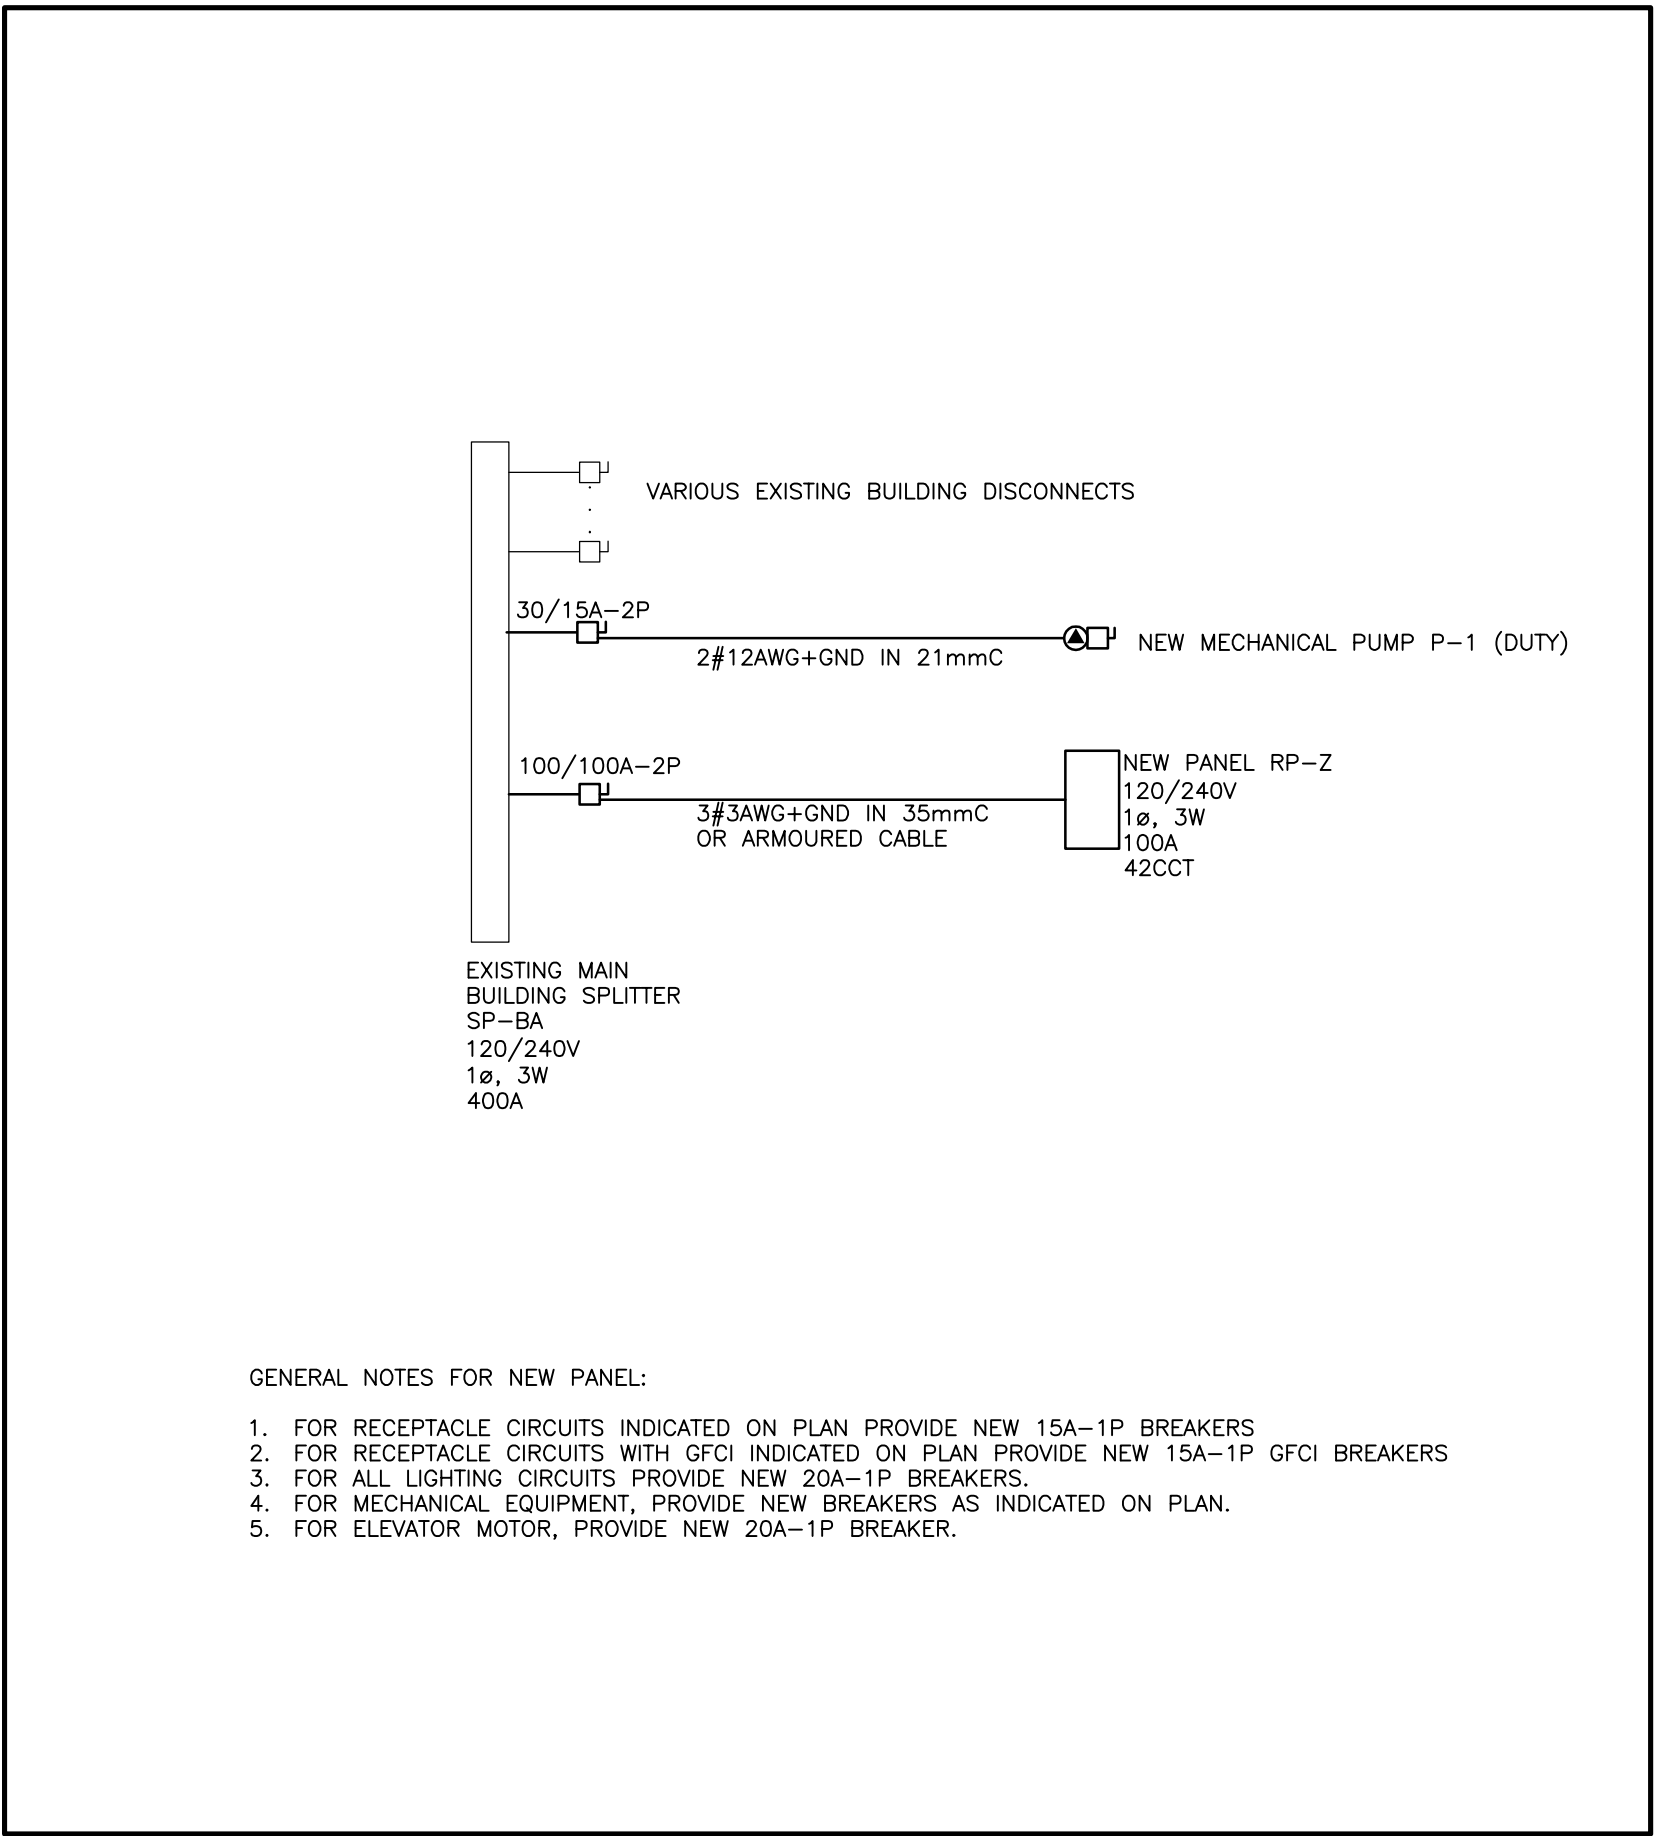

4 ELECTRICAL SINGLE LINE DIAGRAM

ELECTRICAL DRAWING LIST	
Sheet Number	Sheet Title
GENERAL	
E001	LEGEND, DRAWING LIST, AND DETAILS
E002	ELECTRICAL DETAILS
E003	ELECTRICAL BASEMENT PLAN
E004	ELECTRICAL GROUND FLOOR PLAN
POWER AND LIGHTING	
E100	POWER, LIGHTING AND SYSTEMS PLAN
ED100	POWER, LIGHTING, AND SYSTEMS DEMOLITION PLAN

1 DRAWING LIST

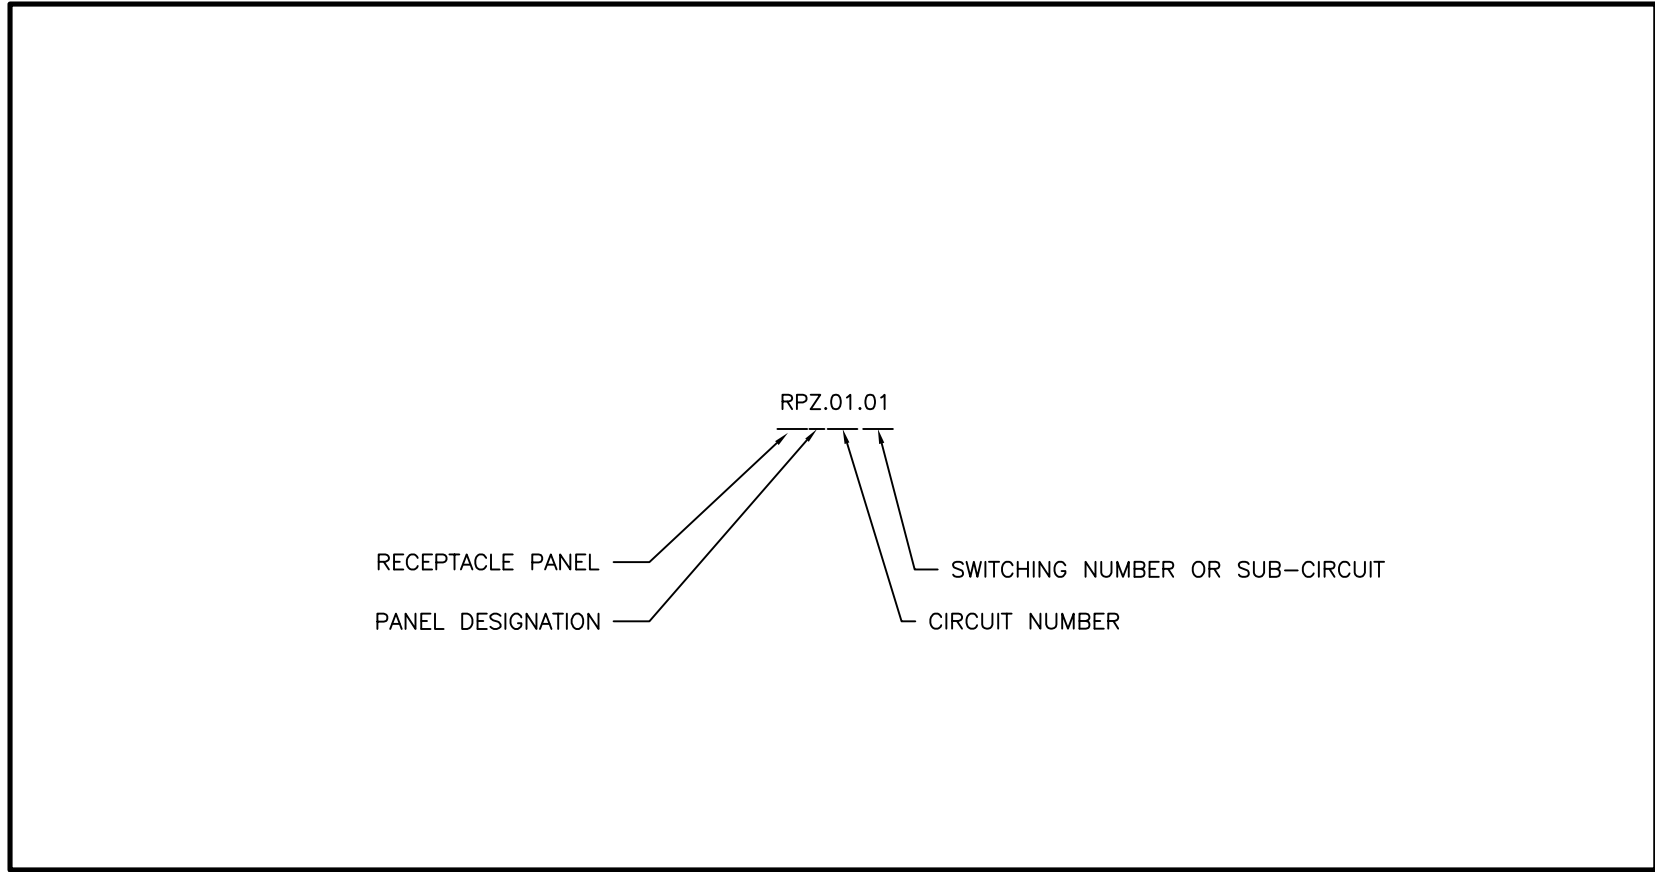


2 PANEL AND CIRCUIT DESIGNATION

SYMBOL	DESCRIPTION	SYMBOL	DESCRIPTION
	CEILING MOUNTED LINEAR LUMINAIRE. DIMENSIONS AS SHOWN. REFER TO SCHEDULE FOR TYPE.		SINGLE POLE LINE VOLTAGE LIGHT SWITCH
	DENOTES FIXTURE ON EMERGENCY/NIGHT LIGHT CIRCUIT.		3 WAY - LINE VOLTAGE LIGHT SWITCH
	WALL MOUNTED LINEAR LUMINAIRE. DIMENSIONS AS SHOWN. REFER TO SCHEDULE FOR TYPE.		4 WAY - LINE VOLTAGE LIGHT SWITCH
	BOLLARD LUMINAIRE		DIMMER TYPE TO SUIT LOAD
	EXISTING LUMINAIRE TO BE REMOVED		COMMUNICATION OUTLET. TYPICAL 1" CONDUIT BACK TO TELECOM SERVICE ENTRY
	EXISTING LUMINAIRE TO REMAIN		CEILING MOUNTED PHOTO-ELECTRIC SMOKE DETECTOR
	WALL MOUNTED LUMINAIRE		CEILING MOUNTED PHOTO-ELECTRIC SMOKE DETECTOR C/W RELAY BASE
	CEILING MOUNTED LUMINAIRE		FIRE ALARM BELL. 103mm(4") UNLESS OTHERWISE NOTED TO MATCH EXISTING.
	WALL MOUNTED EMERGENCY DOUBLE REMOTE HEAD		MANUAL PULL STATION
	CEILING MOUNTED EMERGENCY DOUBLE REMOTE HEAD		ELECTRIC STRIKE FOR ADO LATCH
	EMERGENCY LIGHTING BATTERY UNIT C/W NUMBER OF HEADS SHOWN		AUTOMATIC DOOR OPENER
	EXIT LIGHT CEILING MOUNTED C/W FACES AND ARROWS AS INDICATED		PUSH BUTTON
	EXIT LIGHT WALL MOUNTED C/W FACES AND ARROWS AS INDICATED		
	WALL MOUNTED DUPLEX RECEPTACLE 120 VOLT, 15 AMP, CSA 5-15R		
	WALL MOUNTED DUPLEX RECEPTACLE 120 VOLT, 20 AMP, CSA 5-20R (T-SLOT)		
	WALL MOUNTED DUPLEX GROUND FAULT RECEPTACLE 120 VOLT, 15 AMP, CSA 5-15R		
	WALL MOUNTED DUPLEX GROUND FAULT RECEPTACLE 120 VOLT, 20 AMP CSA 5-20R		
	SINGLE PHASE DIRECT CONNECTION	E	EXISTING TO REMAIN
	THREE PHASE DIRECT CONNECTION	R	REMOVE
	SINGLE PHASE DIRECT CONNECTION C/W DISCONNECT	ER	EXISTING DEVICE IN RELOCATED LOCATION
	THREE PHASE DIRECT CONNECTION C/W DISCONNECT	RR	REMOVE AND RELOCATE

NOTE: NOT ALL SYMBOLS APPLY, REFER TO FLOOR PLANS AND DRAWINGS

3 LEGEND

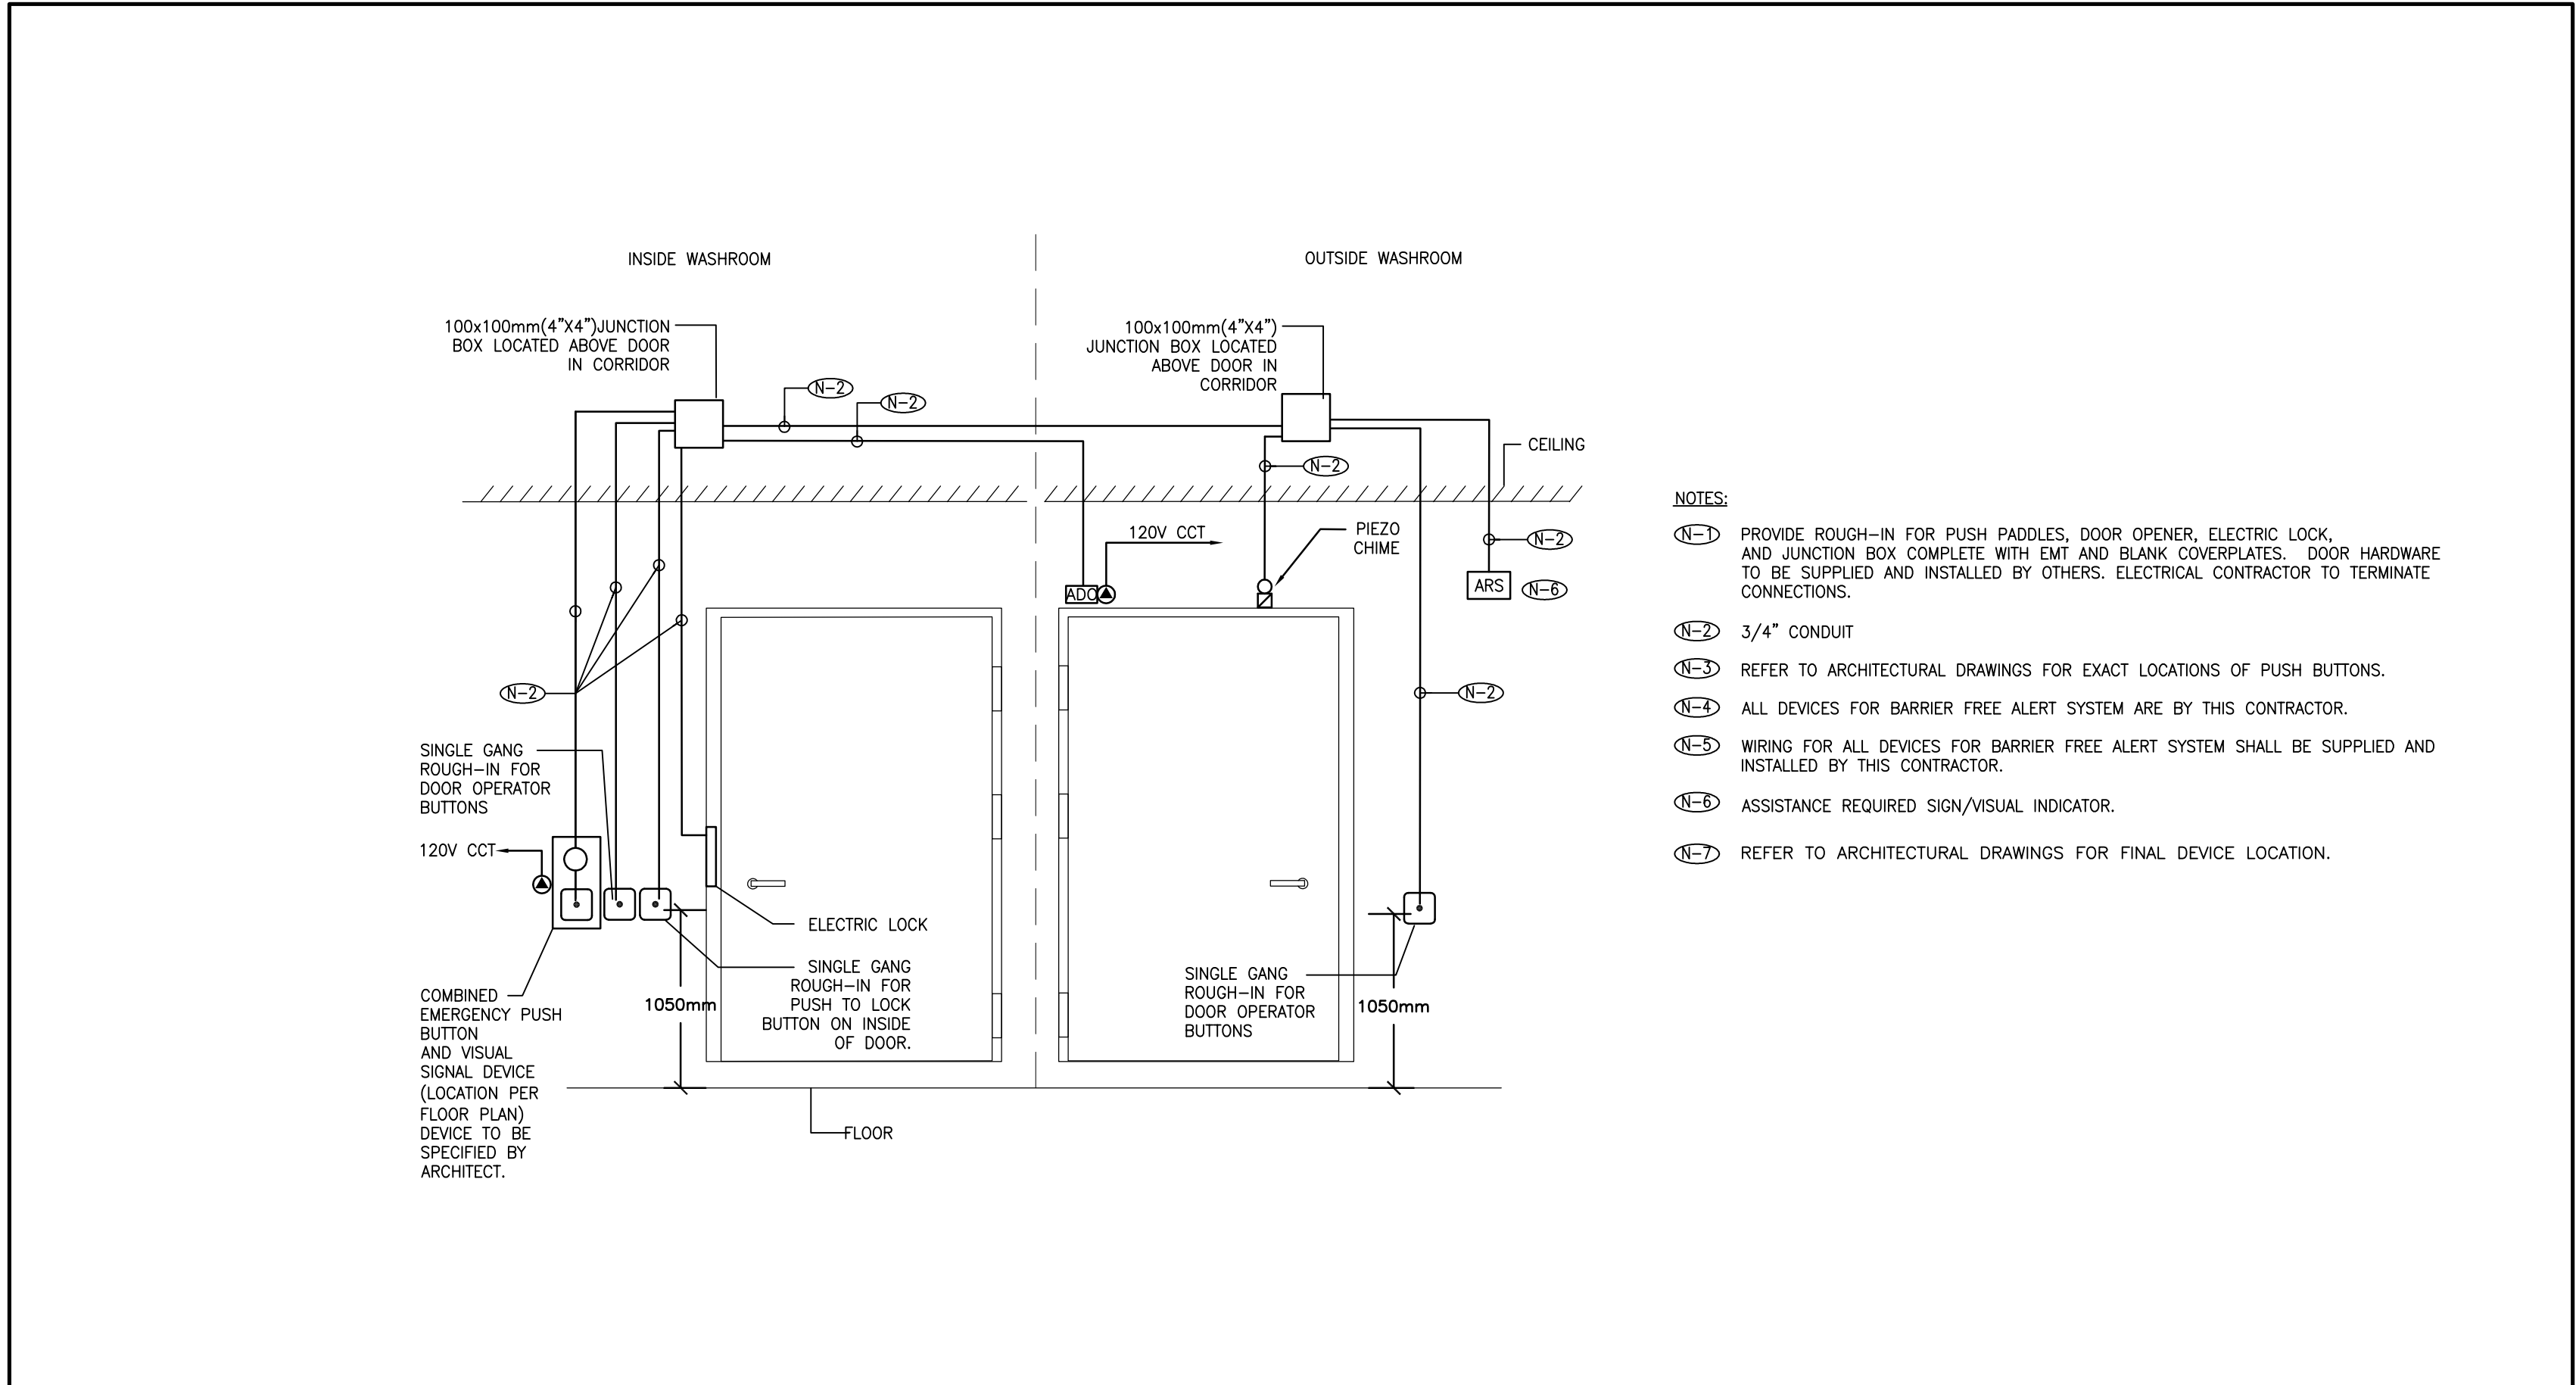

6 BARRIER FREE WASHROOM DETAIL

OUR LADY OF PERPETUAL HELP CHURCH RENOVATIONS & ADDITIONS

TORONTO, ONTARIO

Our Lady of Perpetual Help Parish
78 Clifton Road
Toronto, ON M4T 2G2



Smith + Andersen

10320-102 Ave. Suite 501 Edmonton Alberta T5J 4A1
780 701 0331 www.smithandandersen.com


Project Title :

Our Lady of Perpetual Help Addition


Title :

LEGEND, DRAWING LIST, AND DETAILS


Drawn : AW	Scale : NTS	Date : 2015.03.12
Project Number : 14214.002.E001	Drawing Number :	
Reviewed By: AW	E001	

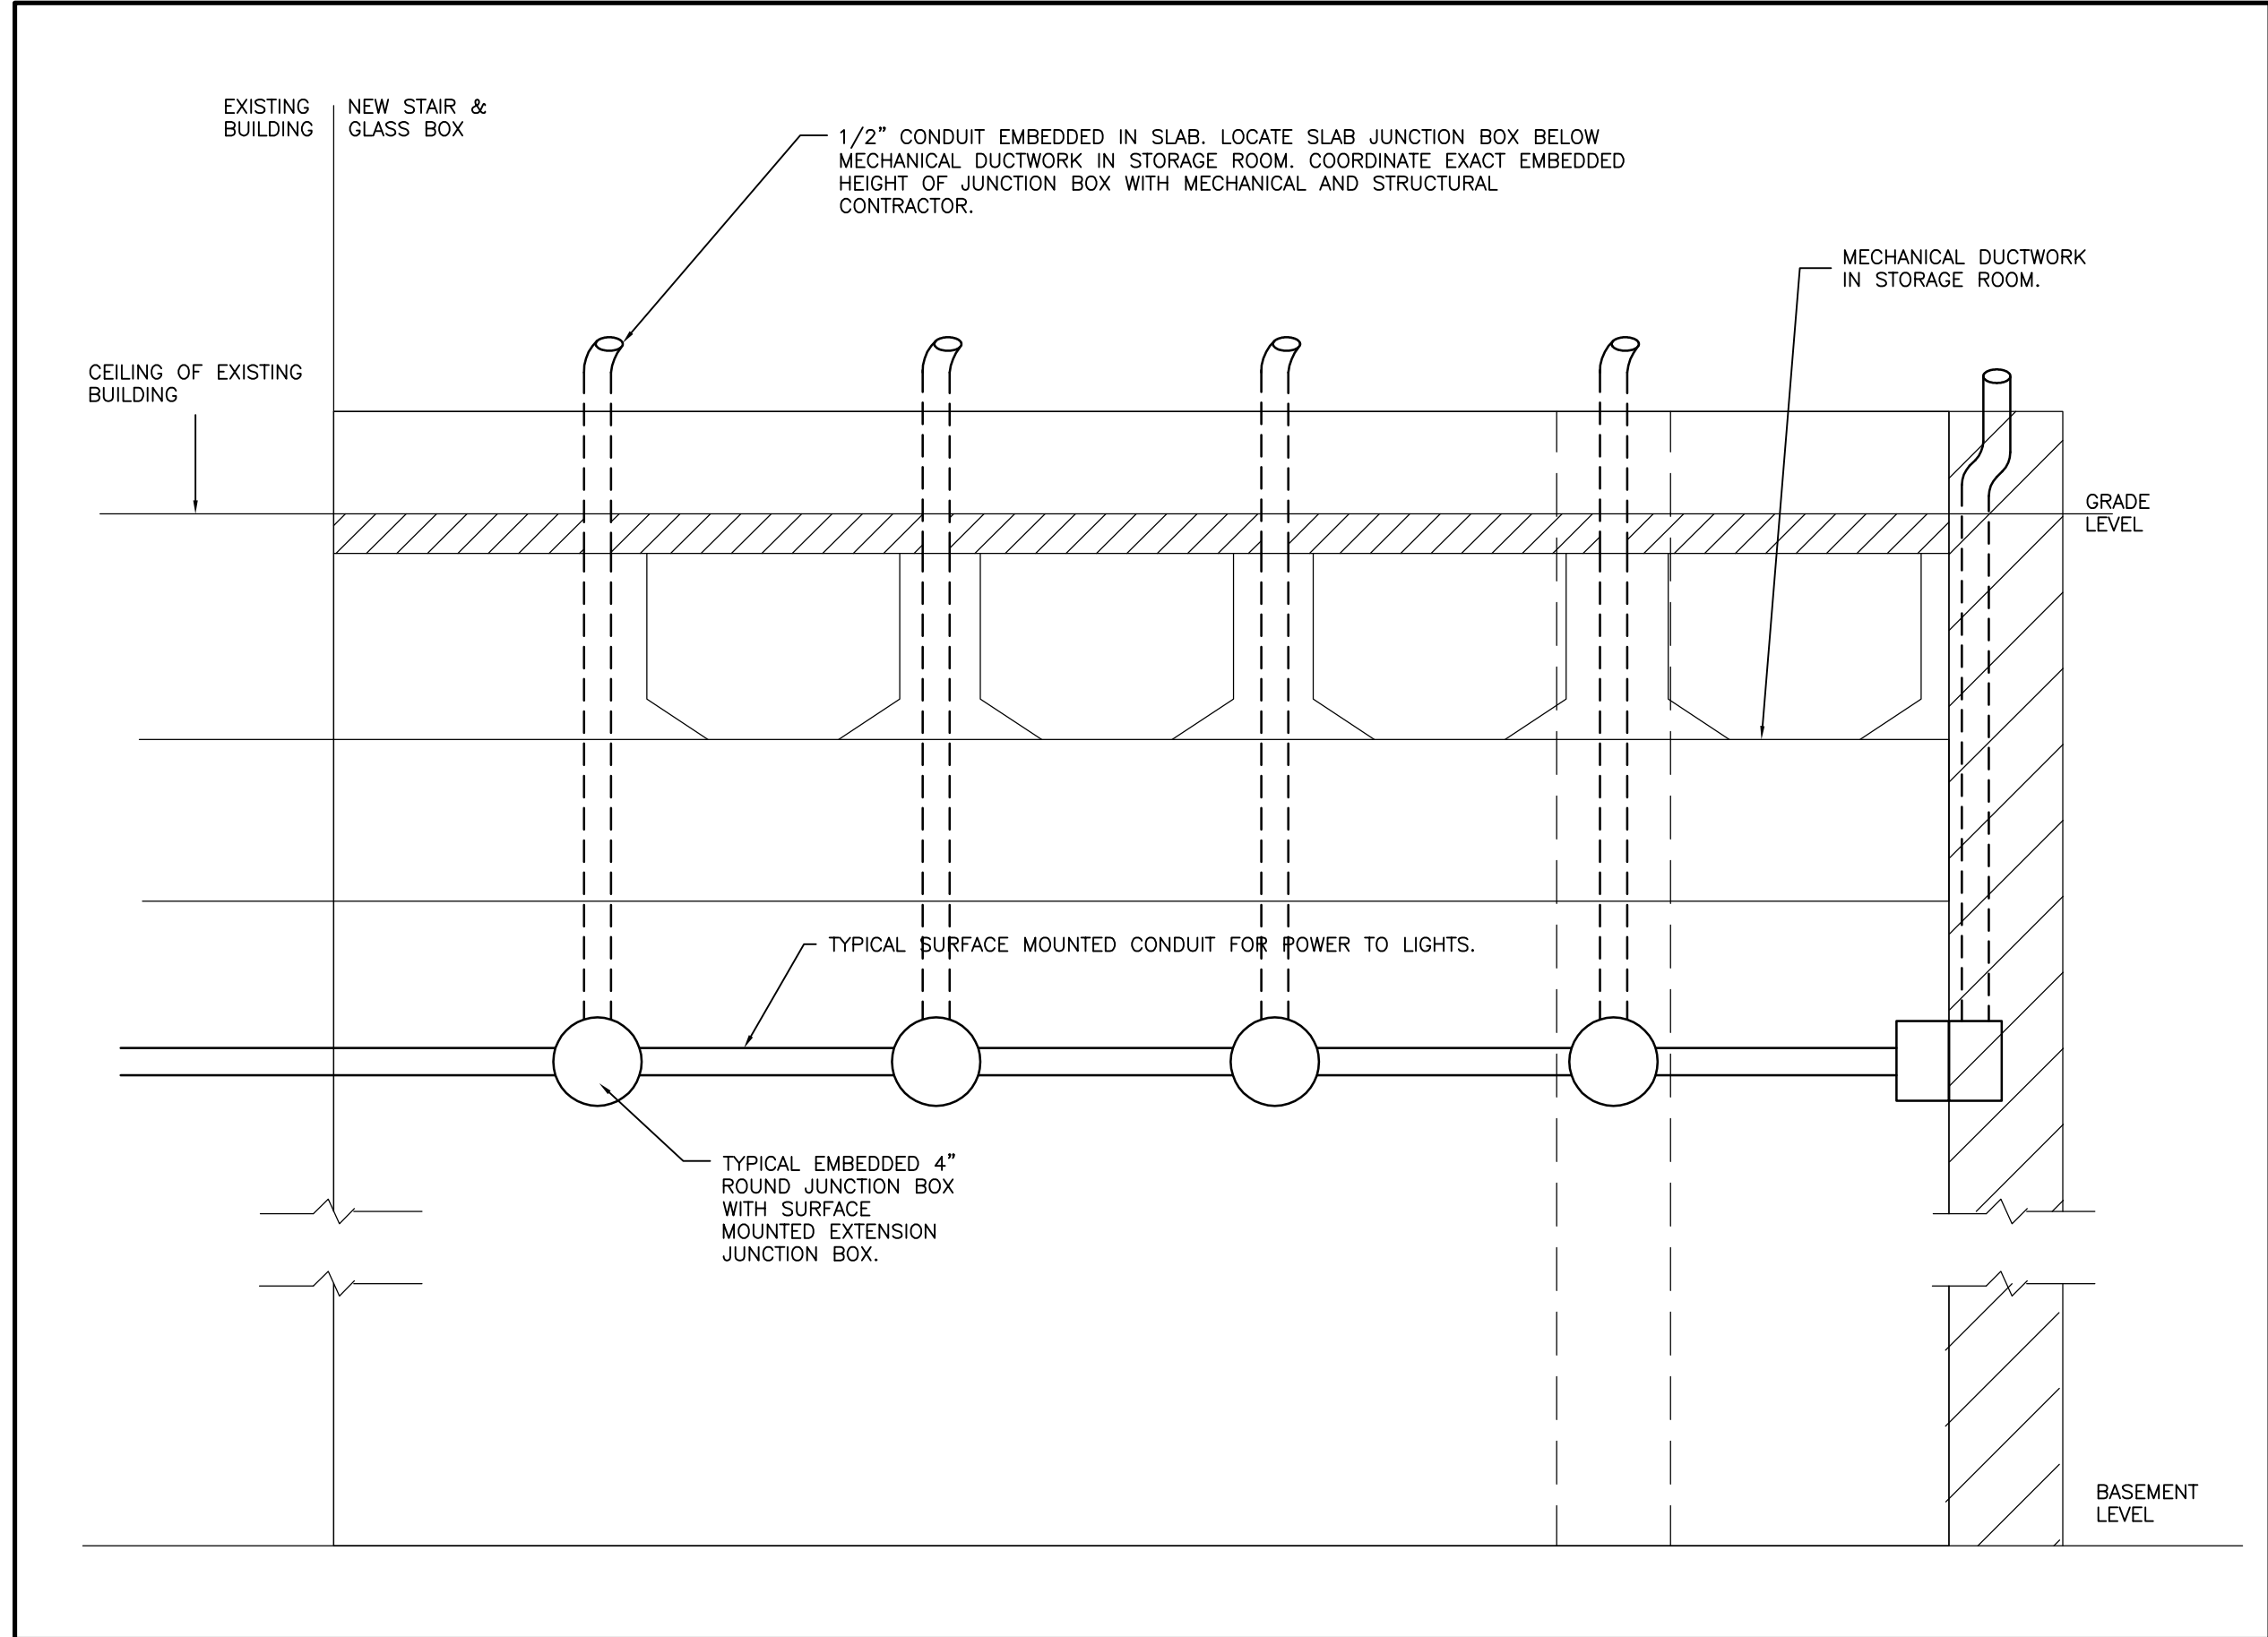


3
E002 ELEVATION DETAIL OF FOUNDATION WALL ALONG GRIDLINE 1
N.T.S.

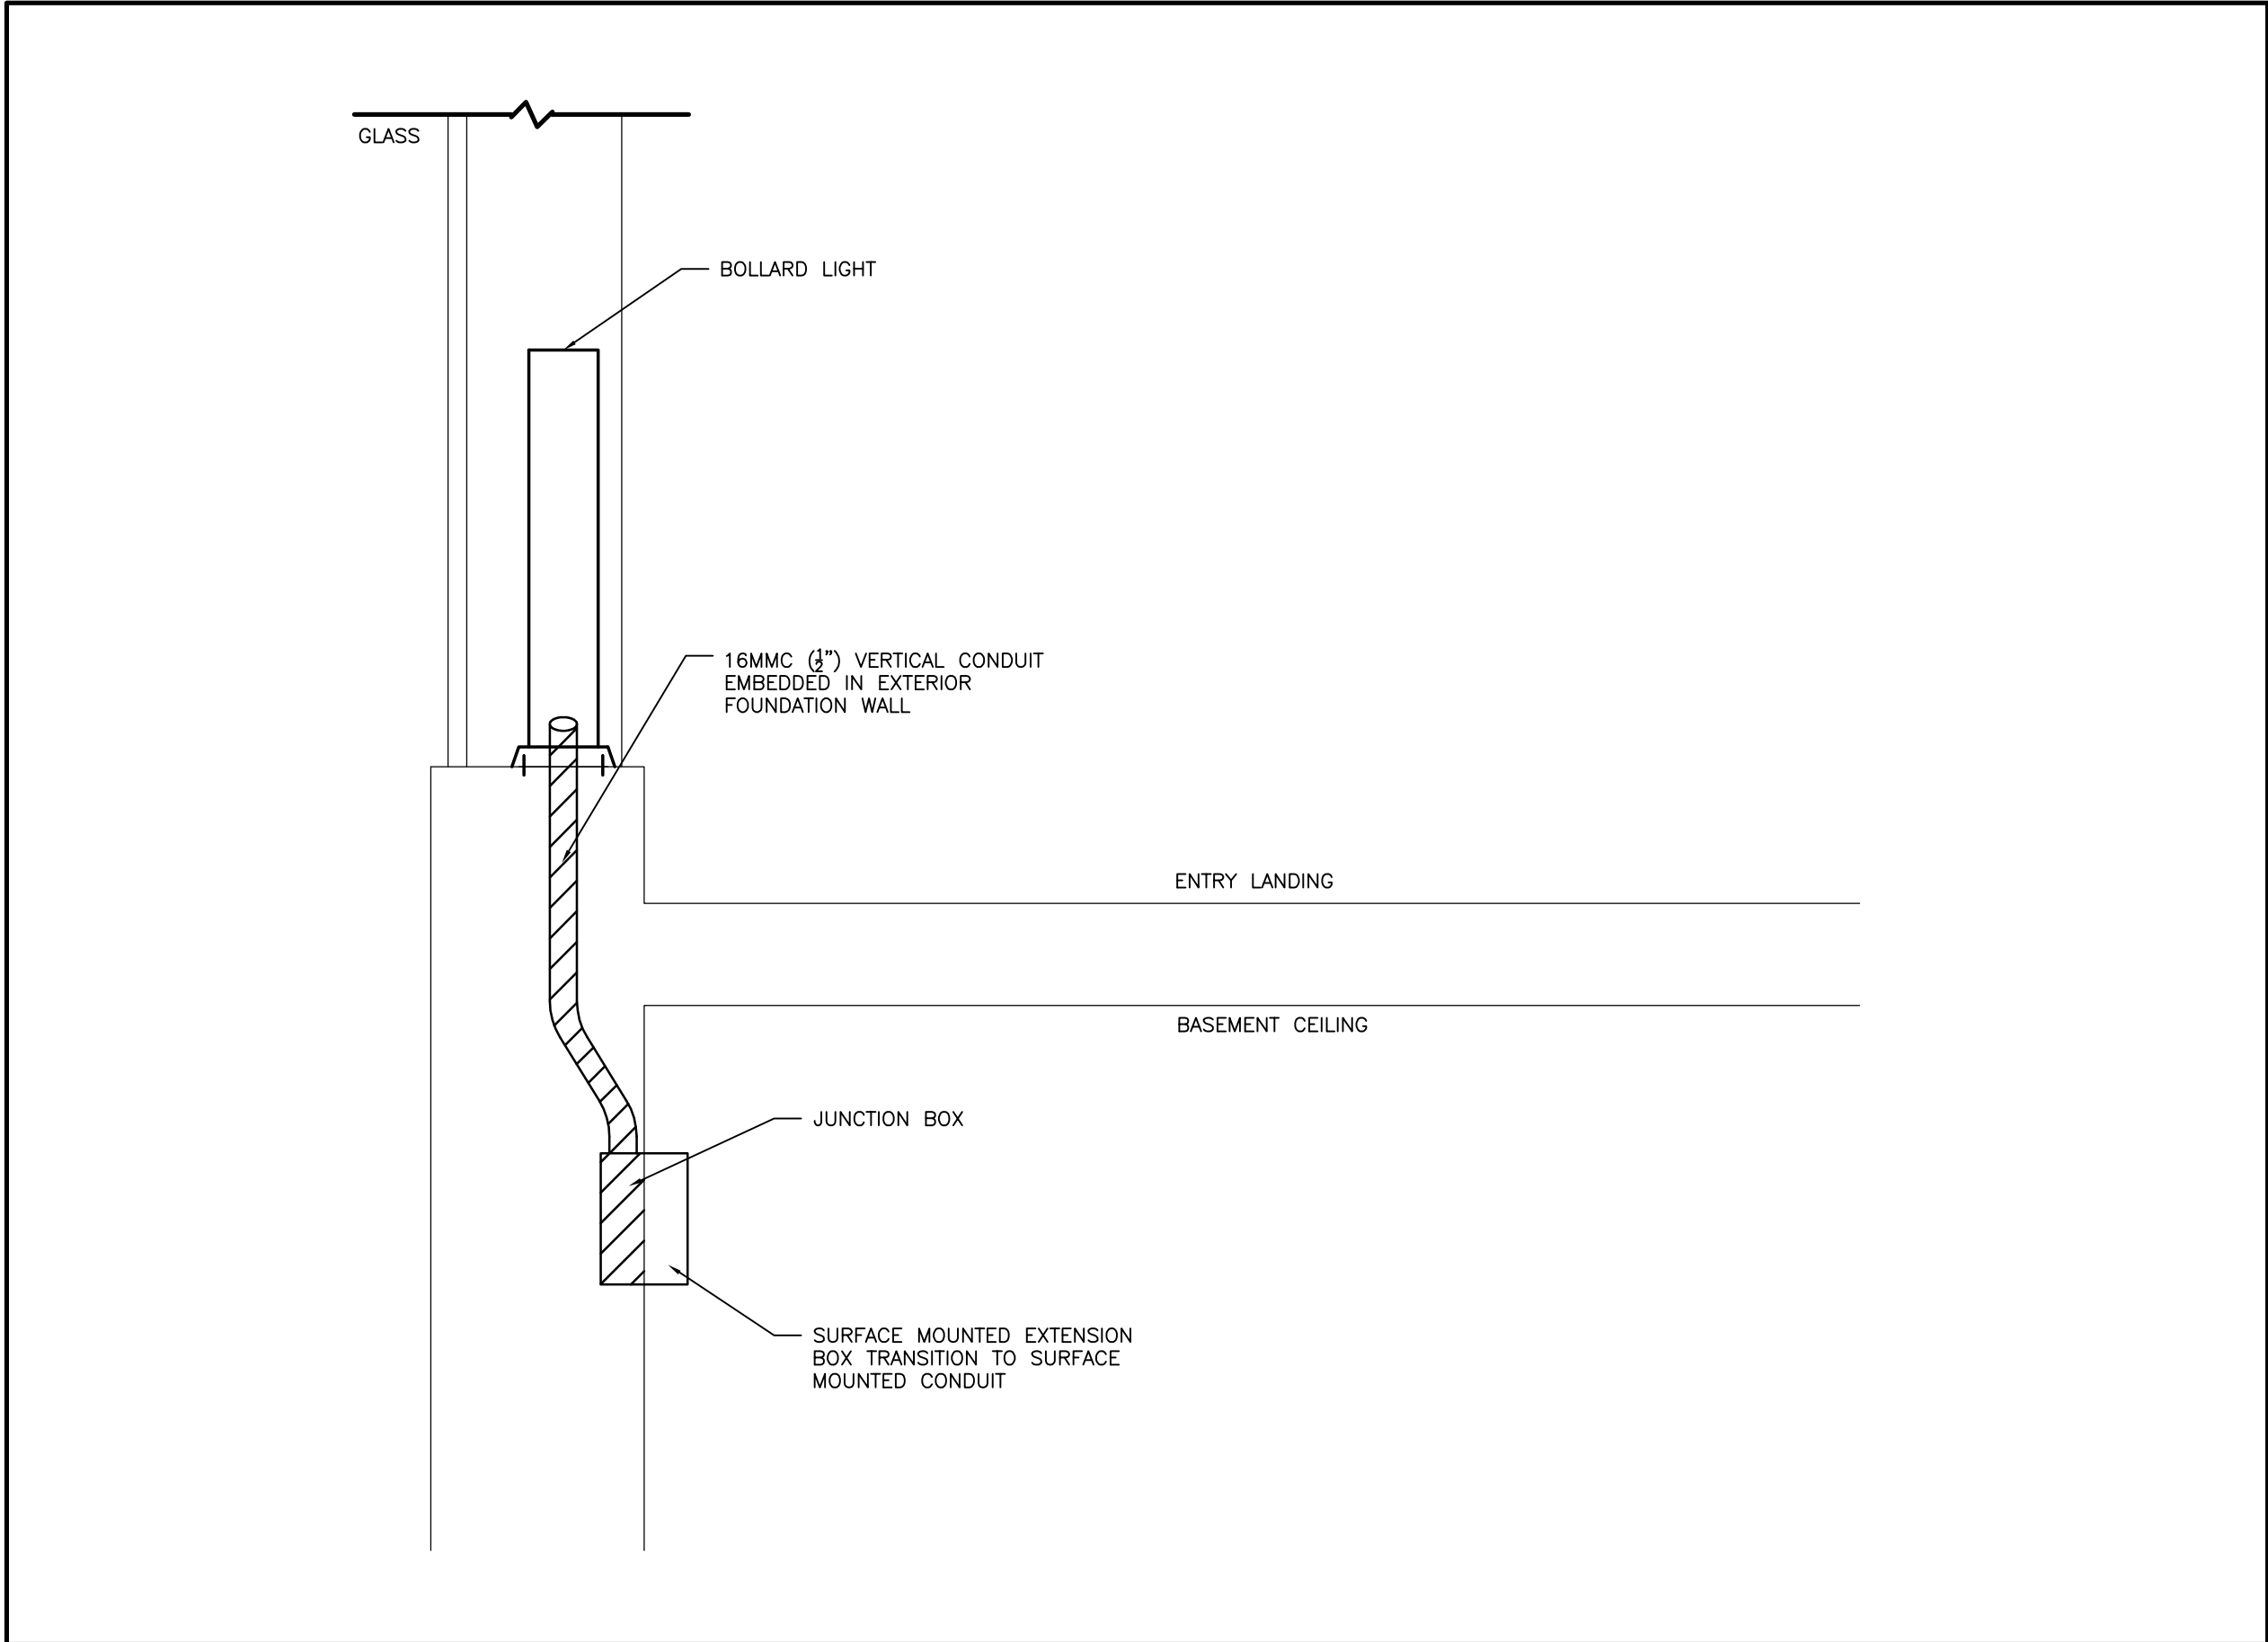

1
E002 SECTION DETAIL OF FOUNDATION WALL ALONG GRIDLINE -1
N.T.S.

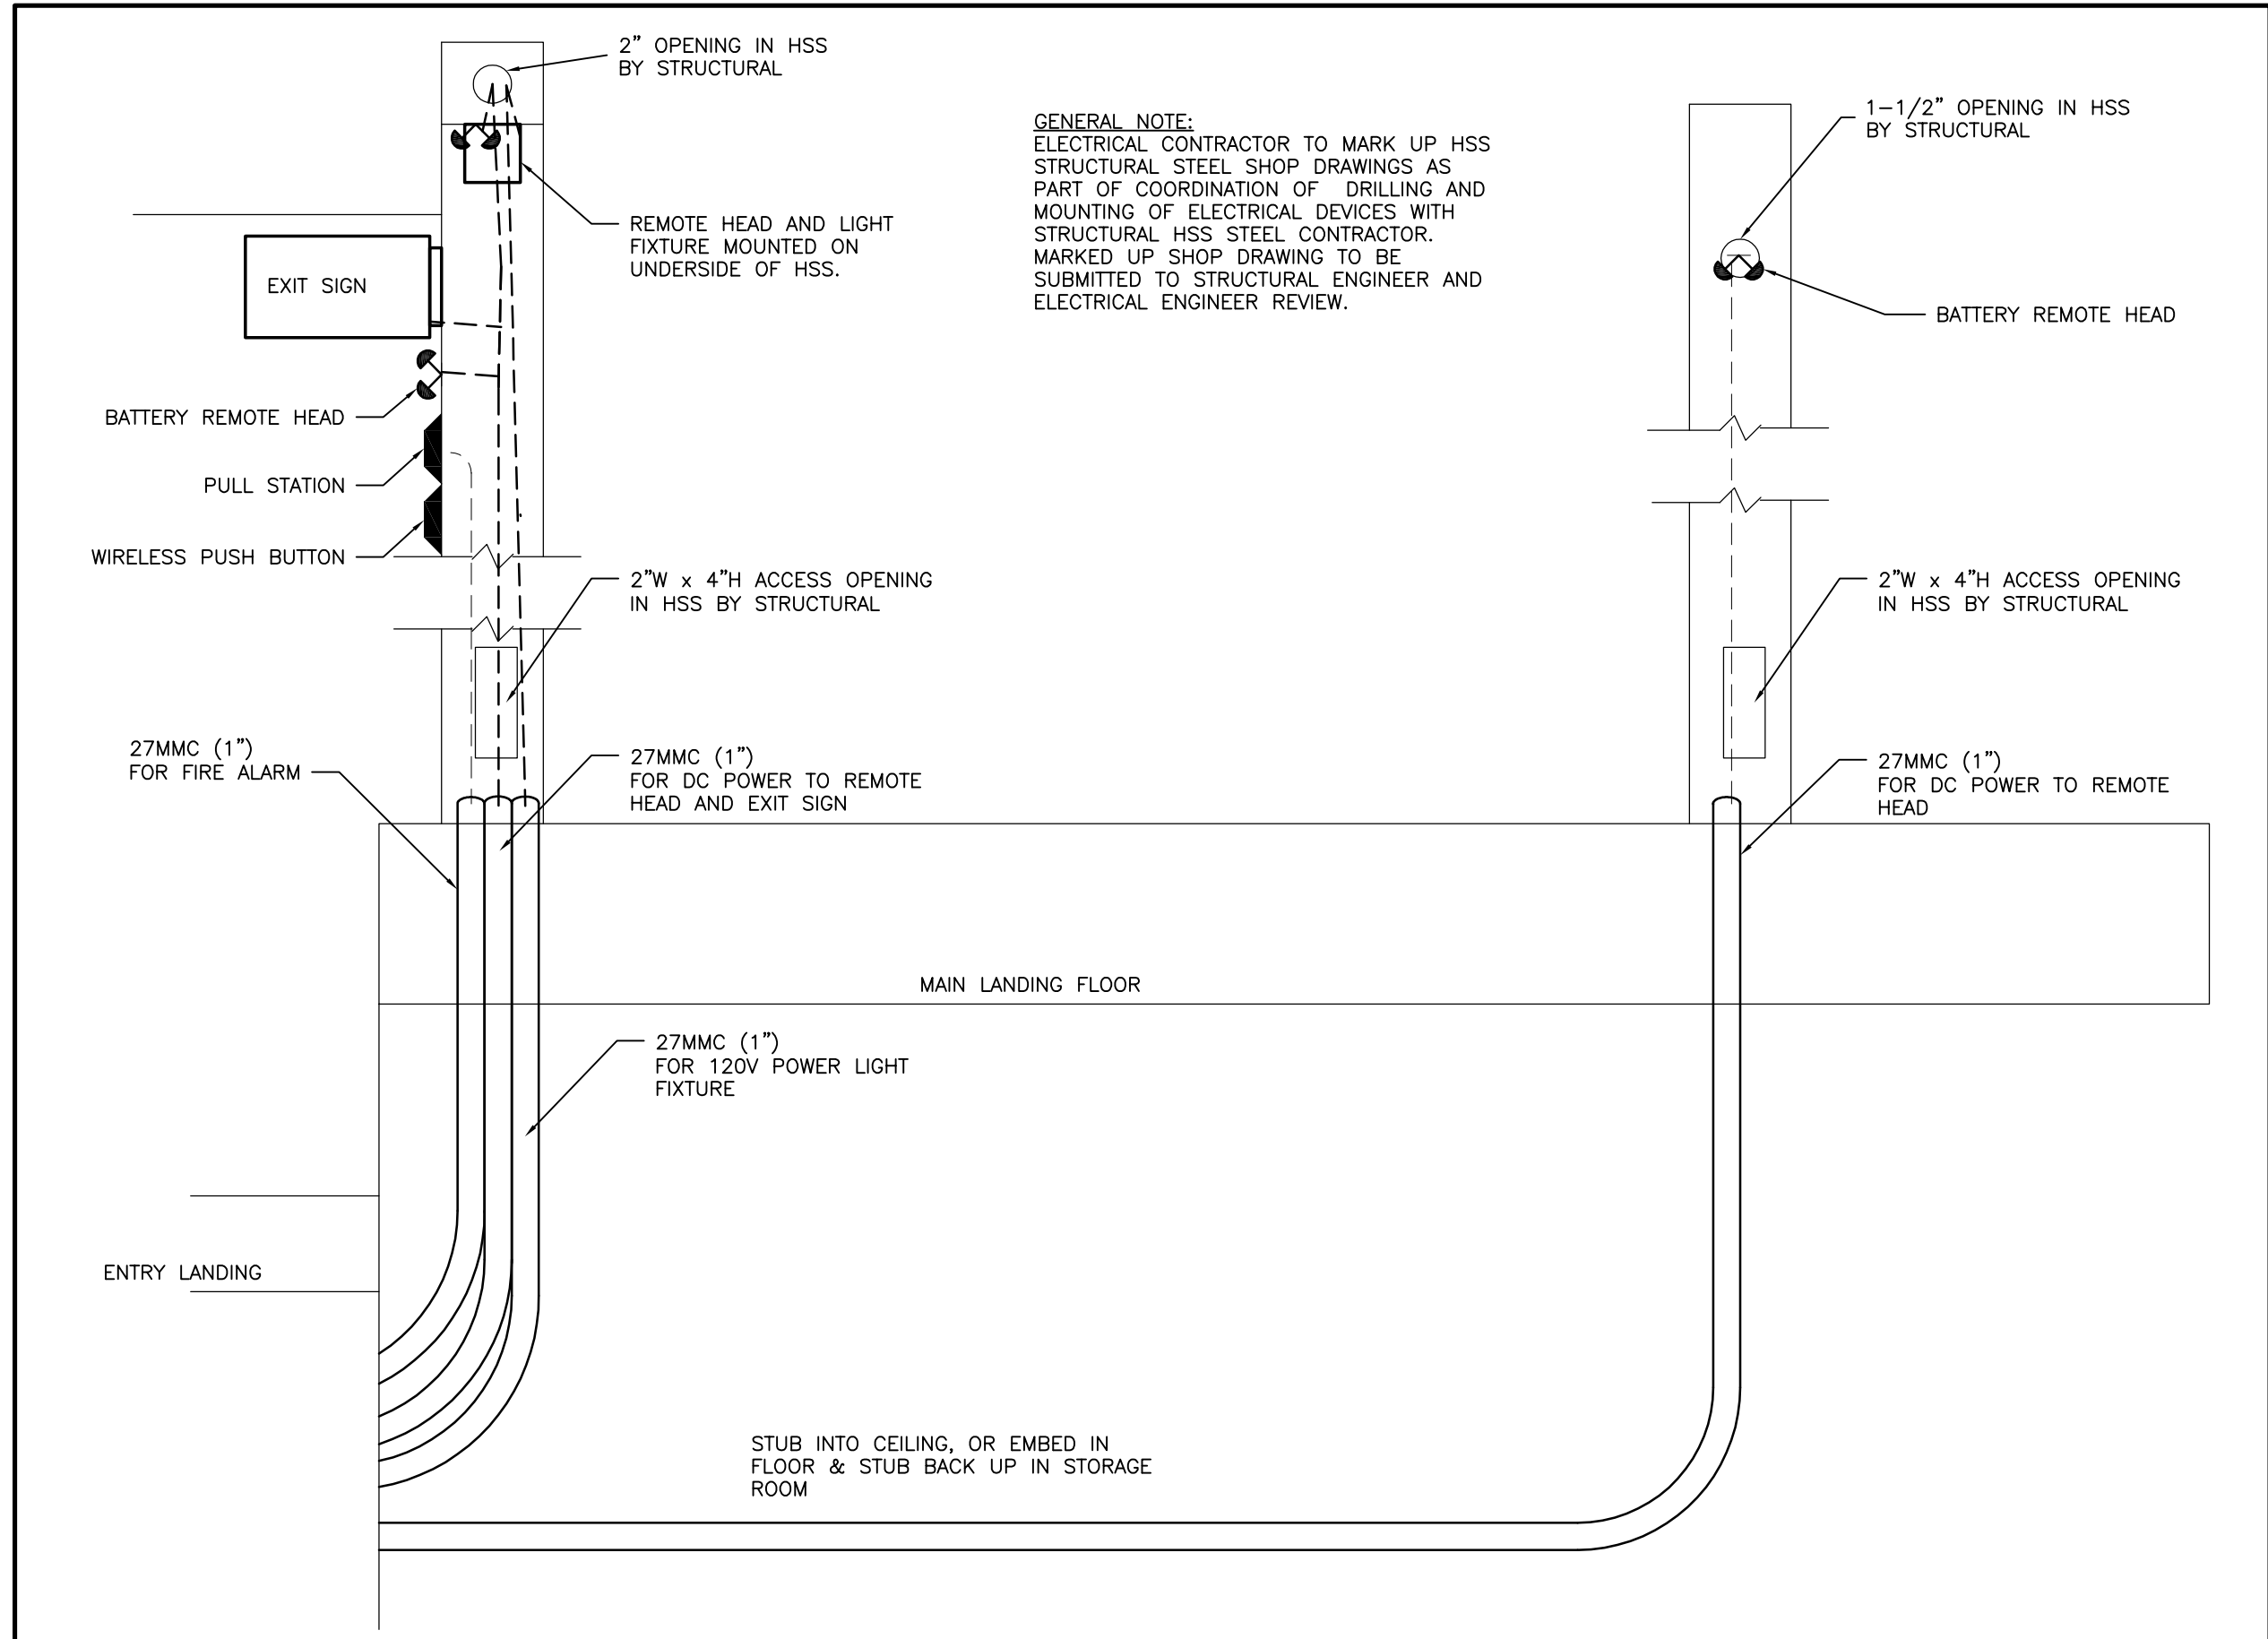

4
E002 CONDUIT STUB AND DEVICE MOUNTING DETAIL INTO HSS ALONG GRIDLINE B.
N.T.S.

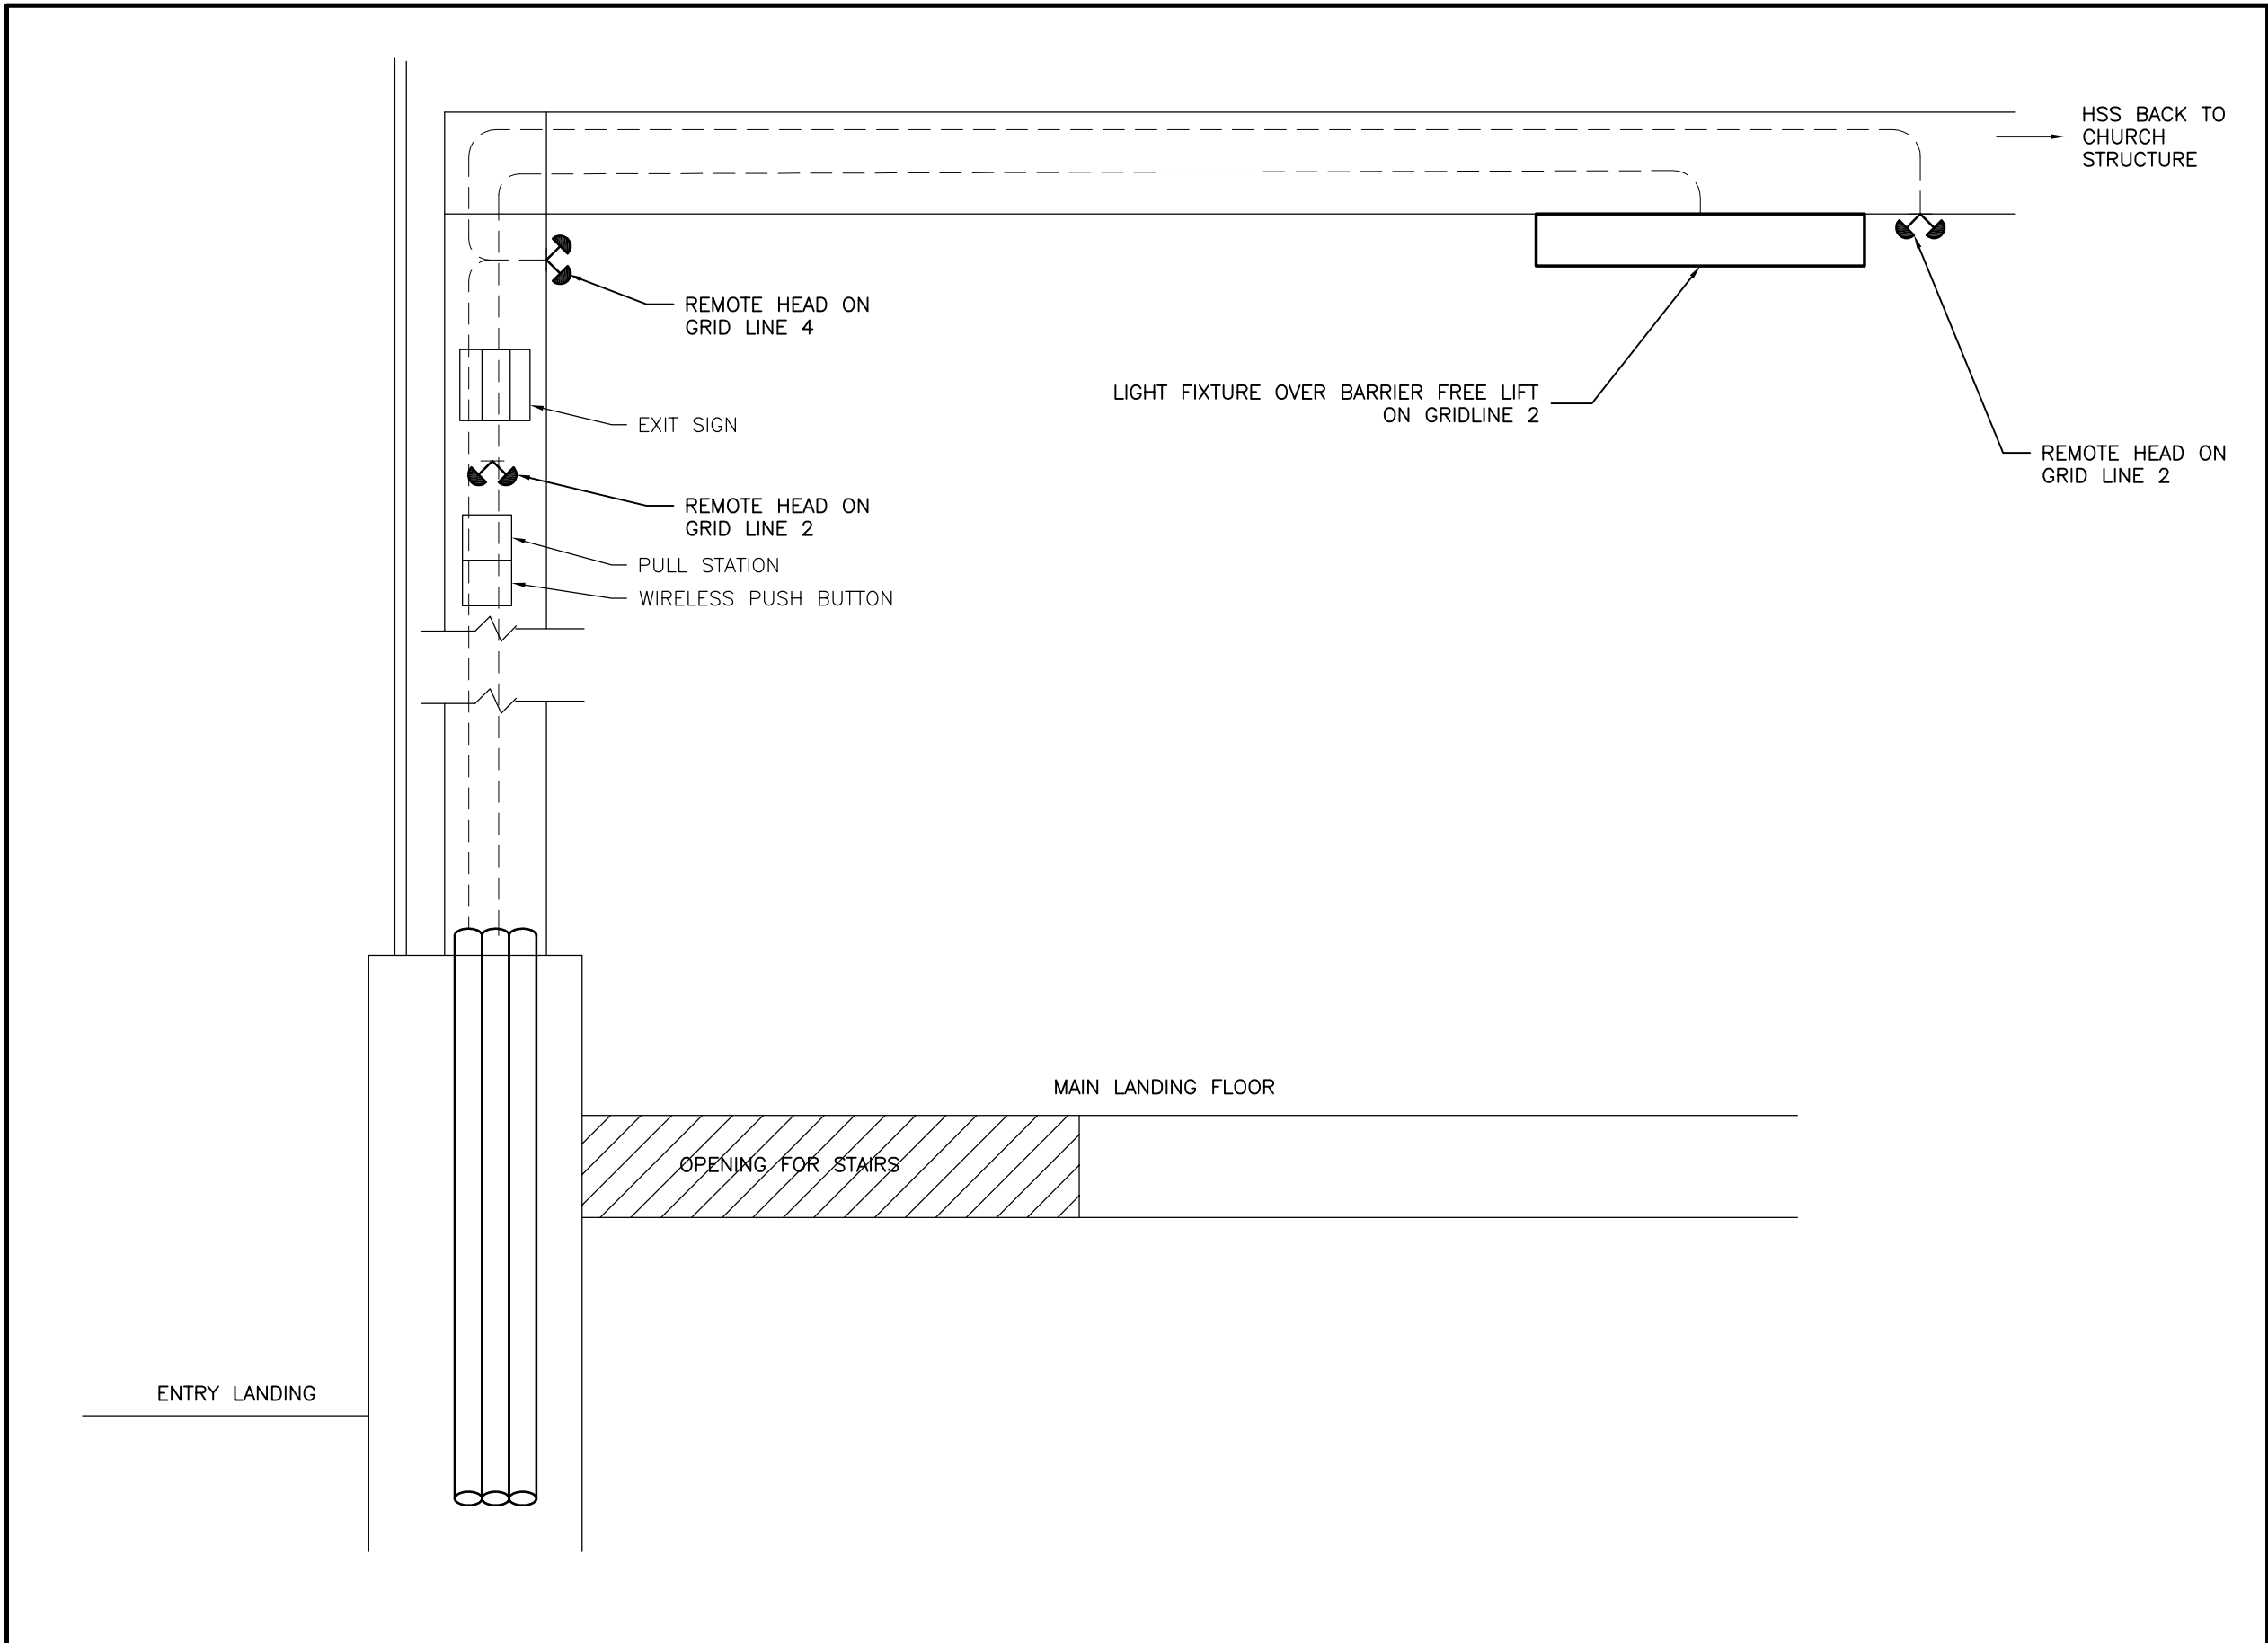

2
E002 CONDUIT STUB AND DEVICE MOUNTING DETAIL INTO HSS ALONG GRIDLINES 2 AND 4.
N.T.S.

4.	2015.12.04	ISSUED FOR TENDER
3.	2015.10.27	ISSUED FOR PERMIT
2.	2015.05.01	ISSUED FOR PERMIT REVIEW
1.	2015.04.30	ISSUED FOR PROGRESS
REV.	DATE	ISSUED

ALL MEASUREMENTS MUST BE CHECKED ON THE JOB BY THE CONTRACTOR. DRAWINGS MUST NOT BE SCALED. ALL DRAWINGS AND SPECIFICATIONS ARE THE PROPERTY OF THE ARCHITECT AND MUST BE RETURNED UPON REQUEST.

OUR LADY OF PERPETUAL HELP CHURCH RENOVATIONS & ADDITIONS

TORONTO, ONTARIO

Our Lady of Perpetual Help Parish
78 Clifton Road
Toronto, ON M4T 2G2



Smith + Andersen
10320-102 Ave, Suite 501 Edmonton Alberta T5J 4A1
780 701 0331 www.smithandandersen.com

Project Title :


Our Lady of Perpetual Help Addition

Title :

ELECTRICAL DETAILS

Drawn :	AW	Scale :	N.T.S.	Date :	2015.03.12
Project Number :	14214.002.E001	Drawing Number :			
Reviewed By :	AW				E002

22' x 34'

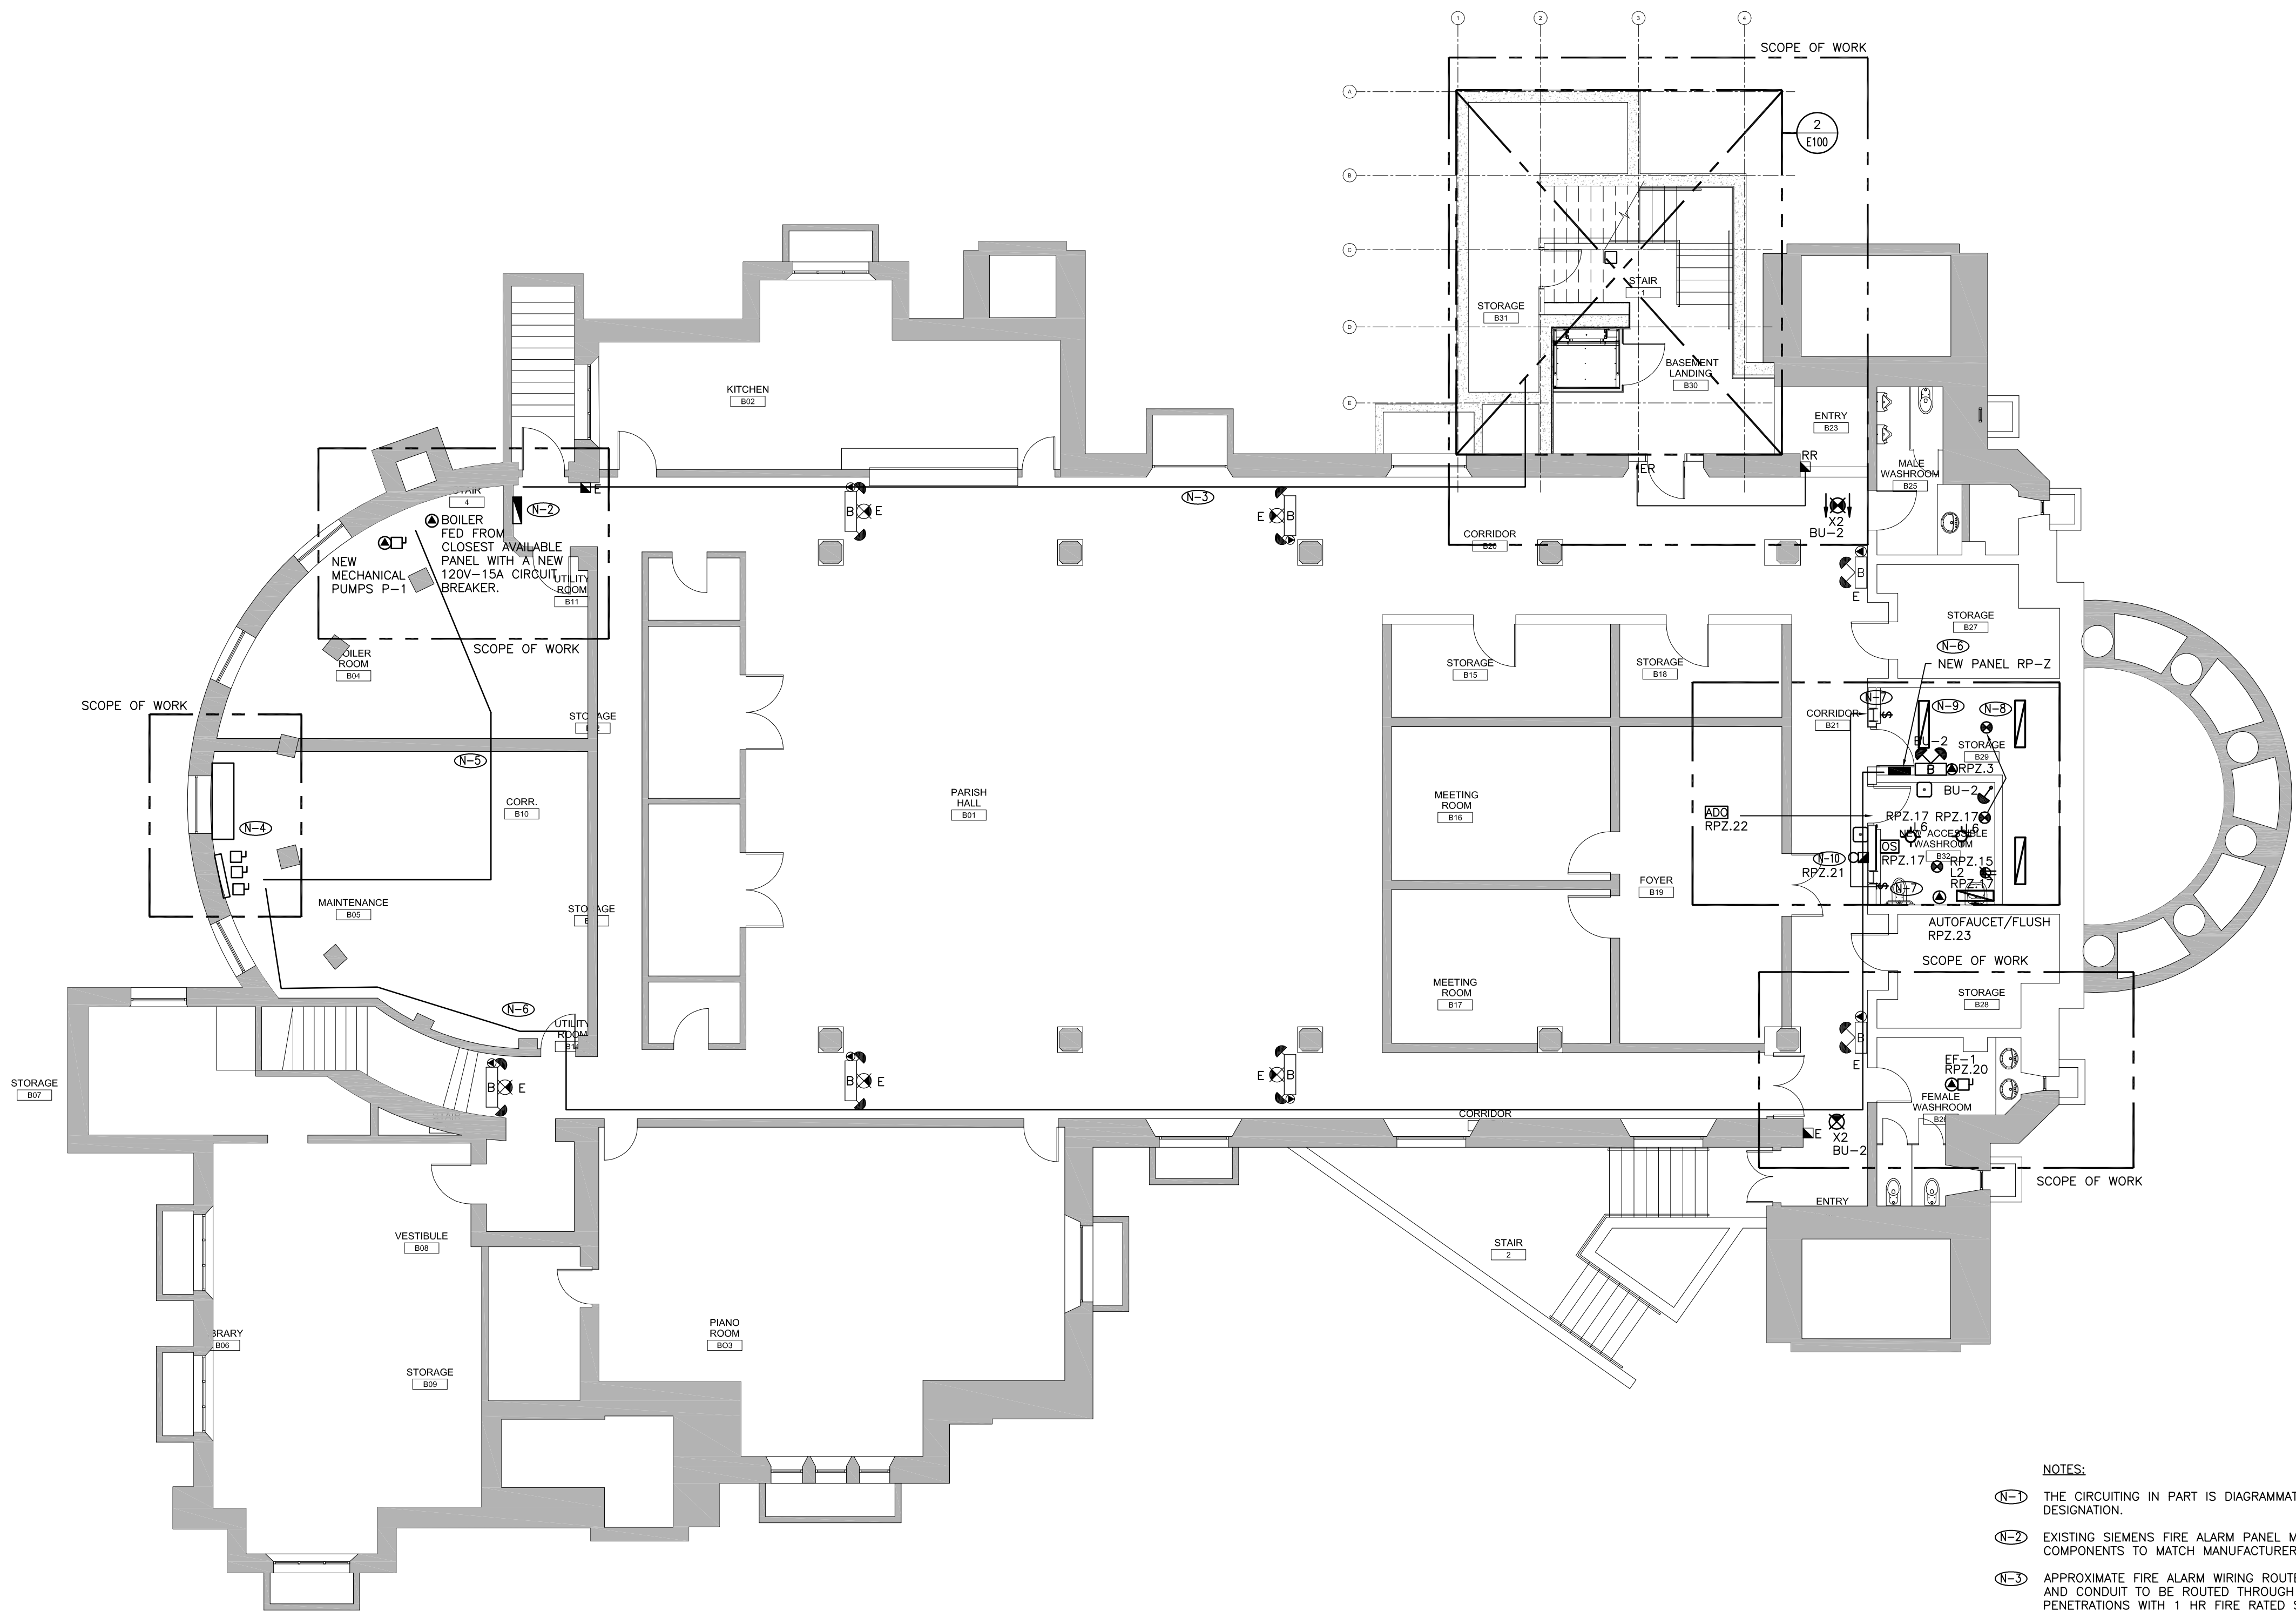

- NOTES:**
- (N-1) THE CIRCUITING IN PART IS DIAGRAMMATIC INTENDED TO SHOW GENERAL CIRCUIT ARRANGEMENT AND PANEL DESIGNATION.
 - (N-2) EXISTING SIEMENS FIRE ALARM PANEL MODEL TXL-1000. TIE ALL NEW FIRE ALARM DEVICES BACK TO PANEL. COMPONENTS TO MATCH MANUFACTURER OR BE COMPATIBLE WITH EXISTING SYSTEM.
 - (N-3) APPROXIMATE FIRE ALARM WIRING ROUTE FROM EXISTING PANEL TO NEW BARRIER FREE STAIR AREA. WIRING AND CONDUIT TO BE ROUTED THROUGH CEILING SPACE. ELECTRICAL CONTRACTOR TO CORE AND SEAL ALL PENETRATIONS WITH 1 HR FIRE RATED SEALANT.
 - (N-4) MAIN 120/240V, 400A UTILITY SERVICE ENTRANCE DISCONNECT, SPLITTER AND DISTRIBUTION DISCONNECTS AND PANELS. FOR DESIGNATION PURPOSES, SPLITTER IS INDICATED AS SP-BA. CONTRACTOR TO TAP INTO EXISTING SPLITTER SP-BA AND PROVIDE NEW BRANCH DISTRIBUTION AS INDICATED.
 - (N-5) APPROXIMATE ROUTING TO PROVIDE POWER TO MECHANICAL PUMPS. ELECTRICAL CONTRACTOR TO CORE AND SEAL ALL PENETRATIONS WITH 1 HR FIRE RATED SEALANT.
 - (N-6) APPROXIMATE ROUTING TO NEW PANEL ROUTED THROUGH CEILING SPACE. ELECTRICAL CONTRACTOR TO CORE AND SEAL ALL PENETRATIONS WITH 1 HR FIRE RATED SEALANT. NEW ELECTRICAL PANEL TO FEED NEW RENOVATION ELECTRICAL LOADS.
 - (N-7) RELOCATE EXISTING LIGHT SWITCH FOR STORAGE ROOM LIGHTING TO NEW DOOR LOCATION.
 - (N-8) RELOCATE EXISTING FIRE ALARM SMOKE DETECTOR TO AVOID NEW BARRIER FREE WASHROOM.
 - (N-9) RELOCATE THREE EXISTING CHAIN HUNG STRIP LIGHTS WITH REFLECTORS AS SHOWN TO ACCOMMODATE NEW BARRIER FREE WASHROOM.
 - (N-10) PROVIDE BARRIER FREE INTERCOM ALARM AS PER DETAIL 6 OF DRAWING E001. COORDINATE EXACT LOCATION WITH ARCHITECT. PROVIDE LOCALIZED INTERCOM OUTSIDE WASHROOM WITH TELEPHONE LINE BACK TO UTILITY ROOM FOR CONNECTION TO EMERGENCY SERVICES. FURTHERMORE, ALL DOOR OPERATOR CONTROLS, BUILDING CONTROLS, SWITCHES, THERMOSTATS ETC IN WASHROOM SHALL BE MOUNTED AT HEIGHTS IN COMPLIANCE WITH O. REG 368/13 SECTION 3.8.1.5 (1) FOR BARRIER FREE WASHROOM DESIGNS.

4.	2015.12.04	ISSUED FOR TENDER
3.	2015.10.27	ISSUED FOR PERMIT
2.	2015.05.01	ISSUED FOR PERMIT REVIEW
1.	2015.04.30	ISSUED FOR PROGRESS
REV.	DATE	ISSUED

ALL MEASUREMENTS MUST BE CHECKED ON THE JOB BY THE CONTRACTOR. DRAWINGS MUST NOT BE SCALED. ALL DRAWINGS AND SPECIFICATIONS ARE THE PROPERTY OF THE ARCHITECT AND MUST BE RETURNED UPON REQUEST.

OUR LADY OF PERPETUAL HELP CHURCH RENOVATIONS & ADDITIONS

TORONTO, ONTARIO

Our Lady of Perpetual Help Parish
78 Clifton Road
Toronto, ON M4T 2G2



Smith + Andersen
10320-102 Ave, Suite 501 Edmonton Alberta T5J 4A1
780 701 0331 www.smithandandersen.com


Project Title :

Our Lady of Perpetual Help Addition

Title :
ELECTRICAL BASEMENT PLAN

Drawn : 14214.002.E001	Scale : 1:100	Date : 2015.03.12
Reviewed By: AW	Drawing Number :	E003

22' x 34'

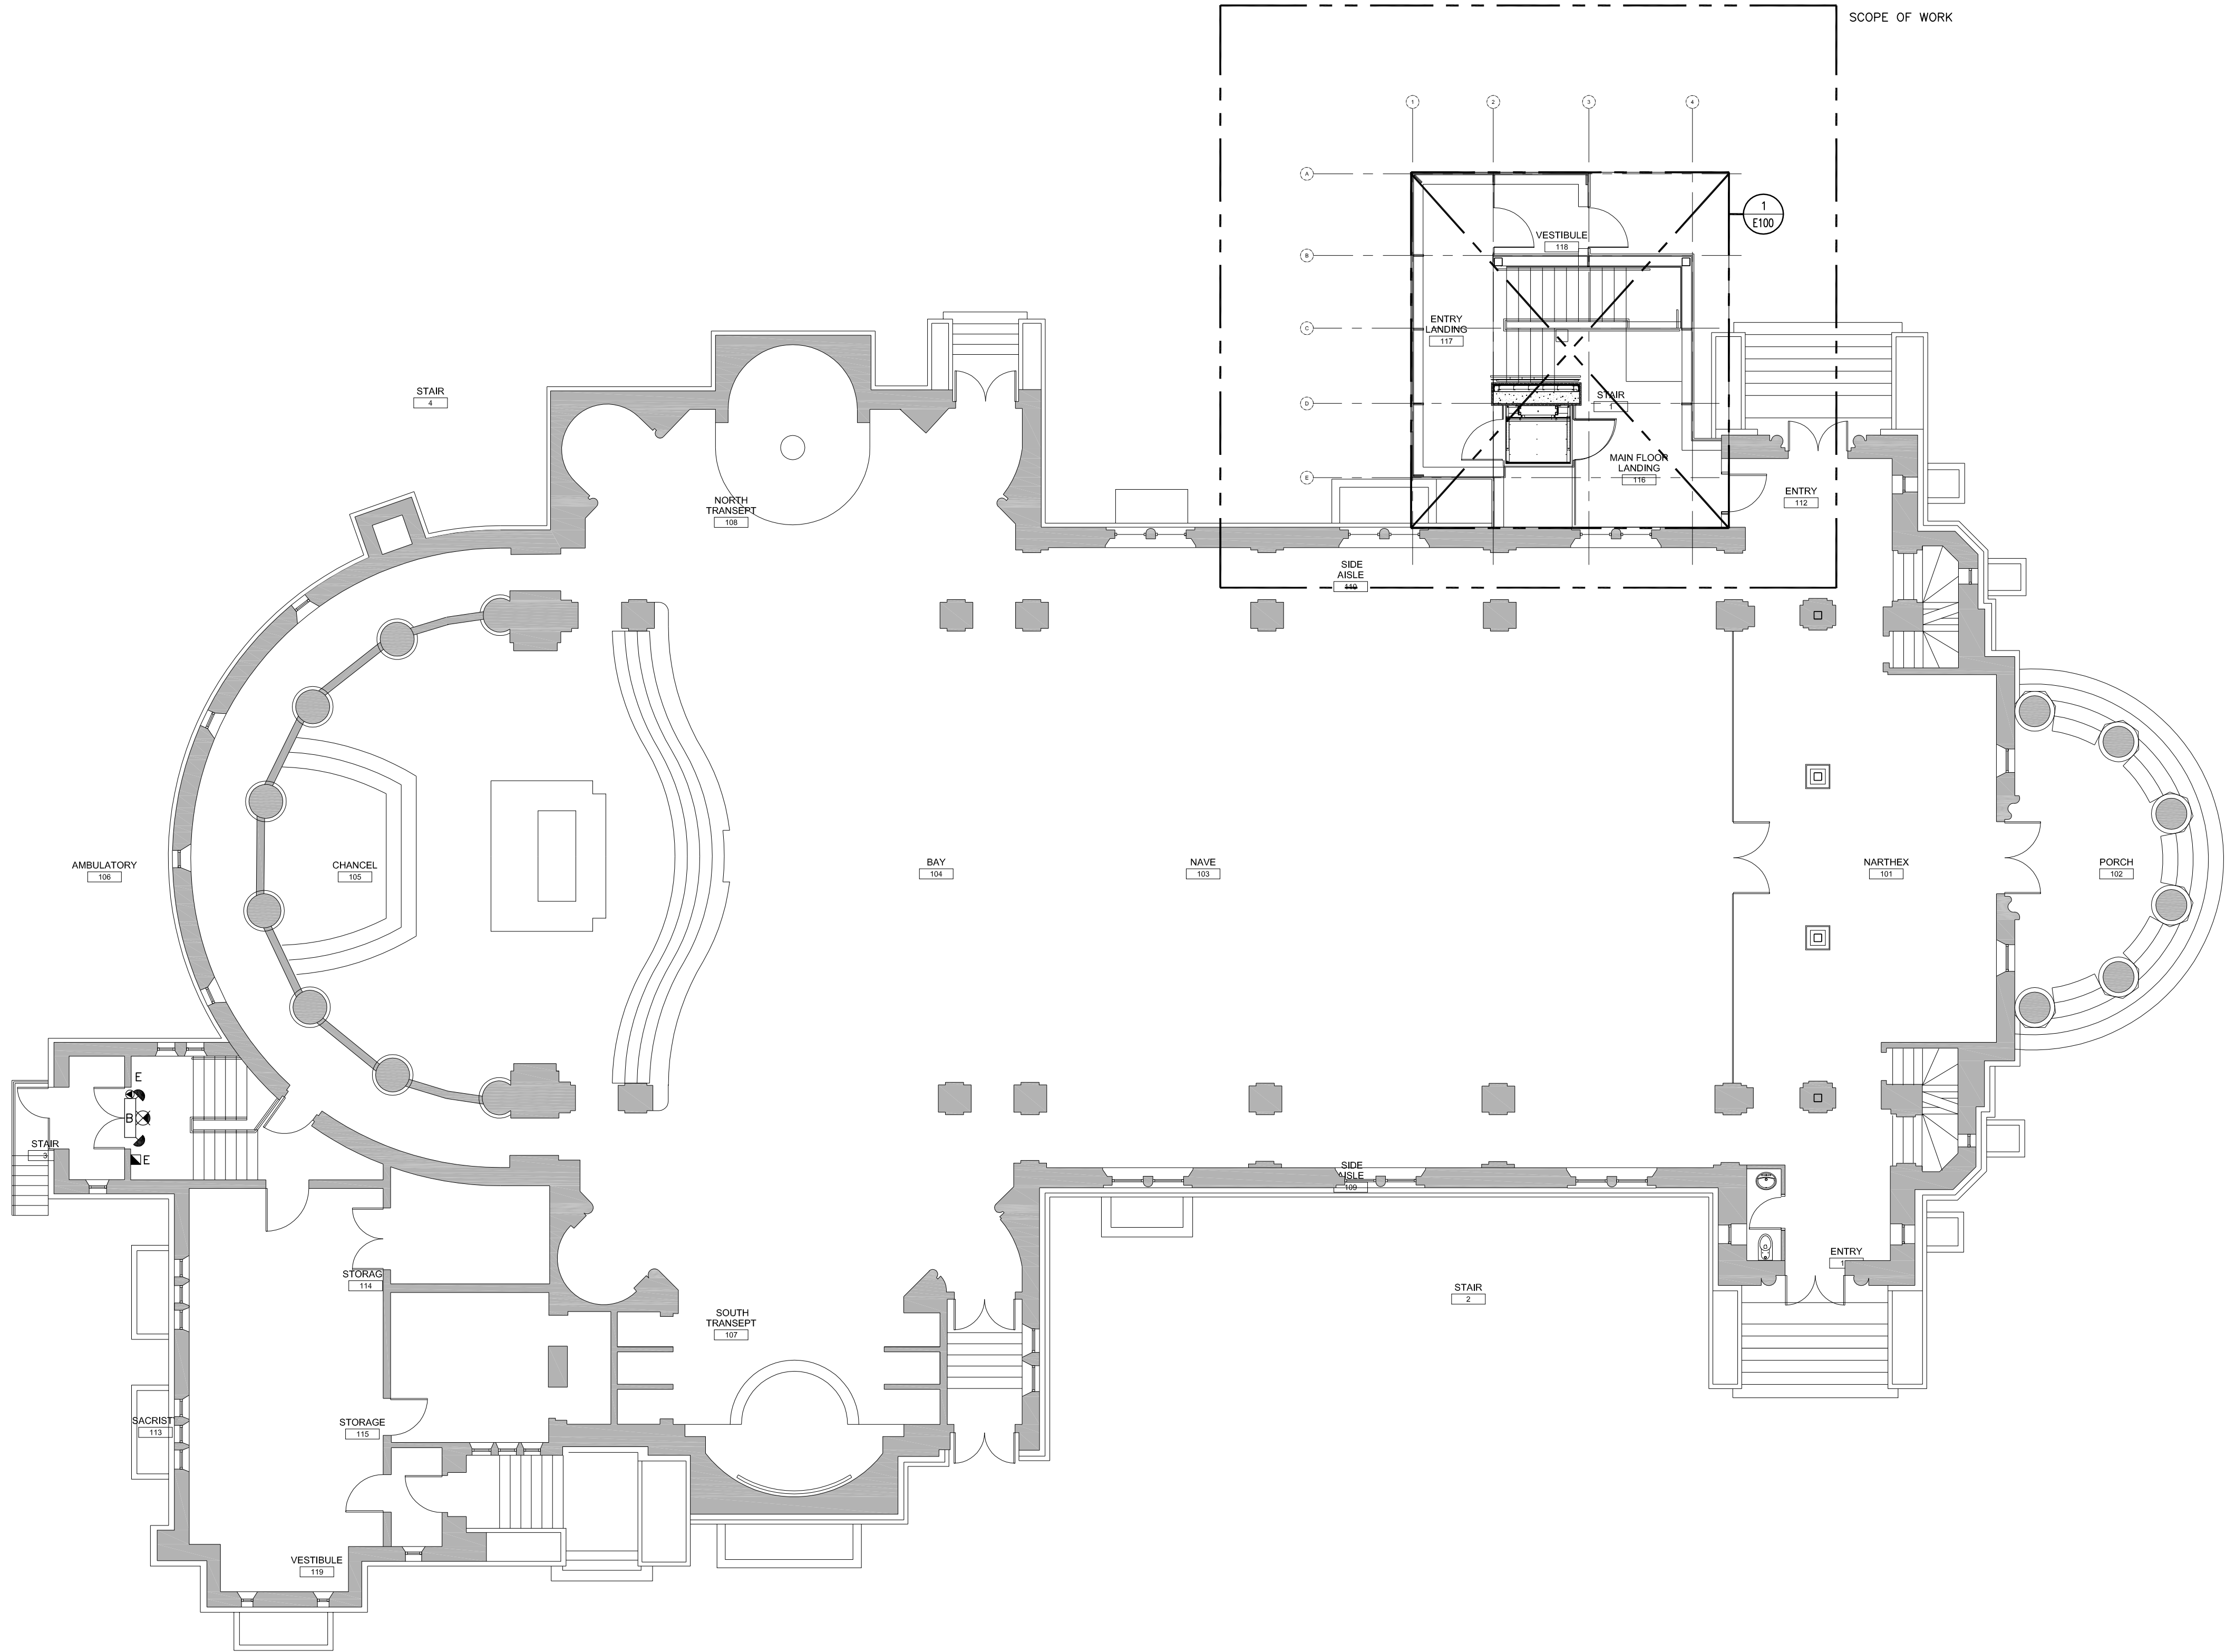

4.	2015.12.04	ISSUED FOR TENDER
3.	2015.10.27	ISSUED FOR PERMIT
2.	2015.05.01	ISSUED FOR PERMIT REVIEW
1.	2015.04.30	ISSUED FOR PROGRESS
REV.	DATE	ISSUED

ALL MEASUREMENTS MUST BE CHECKED ON THE JOB BY THE CONTRACTOR. DRAWINGS MUST NOT BE SCALED. ALL DRAWINGS AND SPECIFICATIONS ARE THE PROPERTY OF THE ARCHITECT AND MUST BE RETURNED UPON REQUEST.

OUR LADY OF PERPETUAL HELP CHURCH RENOVATIONS & ADDITIONS

TORONTO, ONTARIO

Our Lady of Perpetual Help Parish
78 Clifton Road
Toronto, ON M4T 2G2



Smith + Andersen
10320-102 Ave, Suite 501 Edmonton Alberta T5J 4A1
780 701 0331 www.smithandandersen.com


Project Title :

Our Lady of Perpetual Help Addition

Title :

ELECTRICAL GROUND FLOOR PLAN


Drawn :	AW	Scale :	1:100	Date :	2015.03.12
Project Number :	14214.002.E001	Drawing Number :			
Reviewed By :	AW				E004

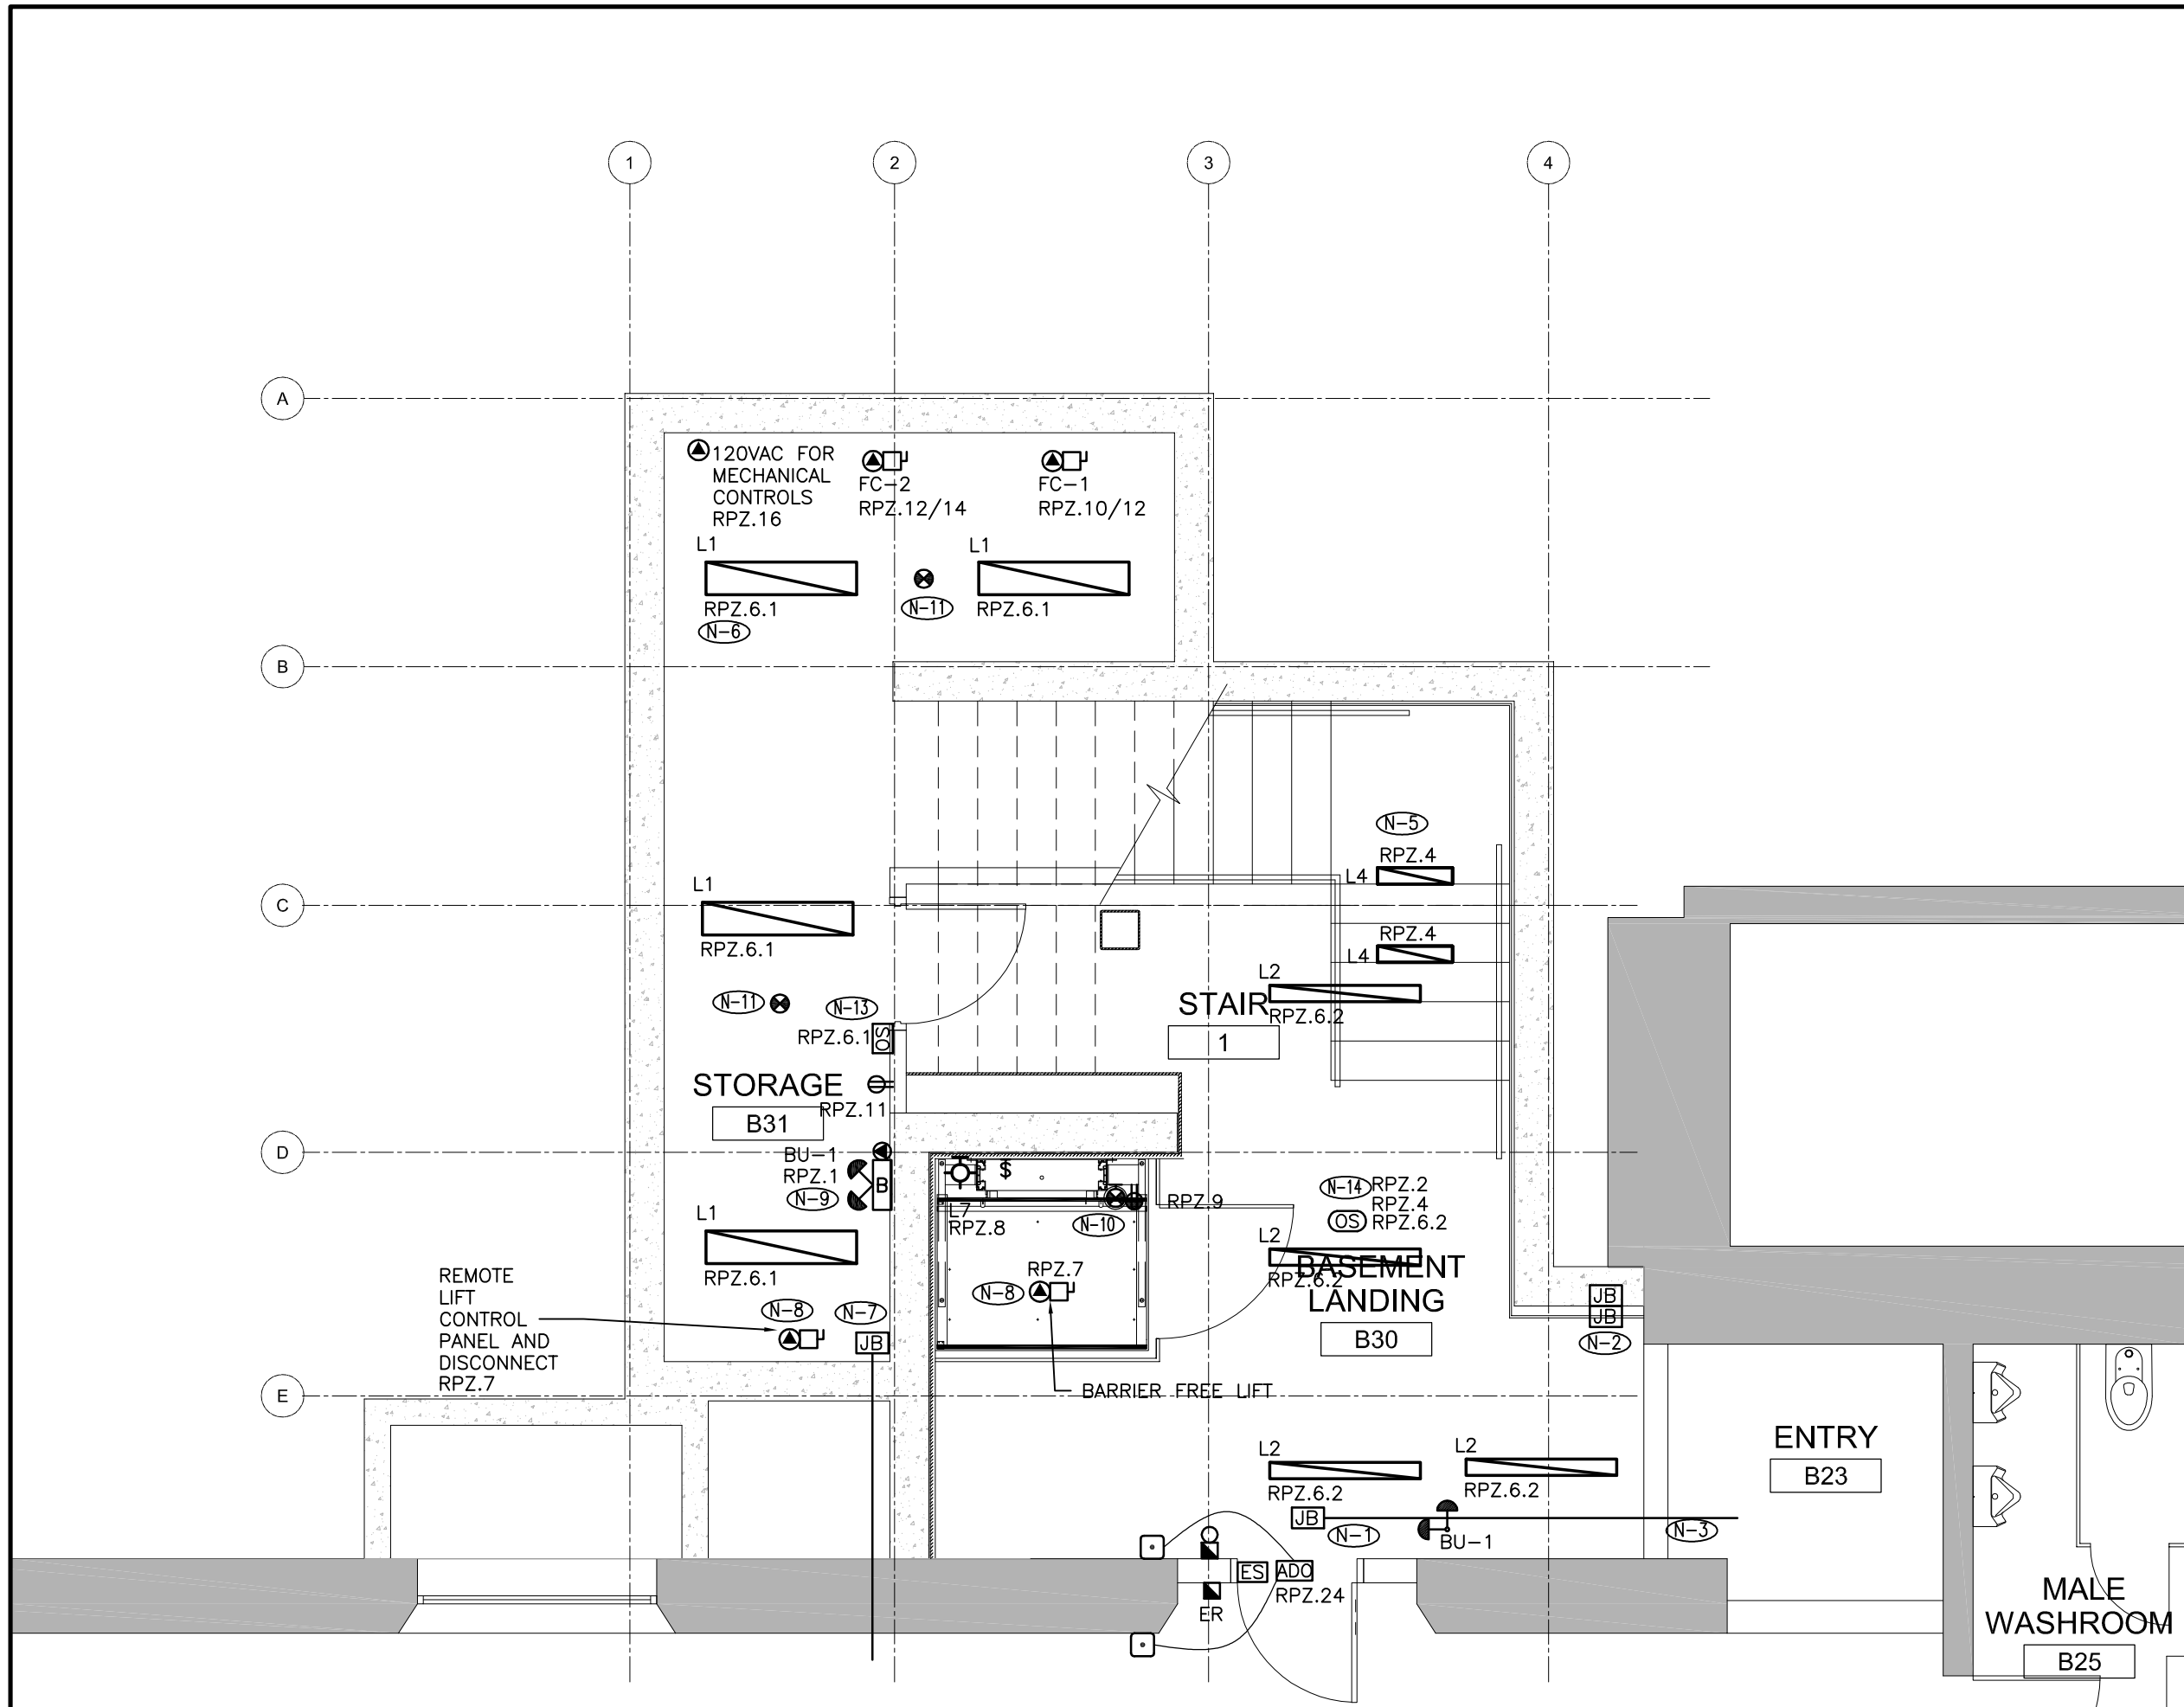

NOTES:

- 8"x8" CEILING JUNCTION BOX FOR LIGHTING. PROVIDE 3/4" CONDUIT AND WIRING HOME RUN FROM JUNCTION BOX TO PANEL. COORDINATE EXACT LOCATION OF CEILING MOUNTED JUNCTION BOX WITH GENERAL CONTRACTOR. GENERAL CONTRACTOR TO PROVIDE 12"x12" ACCESS PANEL FOR ACCESS TO JUNCTION BOX. ACCESS PANEL TO BE SPECIFIED BY ARCHITECT.
- ROUND SLAB JUNCTION BOX WITH EXTENSION BOX IN BASEMENT PLENUM DRYWALL CEILING SPACE. PROVIDE 3/4" CONDUIT AND WIRING HOME RUN FROM JUNCTION BOX BACK TO PANEL. COORDINATE EXACT LOCATION OF CEILING MOUNTED JUNCTION BOX WITH GENERAL CONTRACTOR. GENERAL CONTRACTOR TO PROVIDE 12"x12" ACCESS PANEL FOR ACCESS TO JUNCTION BOX. ACCESS PANEL TO BE SPECIFIED BY ARCHITECT.
- PROVIDE TWO 3/4" SLEEVE AND CONDUITS FOR LINE VOLTAGE WIRING TO REACH SWITCHES ON FLOOR ABOVE.
- JUNCTION BOXES INDICATED ON THIS PLAN DRAWING ARE INTENDED TO FACILITATE A CLEAN GENERAL HOMERUN BACK TO PANEL. CONTRACTOR SHALL INCLUDE IN TENDER ADDITIONAL JUNCTION BOXES AS DEEMED REQUIRED TO COMPLETE INSTALLATION. ADDITIONAL ACCESS LOCATIONS IN DRYWALL AREAS TO BE KEPT TO A MINIMUM AND COORDINATED WITH ARCHITECT AND GENERAL CONTRACTOR.
- TYPICAL S1 STEP LIGHT EMBEDDED IN STAIR. CIRCUIT FROM BASEMENT STORAGE SPACE AND PLENUM IN BASEMENT DRYWALL CEILING. TERMINATION JUNCTION BOX TO BE LOCATED IN BASEMENT STORAGE ROOM.
- TYPICAL L1 STORAGE ROOM LIGHTS TO BE CHAIN SUSPENDED BELOW DUCTWORK. FIXTURES TO BE GENERALLY LOCATED SO AS TO AVOID DUCTWORK. COORDINATE EXACT LOCATION ON SITE WITH MECHANICAL CONTRACTOR. CONTRACTOR TO ALLOW FOR ADJUSTMENTS OF UP TO 1.5M PER FIXTURE.
- GENERAL ROUTING FOR ALL POWER, LIGHTING, COMMUNICATION AND FIRE ALARM SERVICES FROM STORAGE ROOM BACK INTO BUILDING.
- FOR ELEVATOR, ALLOW FOR ONE TELEPHONE/DATA CONNECTION AND RACEWAY FROM LIFT HOISTWAY TO CONTROL PANEL PRIOR TO FINAL HOMERUN BACK TO MAIN TELECOM ROOM. CONTRACTOR TO CONFIRM WIRING WITH ELEVATOR MANUFACTURER AND CONTRACTOR.
- BATTERY UNIT AND REMOTE HEADS TO BE LED TYPE. MANUFACTURER: LUMACELL RGS SERIES WITH 12V-6W REMOTE HEADS OR EQUIVALENT. BATTERY TO BE SIZED FOR A RUN TIME OF 1 HOUR.
- ADD FIRE ALARM ZONE FOR BARRIER FREE LIFT MACHINERY SPACE SMOKE DETECTOR LABELED 'BARRIER FREE LIFT MACHINE SPACE'. SMOKE DETECTOR TO COME COMPLETE WITH RELAY BASE FOR SIGNAL TO BARRIER FREE LIFT CONTROLLER RECALL FUNCTION.
- ADD FIRE ALARM ZONE FOR BASEMENT STORAGE ROOM LABELED 'BARRIER FREE BASEMENT STORAGE ROOM'.
- WALL MOUNTED OCCUPANCY SENSORS SHALL BE DUAL TECHNOLOGY TYPE WITH MANUAL OVERRIDE ON/OFF SWITCH (WATTSTOPPER DW-100 SERIES)
- CEILING MOUNTED OCCUPANCY SENSORS SHALL BE ULTRASONIC TECHNOLOGY TYPE (WATTSTOPPER UT-300 SERIES) COMPLETE WITH POWER PACKS TO SWITCH MULTIPLE CIRCUITS. POWER PACKS TO BE LOCATED IN A JUNCTION BOX WITHIN BASEMENT STORAGE ROOM

2 BASEMENT - POWER, LIGHTING AND SYSTEMS LAYOUT
E100 SCALE: 1:50

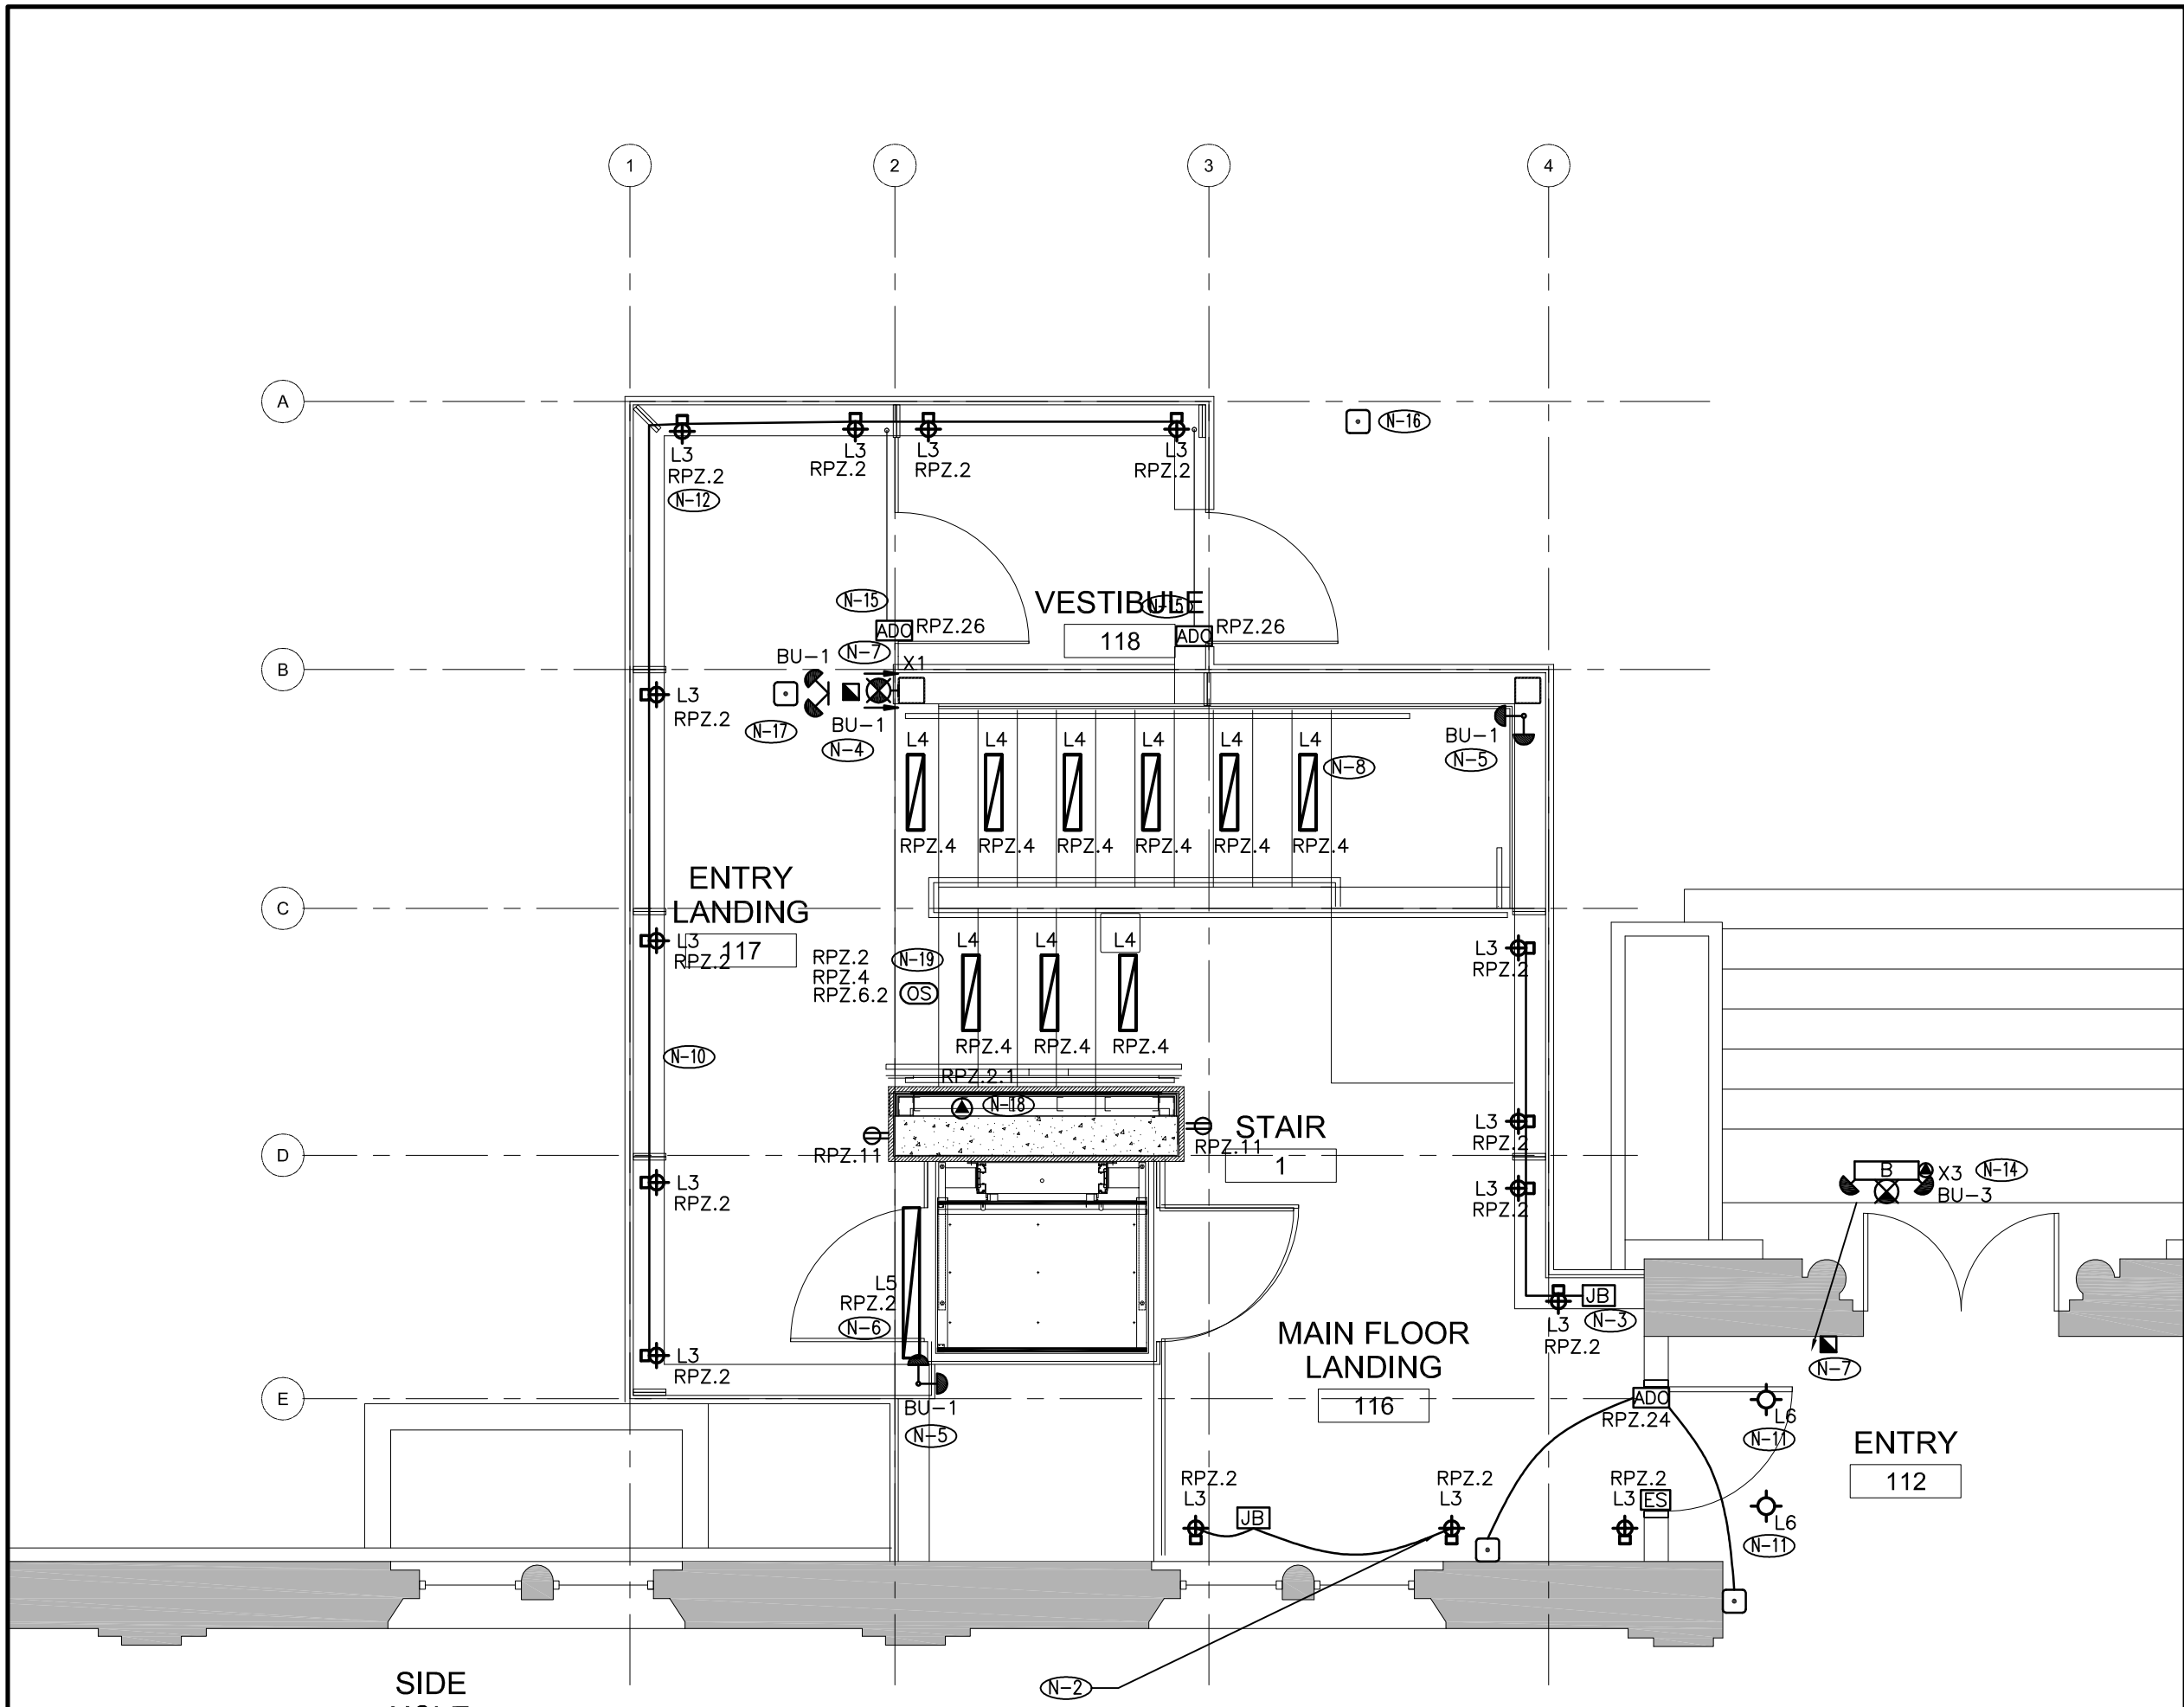

NOTES:

- THE CIRCUITING IN PART IS DIAGRAMMATIC INTENDED TO SHOW GENERAL CIRCUIT ARRANGEMENT AND PANEL DESIGNATION.
- BRANCH CIRCUIT TO BOLLARD LIGHTS. PROVIDE 1" SLEEVE TO BASEMENT CEILING. PROVIDE CONDUIT AND WIRING FROM LIGHT FIXTURE TO CEILING MOUNTED JUNCTION BOX IN BASEMENT.
- BRANCH CIRCUIT TO BOLLARD LIGHTS. RACEWAY TO BE EMBEDDED IN FOUNDATION WALL ROUTED TO A JUNCTION BOX IN PLENUM ABOVE BASEMENT DRYWALL CEILING.
- EXIT SIGN, PULL STATION AND REMOTE HEAD TO BE MOUNTED ON SIDE OF HSS. ROUTING OF WIRING TO BE THROUGH HSS INTO EMBEDDED RACEWAYS IN FOUNDATION WALL BACK INTO STORAGE ROOM. PROVIDE JUNCTION BOX AND CONDUITS AS REQUIRED FOR HOMERUN BACK TO FIRE ALARM PANEL ON WEST SIDE OF BUILDING AS INDICATED ON BASEMENT PLAN.
- REMOTE HEADS TO BE MOUNTED ON UNDERSIDE OF HSS WITH ARMoured WIRING ROUTED THROUGH HSS STEEL DOWN TO FOUNDATION WALL, THROUGH CONCRETE EMBEDDED RACEWAY STUBBED BACK INTO BASEMENT STORAGE ROOM FOR CONNECTION TO BATTERY UNIT.
- LIGHT FIXTURE TO BE MOUNTED ON HSS WITH ARMoured WIRING ROUTED THROUGH HSS STEEL DOWN TO FOUNDATION WALL, THROUGH CONCRETE EMBEDDED RACEWAY STUBBED BACK INTO BASEMENT STORAGE ROOM FOR CONNECTION TO BATTERY UNIT.
- STUB FIRE ALARM PULL STATION WIRING FROM FLOOR BELOW. ADD FIRE ALARM ZONE FOR PULL STATION LABELED 'GROUND FLOOR NORTH EAST'.
- TYPICAL L4 STEP LIGHT EMBEDDED IN STAIR. CIRCUIT FROM BASEMENT STORAGE SPACE AND PLENUM IN BASEMENT DRYWALL CEILING. TERMINATION JUNCTION BOX TO BE LOCATED IN BASEMENT STORAGE ROOM.
- JUNCTION BOXES INDICATED ON THIS PLAN DRAWING ARE INTENDED TO FACILITATE A GENERALLY CLEAN HOMERUN BACK TO PANEL WITH NO CONDUITS VISIBLE. CONTRACTOR SHALL INCLUDE IN TENDER ADDITIONAL JUNCTION BOXES AS DEEMED REQUIRED TO COMPLETE INSTALLATION. ADDITIONAL ACCESS LOCATIONS IN DRYWALL AREAS TO BE KEPT TO A MINIMUM AND COORDINATED WITH ARCHITECT AND GENERAL CONTRACTOR.
- BRANCH CIRCUIT TO BOLLARD LIGHTS. RACEWAY TO BE EMBEDDED IN FOUNDATION WALL ROUTED TO JUNCTION BOXES IN BASEMENT STORAGE ROOM PRIOR TO FINAL HOME RUN.
- CONTRACTOR TO ALLOW FOR TWO L6 LIGHT FIXTURES TO BE LOCATED IN EXISTING ENTRY. CONTRACTOR TO SURVEY EXISTING CONDITION AND ALIGN LIGHT FIXTURE WITH EXISTING LIGHTS IN ENTRYWAY TO REMAIN. EXTEND CIRCUITING FROM EXISTING LIGHTING CIRCUIT WITHIN THAT SPACE. REPAIR AND PATCH ALL AREAS CUT TO OBTAIN ACCESS TO EXISTING CIRCUIT.
- TYPICAL L3 BOLLARD LIGHT TO BE MOUNTED ON FOUNDATION WALL
- ADD FIRE ALARM ZONE FOR PULL STATION SHOWN IN STAIR LABELED 'NORTH EAST BARRIER FREE STAIR'.
- CIRCUIT FROM EXISTING BATTERY UNIT RECEPTACLE REMOVED ON DEMOLITION DRAWING.
- PROVIDE EXTRUDED ALUMINUM RACEWAY STUBBED FROM FOUNDATION WALL FOR CIRCUITS UP TO AUTOMATIC DOOR OPERATORS. PUSH BUTTONS TO BE WIRELESS AND SPECIFIED BY ARCHITECT.
- PUSH BUTTON MOUNTED ON ARCHITECTURAL PEDESTAL WITH CONCRETE BASE. COORDINATE EXACT LOCATION WITH ARCHITECT.
- SURFACE MOUNT PUSH BUTTON ONTO HSS.
- DIRECT CONNECTION FOR WALL LIGHT BOX TO BE SUPPLIED AND SPECIFIED BY ARCHITECT.
- CEILING MOUNTED OCCUPANCY SENSORS SHALL BE ULTRASONIC TECHNOLOGY TYPE (WATTSTOPPER UT-300 SERIES) COMPLETE WITH POWER PACKS TO SWITCH MULTIPLE CIRCUITS. POWER PACKS TO BE LOCATED IN A JUNCTION BOX WITHIN BASEMENT STORAGE ROOM

1 GROUND FLOOR - POWER, LIGHTING AND SYSTEMS LAYOUT
E100 SCALE: 1:50

4.	2015.12.04	ISSUED FOR TENDER
3.	2015.10.27	ISSUED FOR PERMIT
2.	2015.05.01	ISSUED FOR PERMIT REVIEW
1.	2015.04.30	ISSUED FOR PROGRESS
REV.	DATE	ISSUED

ALL MEASUREMENTS MUST BE CHECKED ON THE JOB BY THE CONTRACTOR. DRAWINGS MUST NOT BE SCALED. ALL DRAWINGS AND SPECIFICATIONS ARE THE PROPERTY OF THE ARCHITECT AND MUST BE RETURNED UPON REQUEST.

OUR LADY OF PERPETUAL HELP CHURCH RENOVATIONS & ADDITIONS

TORONTO, ONTARIO

Our Lady of Perpetual Help Parish
78 Clifton Road
Toronto, ON M4T 2G2



Smith + Andersen

10320-102 Ave. Suite 501 Edmonton Alberta T5J 4A1
780 701 0331 www.smithandandersen.com

Project Title :

Our Lady of Perpetual Help Addition

Title :

POWER, LIGHTING AND SYSTEMS PLAN

Drawn :	AW	Scale :	1:50	Date :	2015.03.12
Project Number :	14214.002.E001	Drawing Number :			
Reviewed By :	AW				E100

4.	2015.12.04	ISSUED FOR TENDER
3.	2015.10.27	ISSUED FOR PERMIT
2.	2015.05.01	ISSUED FOR PERMIT REVIEW
1.	2015.04.30	ISSUED FOR PROGRESS
REV.	DATE	ISSUED

ALL MEASUREMENTS MUST BE CHECKED ON THE JOB BY THE CONTRACTOR. DRAWINGS MUST NOT BE SCALED. ALL DRAWINGS AND SPECIFICATIONS ARE THE PROPERTY OF THE ARCHITECT AND MUST BE RETURNED UPON REQUEST.

OUR LADY OF PERPETUAL HELP CHURCH RENOVATIONS & ADDITIONS

TORONTO, ONTARIO


Our Lady of Perpetual Help Parish
78 Clifton Road
Toronto, ON M4T 2G2



Project Title :
Our Lady of Perpetual Help Addition

Title :
POWER, LIGHTING, AND SYSTEMS DEMOLITION PLAN


Drawn :	AW	Scale :	1:50	Date :	2015.03.12
Project Number :	14214.002.E001	Drawing Number :			
Reviewed By :	AW				ED100

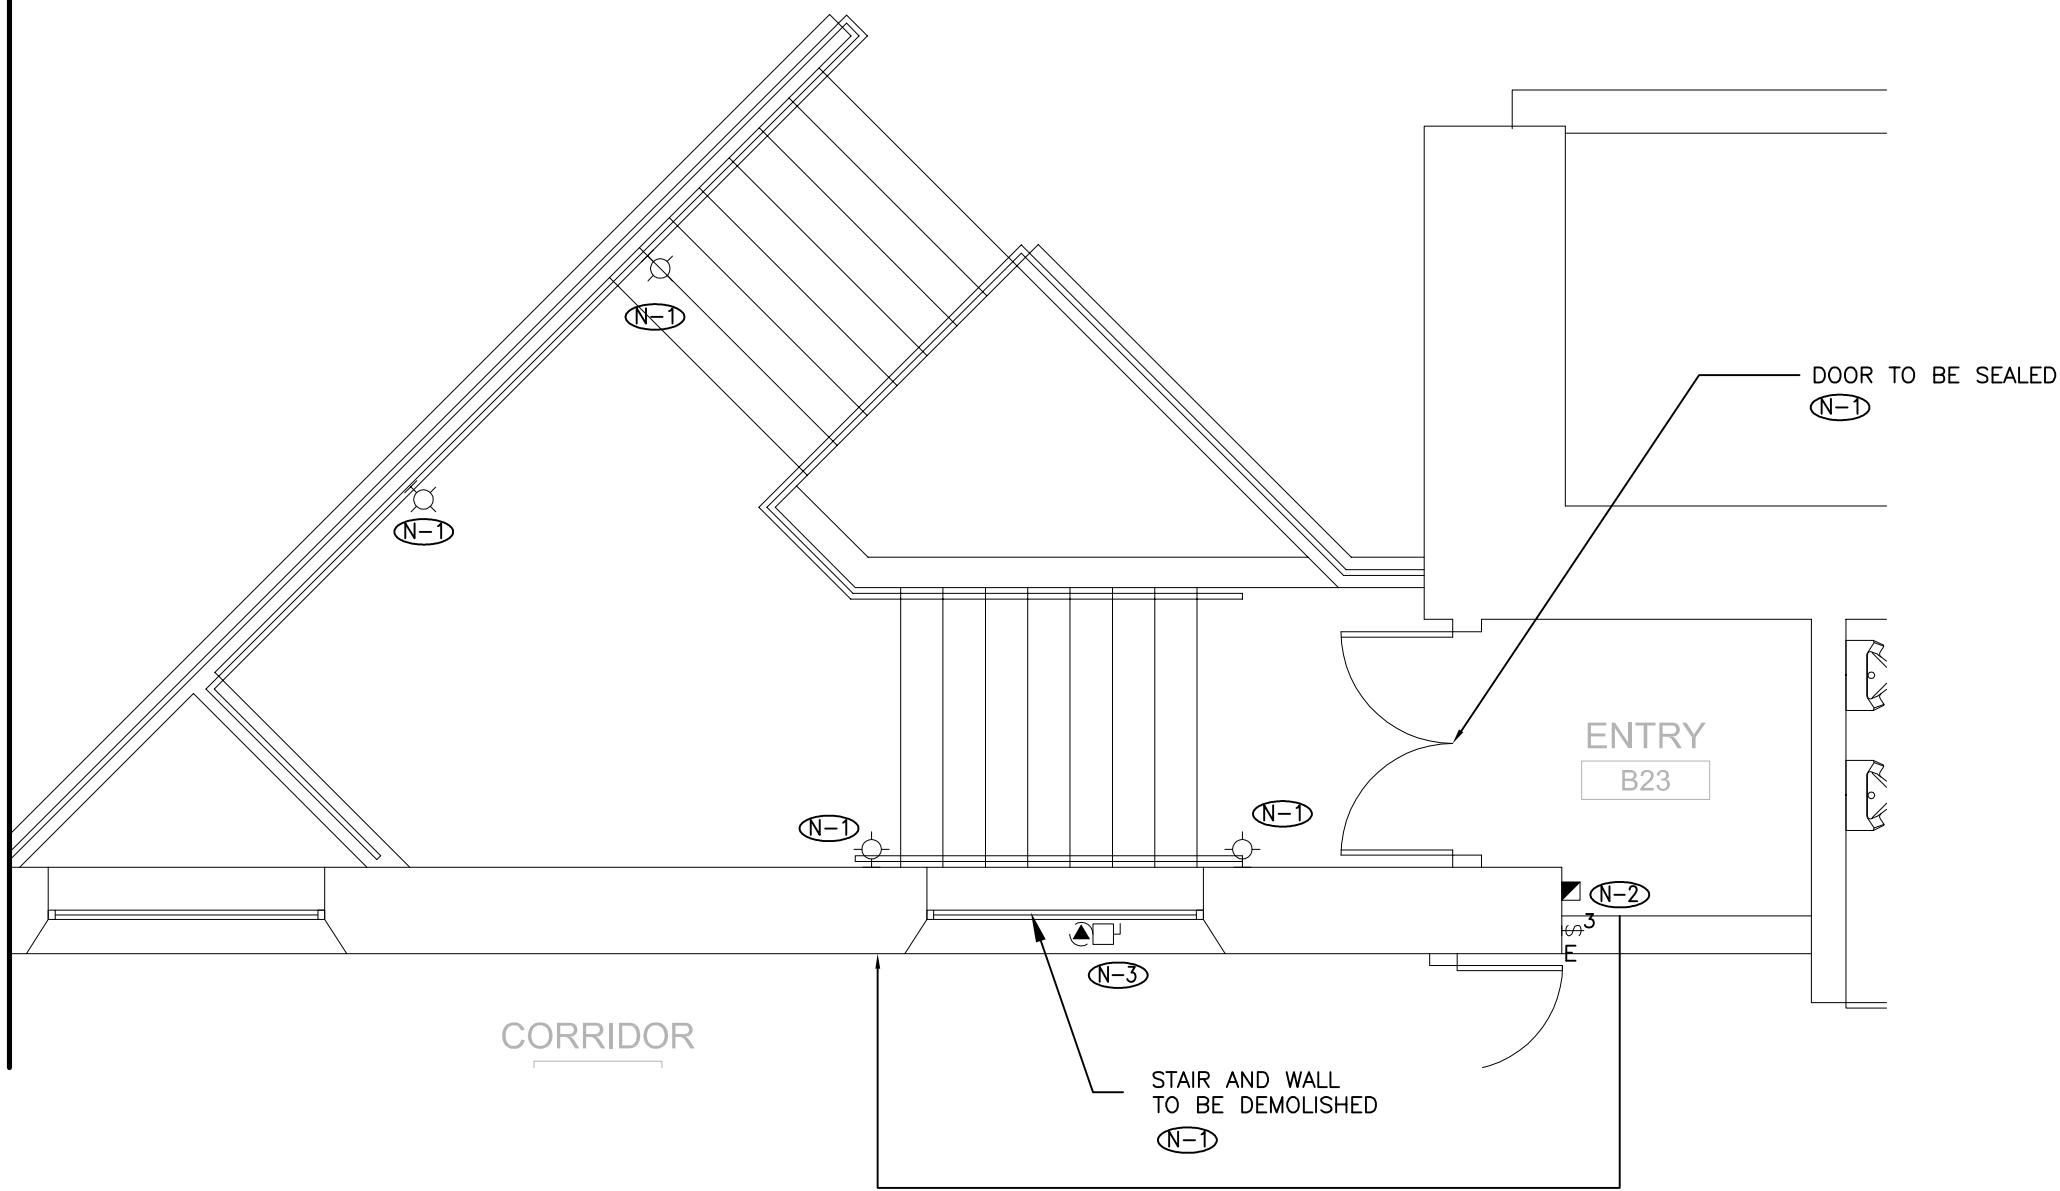

NOTES:

- (N-1) FOR AREAS IDENTIFIED TO BE DEMOLISHED, CONTRACTOR TO REMOVE CONDUIT, REMOVE WIRING BACK TO SOURCE AND MAKE SAFE. FOR ELECTRICAL AND SYSTEM SERVICES PASSING THROUGH THE AREA, CONTRACTOR SHALL INCLUDE FOR ALL REROUTING NECESSARY TO ACHIEVE NEW DESIGN AND MAINTAIN EXISTING SERVICES.
- (N-2) RELOCATE FIRE ALARM PULL STATION AND END OF LINE RESISTOR. PROVIDE NEW RECESSED OUTLET BOXES AT NEW LOCATION.
- (N-3) DISCONNECT AND REMOVE EXHAUST FAN IN WINDOW. RETURN TO OWNER AS SPARE. MAKE SAFE ELECTRICAL CONNECTIONS TO A JUNCTION BOX WITHIN ACCESSIBLE CEILING SPACE BY EXHAUST FAN.

2 BASEMENT – POWER, LIGHTING AND SYSTEMS DEMOLITION LAYOUT
E100
SCALE: 1:50

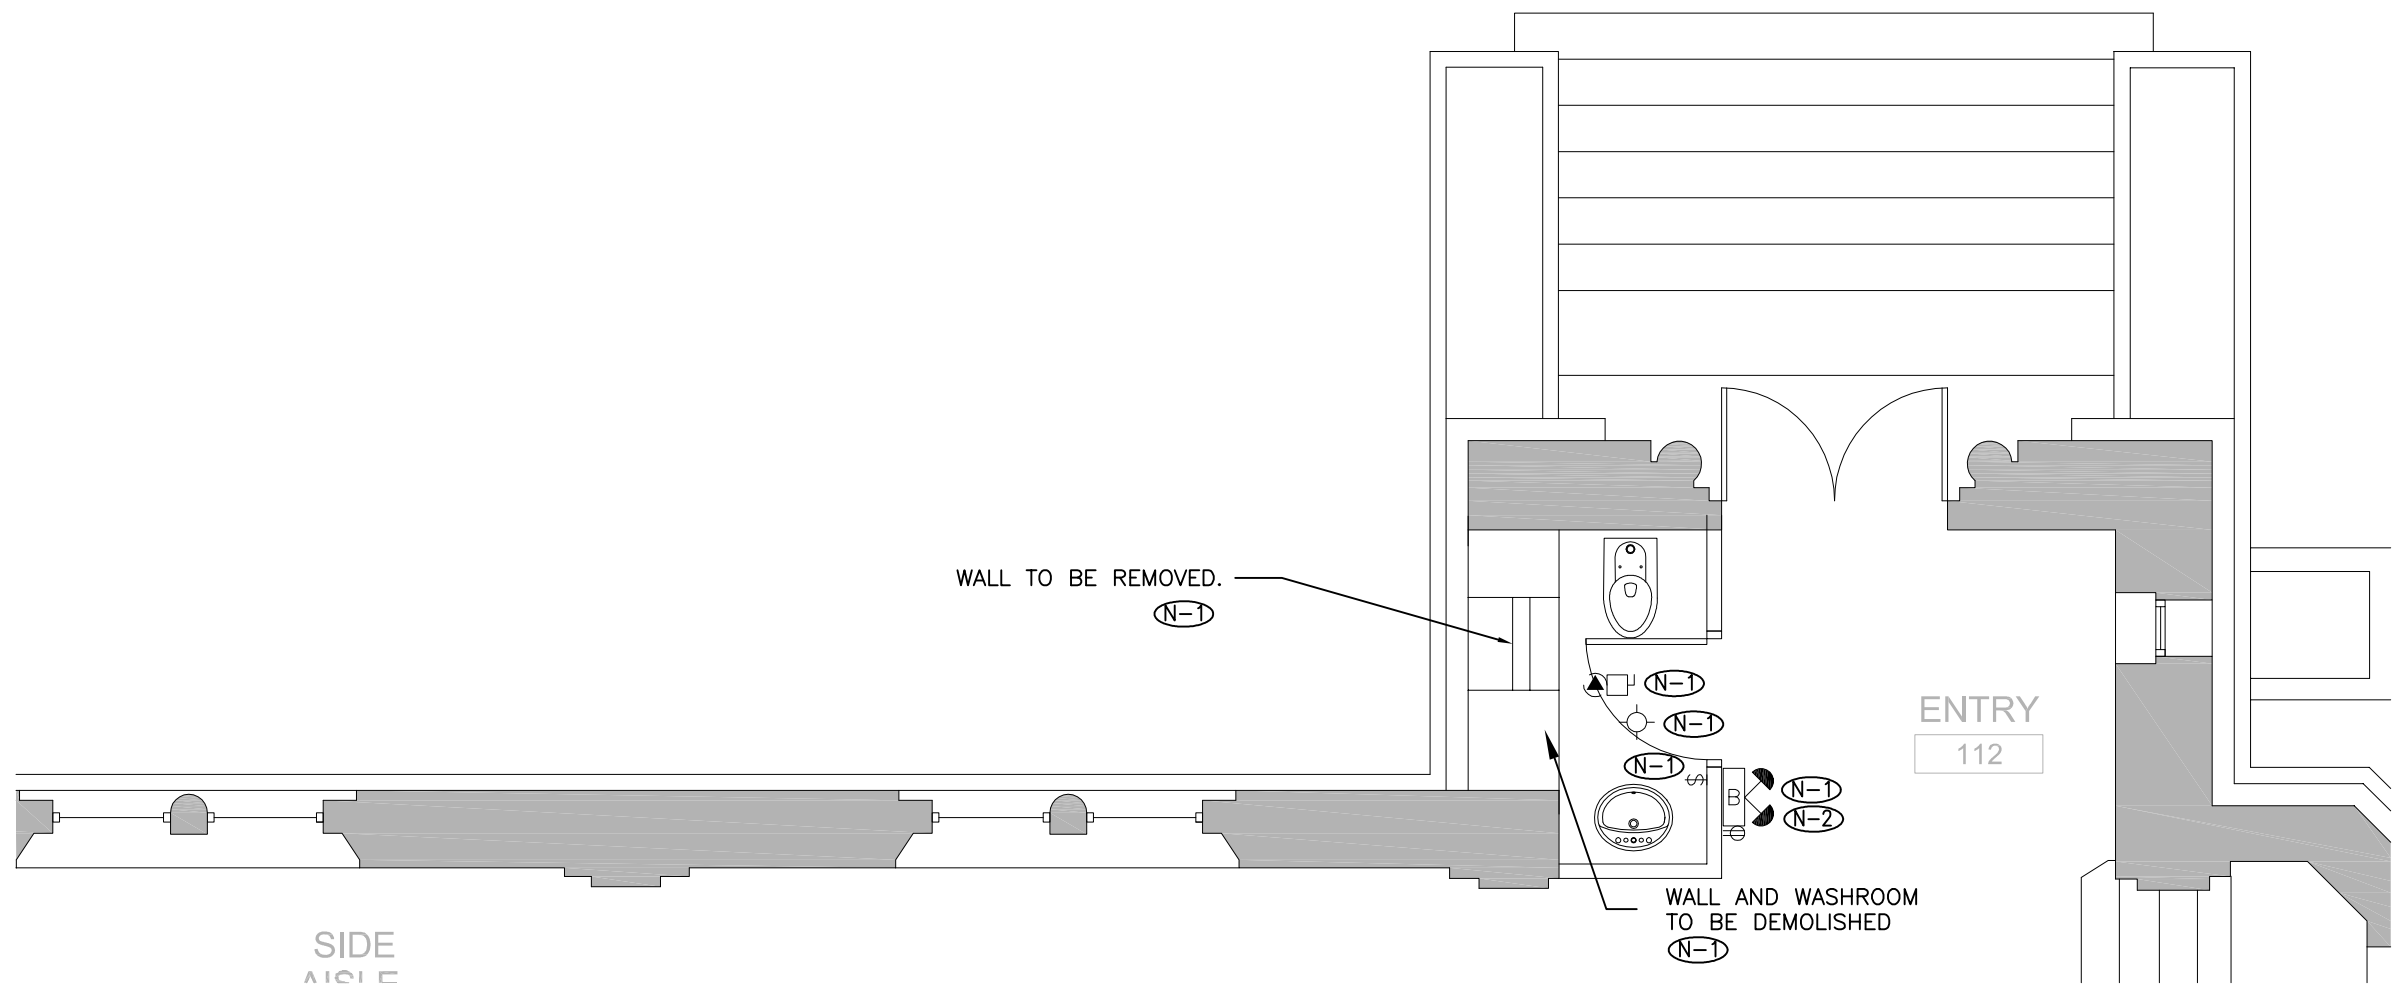

NOTES:

- (N-1) FOR AREAS IDENTIFIED TO BE DEMOLISHED, CONTRACTOR TO REMOVE CONDUIT, REMOVE WIRING BACK TO SOURCE AND MAKE SAFE. FOR ELECTRICAL AND SYSTEM SERVICES PASSING THROUGH THE AREA, CONTRACTOR SHALL INCLUDE FOR ALL REROUTING NECESSARY TO ACHIEVE NEW DESIGN AND MAINTAIN EXISTING SERVICES.
- (N-2) CIRCUIT FOR BATTERY UNIT RECEPTACLE TO BE RE-USED. CONTRACTOR TO TRACE, REMOVE AND ALLOW FOR ENTIRELY NEW WIRING TO NEW EXIT SIGN LOCATION SHOWN ON DRAWING E100 DETAIL 1.

1 GROUND FLOOR – POWER, LIGHTING AND SYSTEMS DEMOLITION LAYOUT
E100
SCALE: 1:50