


ALL DIMENSIONS TO BE CHECKED AND VERIFIED ON THE JOB.
ANY AND ALL DISCREPANCIES TO BE REPORTED TO THE ARCHITECT.


ALL DRAWINGS REMAIN THE PROPERTY OF THE ARCHITECT.
DO NOT SCALE DRAWINGS.

No.	Issue	Date
00	ISSUED FOR PERMIT	10.01.28
01	ISSUED FOR TENDER	10.06.01

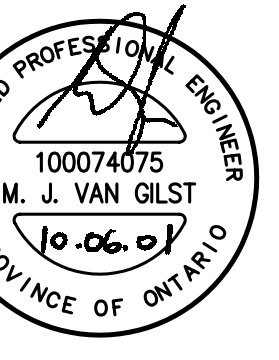

CONSTRUCTION NOTES:

1. PROVIDE HIGH WATER ALARM FOR ELEVATOR SUMP PUMP AND LOCATE WHERE INDICATED. REFER TO ELEVATOR SUMP PIT DETAIL.
2. REFER TO THE HOT WATER SCHEMATIC ON DRAWING P-3 FOR FURTHER DETAIL.
3. PROVIDE REDUCED PRESSURE BACKFLOW PREVENTORS ON THE EXISTING DCW AND DHW LINES SERVING THE PREPARATION ROOM.
4. ROUTE NEW 3" CAST IRON SANITARY RISER AS INDICATED C/W 2" INSULATION WRAP. PROVIDE 1/2" DCW AND 1/2" DHW RISERS AND CONNECT TO LAVATOIRES IN WASHROOMS 111 AND 210. ROUTE STORM RISER DOWN AS INDICATED.
5. ROUTE NEW 3" CAST IRON SANITARY RISER C/W 2" INSULATION WRAP IN FURRED OUT SPACE. CONNECT TO EXISTING SANITARY LINE BELOW THE FLOOR. CONFIRM THE EXACT LOCATION ON SITE.
6. REFER TO CLOSED LOOP HEATING SCHEMATIC FOR CONTINUATION.
7. ISOLATE, DISCONNECT, AND REMOVE EXISTING HOSE BIBS AND RELATED PIPING, VALVES, ETC. TO ACCOMMODATE THE REMOVAL AND REINSTALLATION OF THE STRUCTURAL COLUMNS THEY ARE SUPPORTED FROM. REINSTALL COMPLETELY ONCE NEW COLUMNS ARE IN PLACE. PROVIDE NEW PIPING, VALVES, ETC. AS NECESSARY TO MAKE OPERATIONAL.

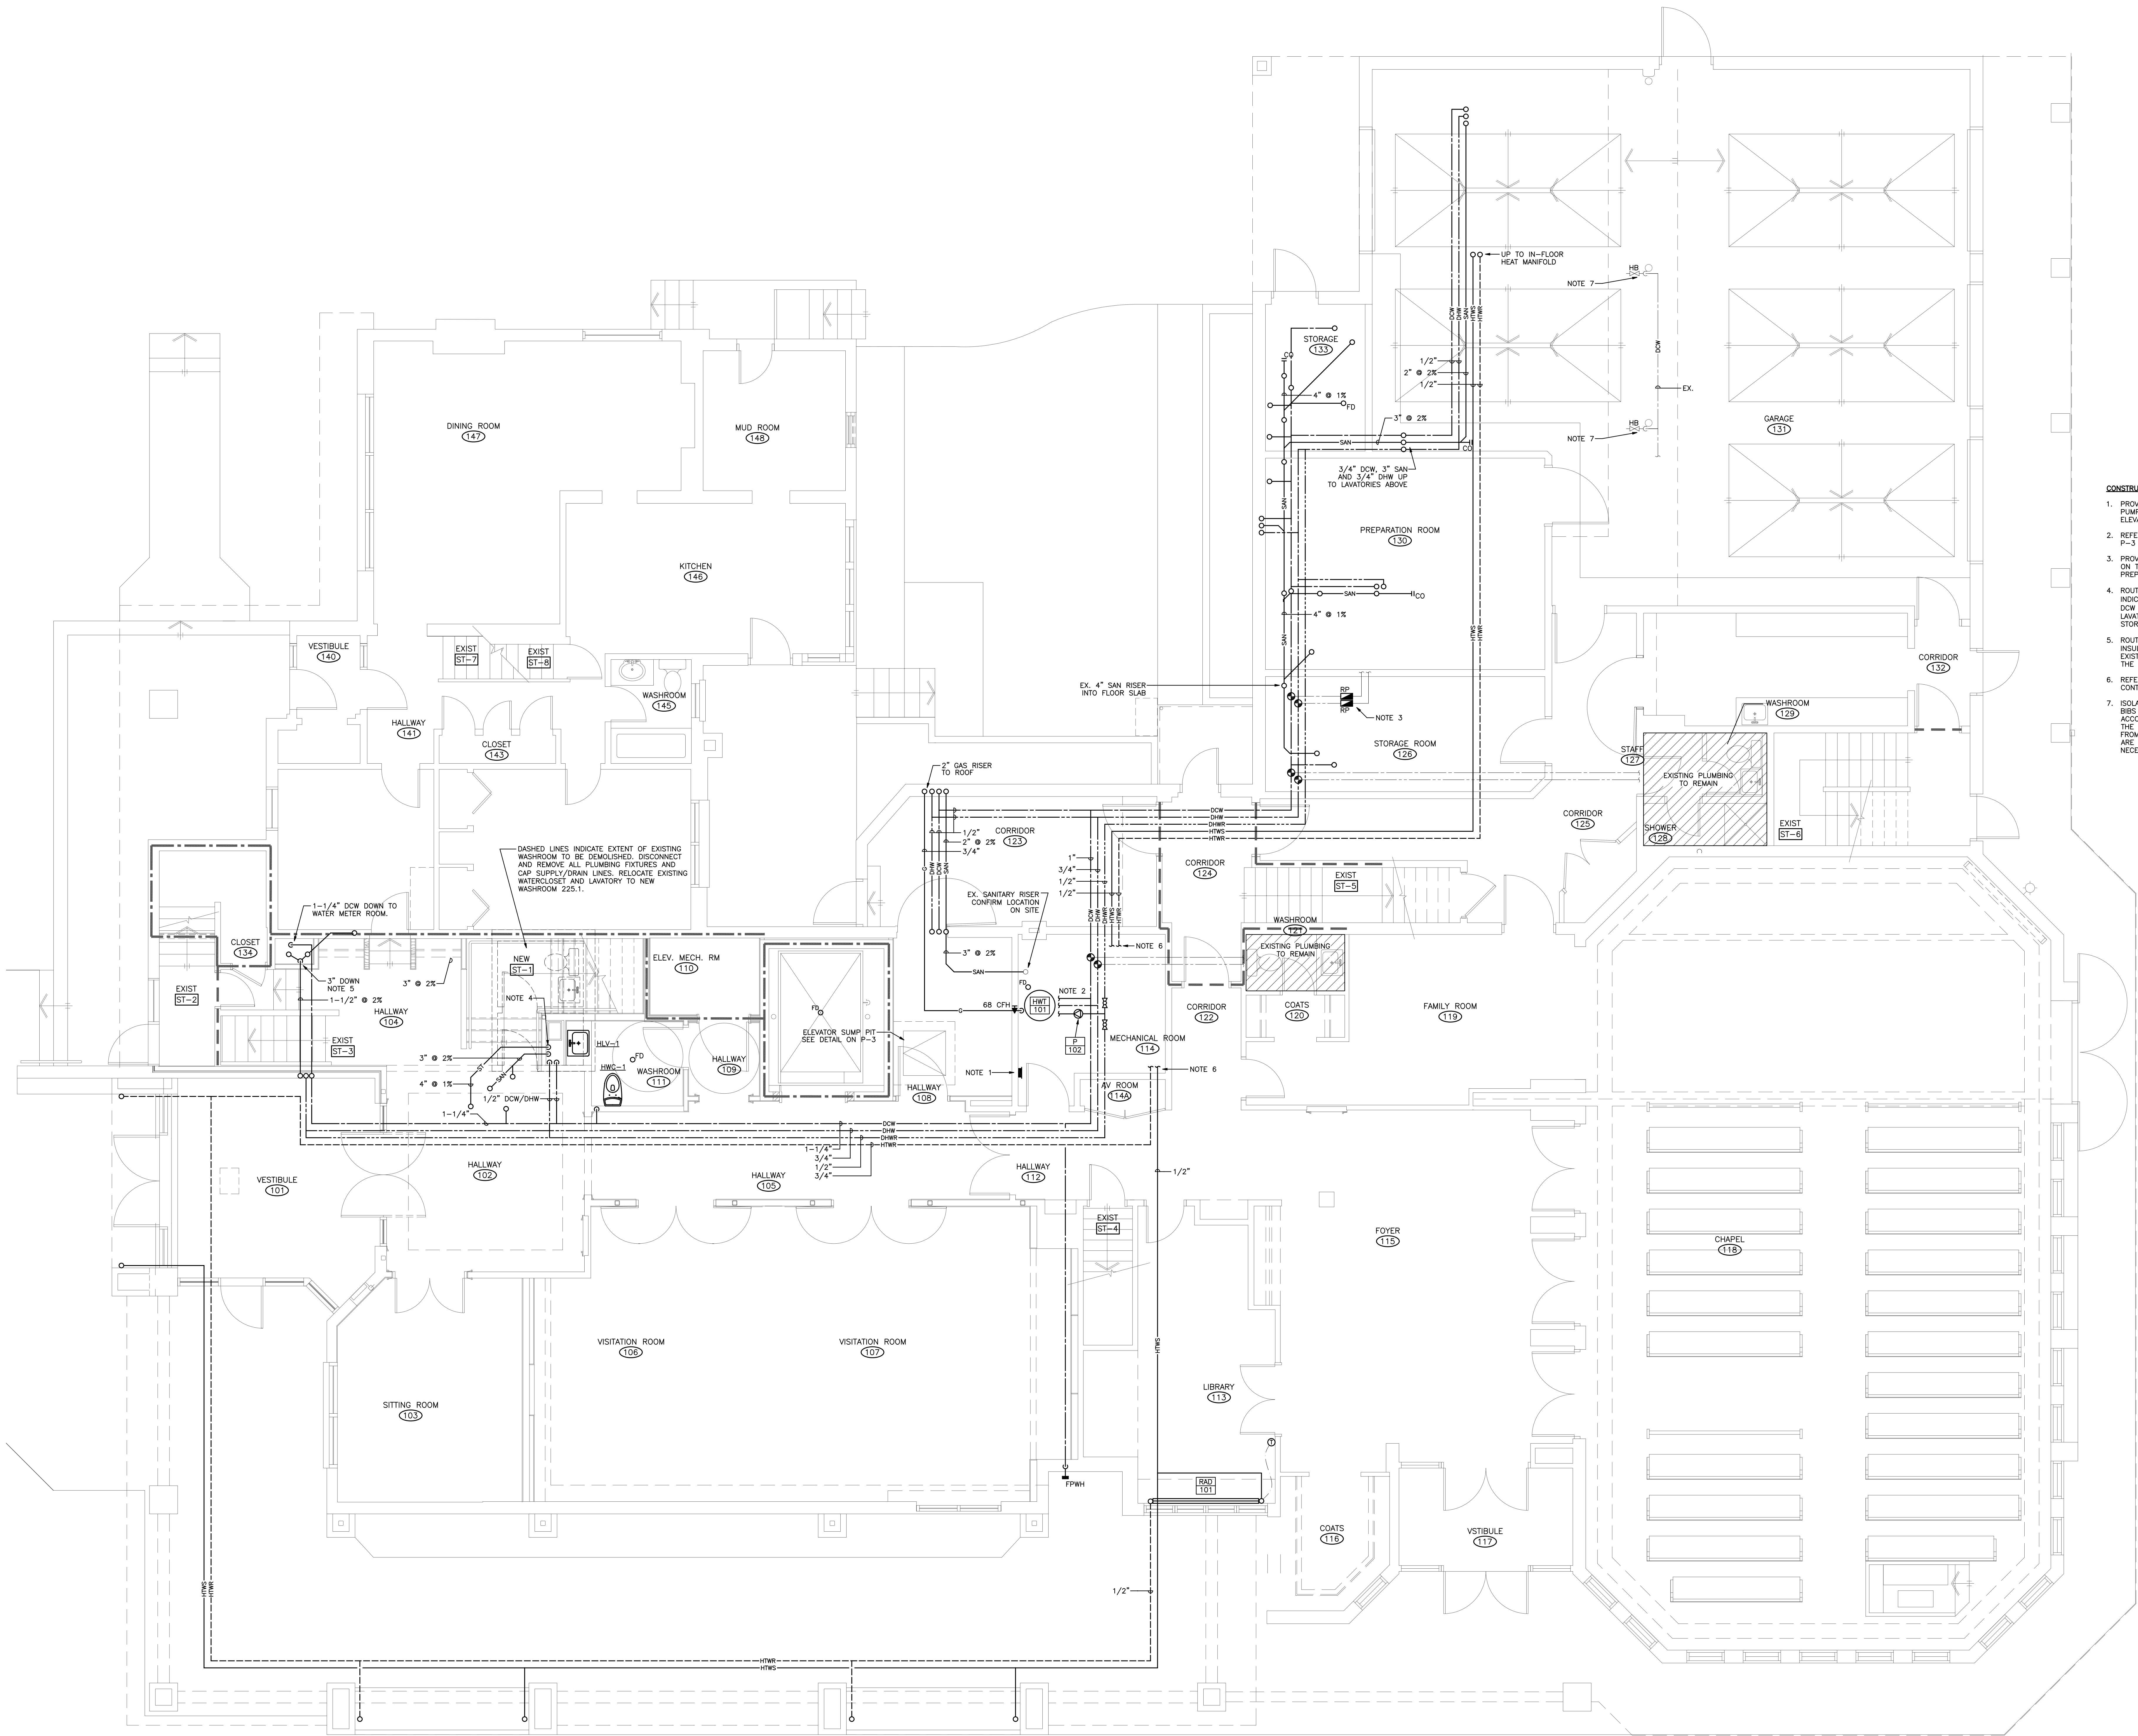

FIRST FLOOR LAYOUT

SCALE: 1/4" = 1'-0"

**ADDITION & ALTERATIONS -
EGAN FUNERAL HOME**

203 Queen St. S., Bolton, ON

**Ground Floor Plumbing
New Construction Layout**

PROJECT NUMBER	CE-1157
SCALE	1/4" = 1'-0"
DATE	FEB 09, 2009
DRAWN	DJR
CHECKED	MJV
SET NO.	DRAWING NO.

P102